


REFLECTED CEILING PLAN - GROUND LEVEL

Scale: 1/16" = 1'-0"

GENERAL NOTES

- A. PROJECT REFERENCE ELEVATION 0'-0" = N.A.V.D. 18.10'
- B. ALL SPOT ELEVATIONS REFER TO CEILING HEIGHT ABOVE FINISHED FLOOR LEVEL, BELOW
- C. REFERENCE ELEVATION FOR ENGINEERING DOCUMENTS FOR ALL LIGHT FIXTURE LOCATIONS, SPECIFICATIONS, AND INFORMATION
- D. REFERENCE MECHANICAL ENGINEERING DOCUMENTS FOR ALL DIFFUSERS AND RETURN AIR GRILLE LOCATIONS, INFORMATION AND SPECIFICATIONS
- E. REFERENCE FIRE ALARM DOCUMENTS FOR ALL CEILING MOUNTED FIRE ALARM LOCATIONS, INFORMATION, AND SPECIFICATIONS, INCLUDES ANY BDA DEVICES
- F. REFERENCE FIRE SPRINKLER PROTECTION PLAN AND SHOP DRAWINGS FOR FIRE SPRINKLER DEVICES, HEADS, AND LOCATIONS
- G. PROVIDE ACOUSTICAL INSULATION ABOVE ALL ENCLOSED HARD CEILING
- H. PROVIDE ALL SHOWERS AND LOCKER ROOM CEILINGS WITH PAPERLESS MOULURE RESISTANT BOARD. TYPICAL FOR ALL CEILINGS, SCREWS, AND NAILS
- I. PAINT EXPOSED STRUCTURES AT GYMNASIUM, AND MAIN CORRIDOR PLATE GY 9179 ANCHOR AREA WHICH INCLUDE PAINTING OF ALL CONDUITS, PIPES, DUCT WORK OR EXPOSED ELEMENTS
- J. ALL HARD CEILINGS TO BE PAINTED TO MATCH DECOR
- K. NO COMBUSTIBLE MATERIALS ALLOWED IN CONCEALED SPACES
- L. TRIMS FOR ALL FIXTURES, SPEAKERS, DIFFUSERS TO MATCH CEILING COLOR FINISH. DO NOT PAINT ON SITE, ALL PAINTED BY MANUFACTURER OR SHOP
- M. PROVIDE FIRE RATED WIRE SUSPENSION FOR ALL ACOUSTICAL SYSTEMS
- N. REFERENCE ENGINEERING PLANS FOR ALL CEILING MOUNTED MOTION SENSOR DEVICES. COLOR TO MATCH CEILING COLOR AND DECOR
- O. ALL PENDANT MOUNTED FIXTURES HAVE MINIMUM 9' A.F.F.L. DO NOT HANG LOWER TO AVOID KIDS HITTING THEM, ETC
- P. PROVIDE ACCESS PANELS AT ALL REQUIRED LOCATIONS. CONTRA VALVES, TESTING DEVICES, OR REQUIRED ACCESS FOR ABOVE MOUNTED CEILING EQUIPMENT. MIN. SIZE 2'x2' OR LARGER WHERE REQUIRED TO ACCESS A/C UNITS OR FILTERS. PROVIDED AND INSTALLED BY GENERAL CONTRACTOR. REFERENCE ALL ENGINEERING AND SHOP DRAWINGS. PROVIDE WHERE REQUIRED
- Q. ALL ACCESS PANELS TO BE METAL COLOR TO MATCH DECOR
- R. AREAS WHERE BAFFLES OR ACOUSTICAL PANELS ARE LOCATED BELOW A/C UNITS OR AREA WITH NEED OF ACCESS PROVIDE SUSPENSION SYSTEM OR MOUNTING CAPABLE OF BEING REMOVED FOR ACCESS
- S. PROVIDE 1 HR RATED SPRAY FIRE PROOFING TO UNDERSIDE OF ROOF DECK
- T. PROVIDE SPRAY-APPLIED FIRE RESISTANT MATERIAL TO ALL INTERIOR DECK AND STEEL BEAMS

REFLECTED CEILING PLAN LEGEND

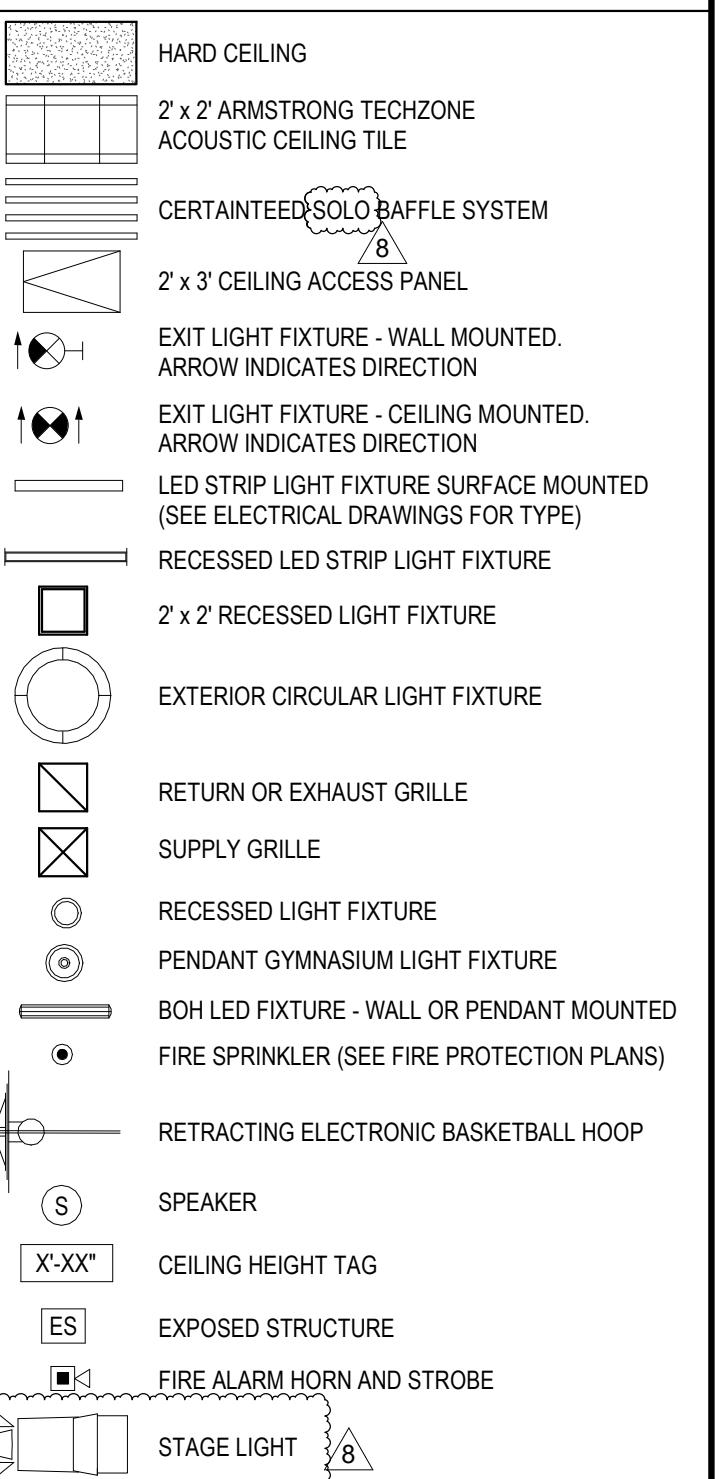

CONFORMED SET 09/22/2025

REFLECTED CEILING PLAN - GROUND LEVEL

SHEET:

2122

AC110

PROJECT:

**CITY OF DELRAY BEACH
POMPEY PARK REC CENTER**

**1101 NW 2ND ST. DELRAY BEACH
FL 33444**

SEAL:

AA C001388

ALL DESIGN AND DATA IS OWNED OR RESERVED BY THIS DRAWING AND CANNOT BE USED OR COPIED IN WHOLE OR IN PART, OR FOR ANY OTHER PROJECT, WITHOUT THE WRITTEN CONSENT OF THE CONTRACTOR. THE CONTRACTOR SHALL VERIFY ALL EXISTING CONDITIONS AND DIMENSIONS AND THE CONTRACTOR SHALL NOT BE HELD LIABLE FOR ANY INACCURACIES. THE CONTRACTOR PLEADS TO THE EXCUSE OF THE FIRM FOR ANY ERRORS OR OMISSIONS.

REVISIONS:

4-03-2023 BD COMMENTS


5-02-09-2024 REVISION

8-19-22-2025 CONFIRMED SET


DATE: Dec 27, 2022

DRAWN BY: SV, CC, FE, LS

CHECKED BY: J.J. LS, JS

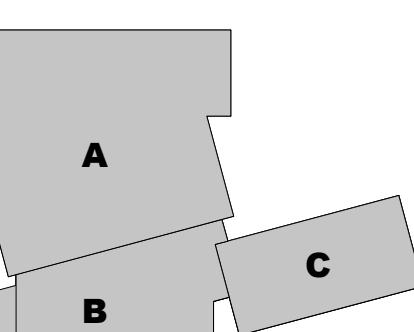

KEY PLAN
N.T.S.

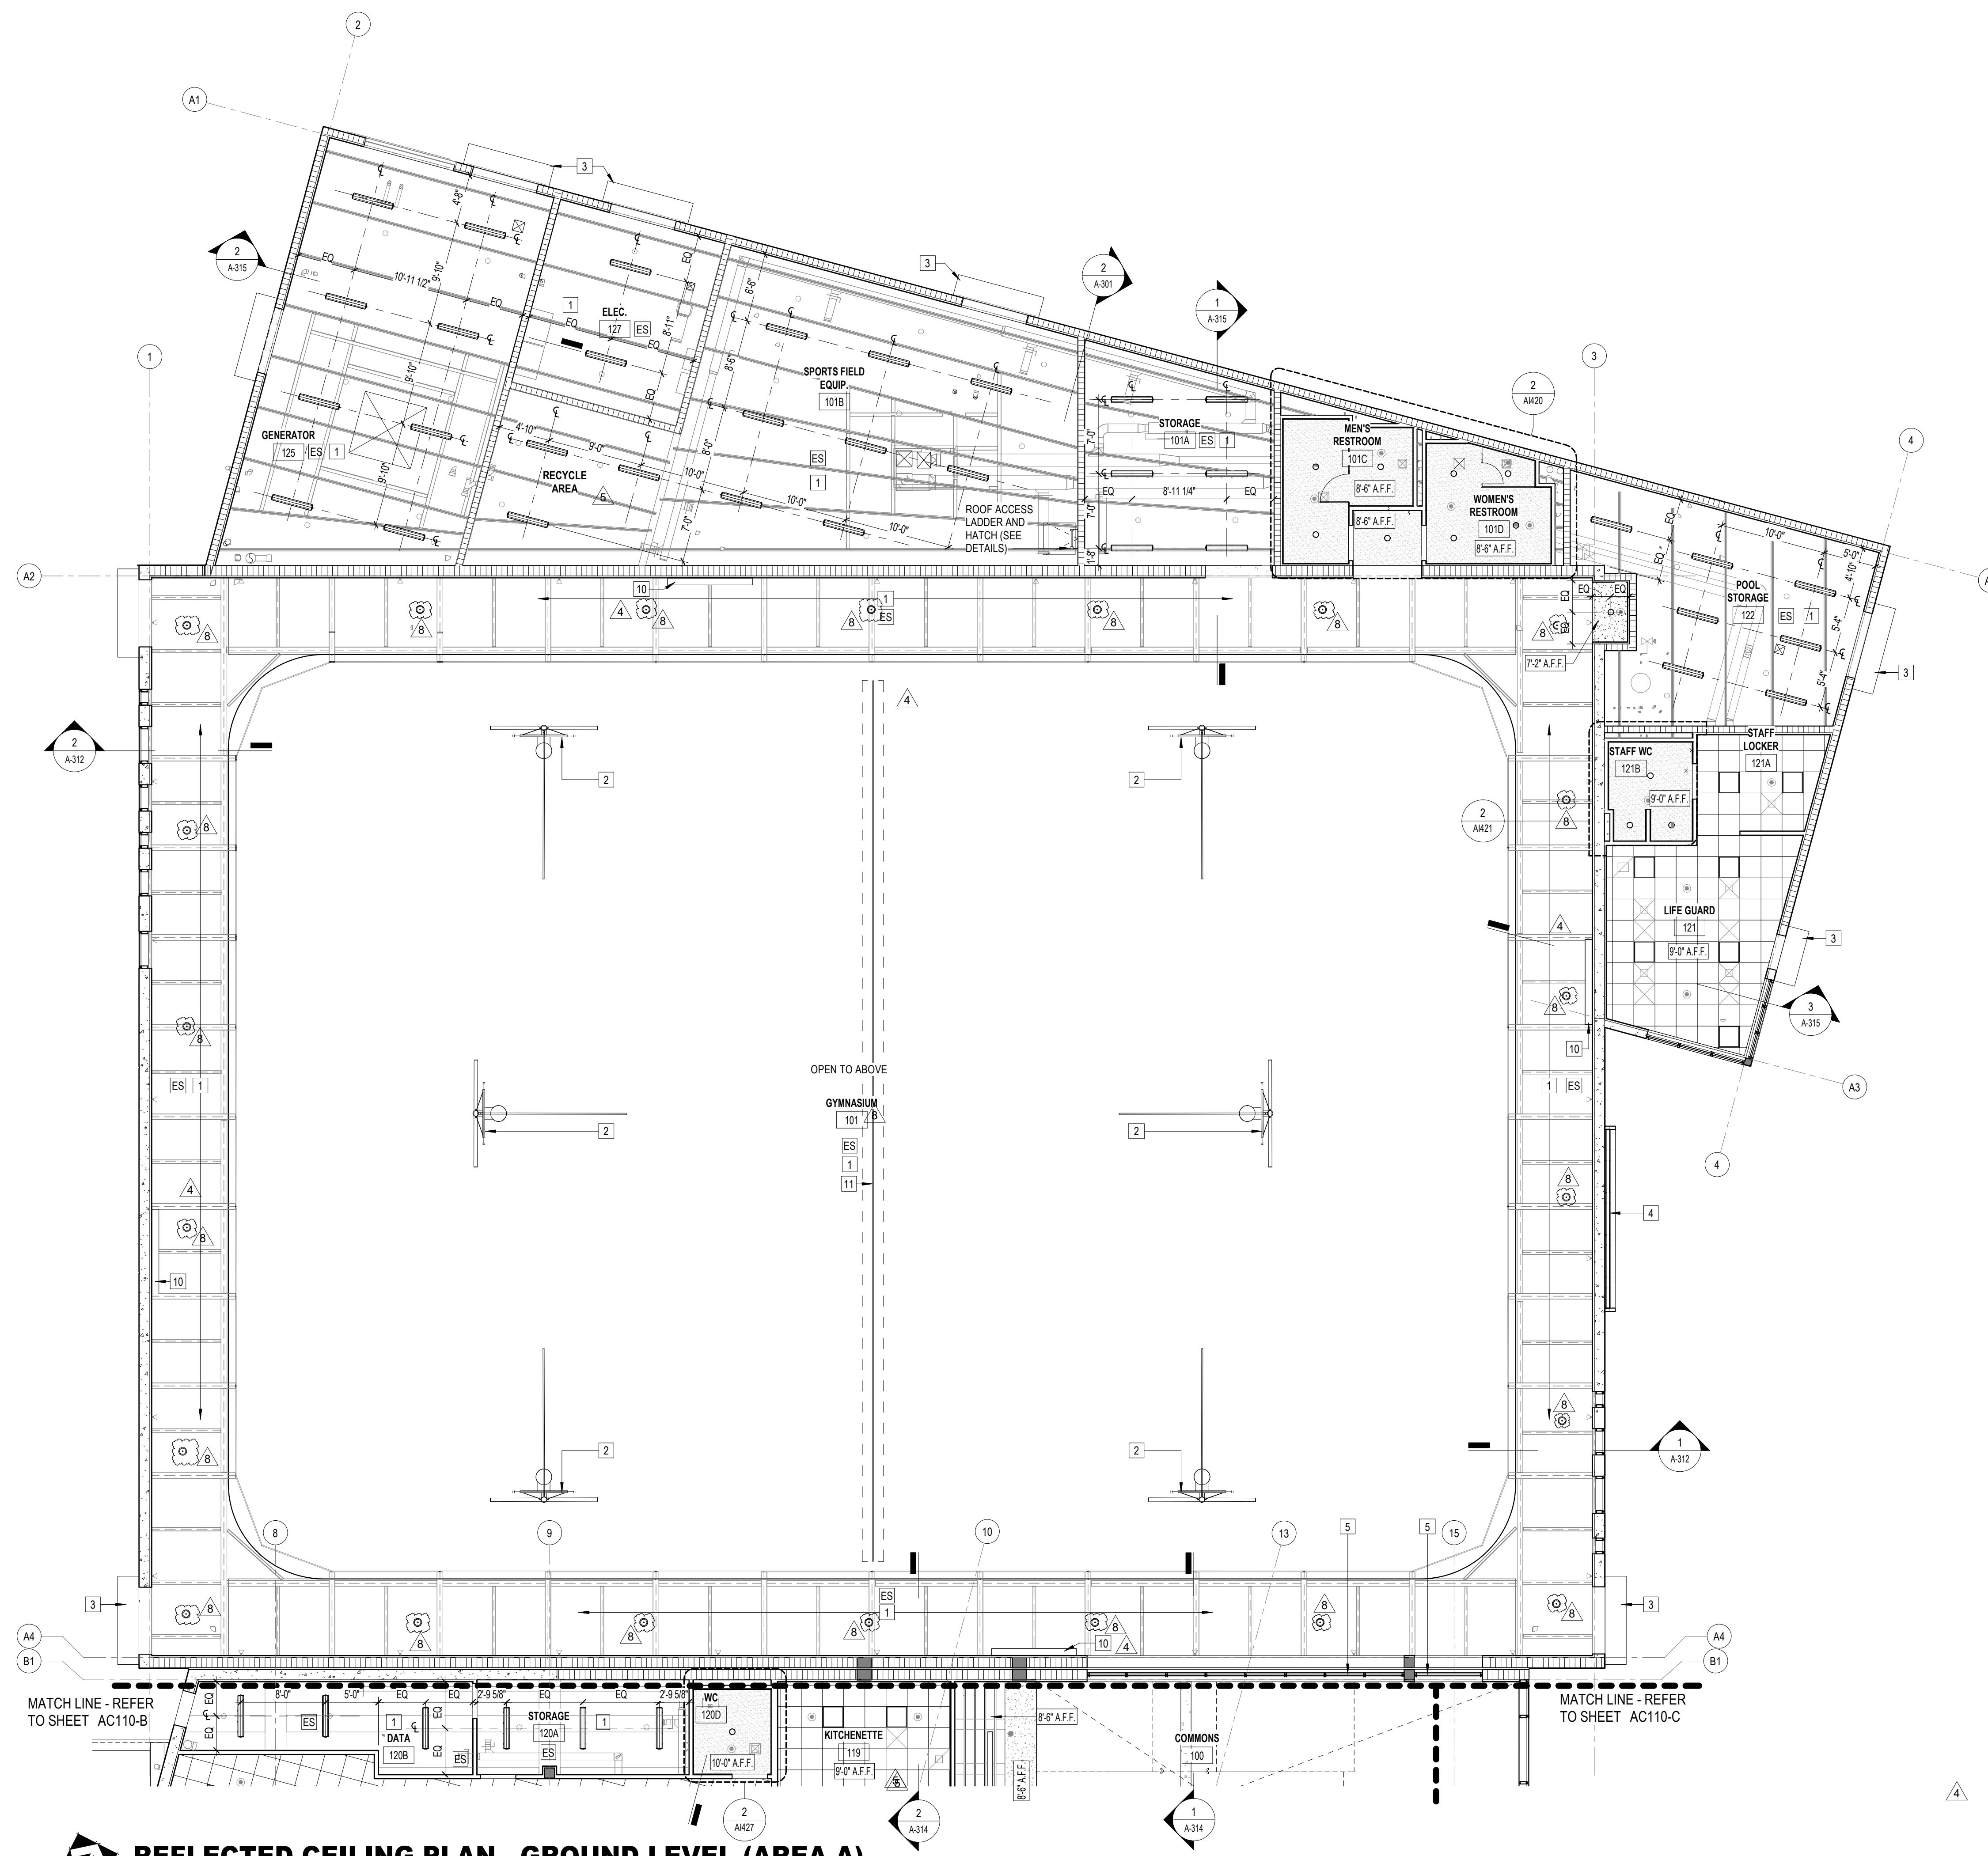

GENERAL NOTES	
A. PROJECT REFERENCE ELEVATION 0'-0" = N.A.V.D. 18.10' FURNISHED FLOOR LEVEL, BELOW.	
C. REFERENCE ELECTRICAL ENGINEERING DOCUMENTS FOR ALL LIGHT FIXTURE LOCATIONS, SPECIFICATIONS, AND INFORMATION.	
D. REFERENCE MECHANICAL ENGINEERING DOCUMENTS FOR ALL DIFFUSERS AND RETURN AIR GRILLE LOCATIONS, INFORMATION AND SPECIFICATIONS.	
E. REFERENCE FIRE ALARM DOCUMENTS FOR ALL CEILING MOUNTED FIRE ALARM LOCATIONS, INFORMATION, AND SPECIFICATIONS. INCLUDE ANY BDA DEVICES.	
F. REFERENCE FIRE SPRINKLER PROTECTION PLAN AND SHOP DRAWINGS FOR FIRE SPRINKLER DEVICES, HEADS, AND LOCATIONS.	
G. PROVIDE ACOUSTICAL INSULATION ABOVE ALL ENCLOSED HARD CEILING.	
H. PROVIDE ALL SHOWERS AND LOCKER ROOM CEILINGS WITH PAPERLESS MOULURE RESISTANT BOARD. TYPICAL FOR ALL CEILINGS, SCREWS, AND NAILS.	
I. PAINT EXPOSED STRUCTURES AT GYMNASIUM, MAIN CORRIDOR, PLATE SW 9179 ANCHOR AWEIGH! INCLUDE PAINTING OF ALL CONDUITS, PIPES, DUCT WORK, OR EXPOSED ELEMENTS.	
J. ALL HARD CEILINGS TO BE PAINTED TO MATCH DECOR.	
K. NO COMBUSTIBLE MATERIALS ALLOWED IN CONCEALED SPACES.	
L. TRIMS FOR ALL FIXTURES, SPEAKERS, DIFFUSERS TO MATCH CEILING COLOR FINISH. DO NOT PAINT ON SITE; ALL PAINTED BY MANUFACTURER OR SHOP.	
M. PROVIDE FIRE RATED WIRE SUSPENSION FOR ALL ACOUSTICAL SYSTEMS.	
N. REFERENCE ENGINEERING PLANS FOR ALL CEILING MOUNTED MOTION SENSOR DEVICES. COLOR TO MATCH CEILING COLOR AND DECOR.	
O. ALL PENDANT MOUNTED FIXTURES HAVE MINIMUM 9 A.F.F.L. DO NOT MOUNT LOWER TO AVOID KIDS HITTING THEM, ETC.	
P. PROVIDE ACCESS PANELS AT ALL REQUIRED LOCATIONS. CONTROL VALVES, TESTING DEVICES, OR REQUIRED ACCESS FOR ABOVE MOUNTED CEILING EQUIPMENT. MIN. SIZE 2'X2 OR LARGER WHERE REQUIRED TO ACCESS A/C UNITS OR FILTERS. PROVIDED AND INSTALLED BY GENERAL CONTRACTOR. REFERENCE ALL ENGINEERING AND SHOP DRAWINGS. PROVIDE WHERE REQUIRED.	
Q. ALL ACCESS PANELS TO BE METAL COLOR TO MATCH DECOR.	
R. AREAS WHERE BAFFLES OR ACOUSTICAL PANELS ARE LOCATED BELOW A/C UNITS OR AREA WITH NEED OF ACCESS PROVIDE SUSPENSION SYSTEM OR MOUNTING CAPABLE OF BEING REMOVED FOR ACCESS.	
S. PROVIDE 1 HR RATED SPRAY FIRE PROOFING TO UNDERSIDE OF ROOF DECK.	
T. PROVIDE SPRAY-APPLIED FIRE RESISTANT MATERIAL TO ALL INTERIOR DECK AND STEEL BEAMS	

PROJECT: CITY OF DELRAY BEACH POMPEY PARK REC CENTER 1101 NW 2ND ST. DELRAY BEACH FL 33444

REVISIONS: 4 03-02-2023 BD COMMENTS 5 02-09-2024 REVISIONS 6 09-22-2025 CONFORMED SET

CONFORMED SET 09/22/2025

TITLE: GROUND LEVEL REFLECTED CEILING PLAN - AREA A

DRAWN BY: SV, CC, FE, LS


CHECKED BY: J.J., LS, JS

DATE: Dec 27, 2022

JOB NO: 2122

SHEET: AC110-A

KEY PLAN N.T.S.

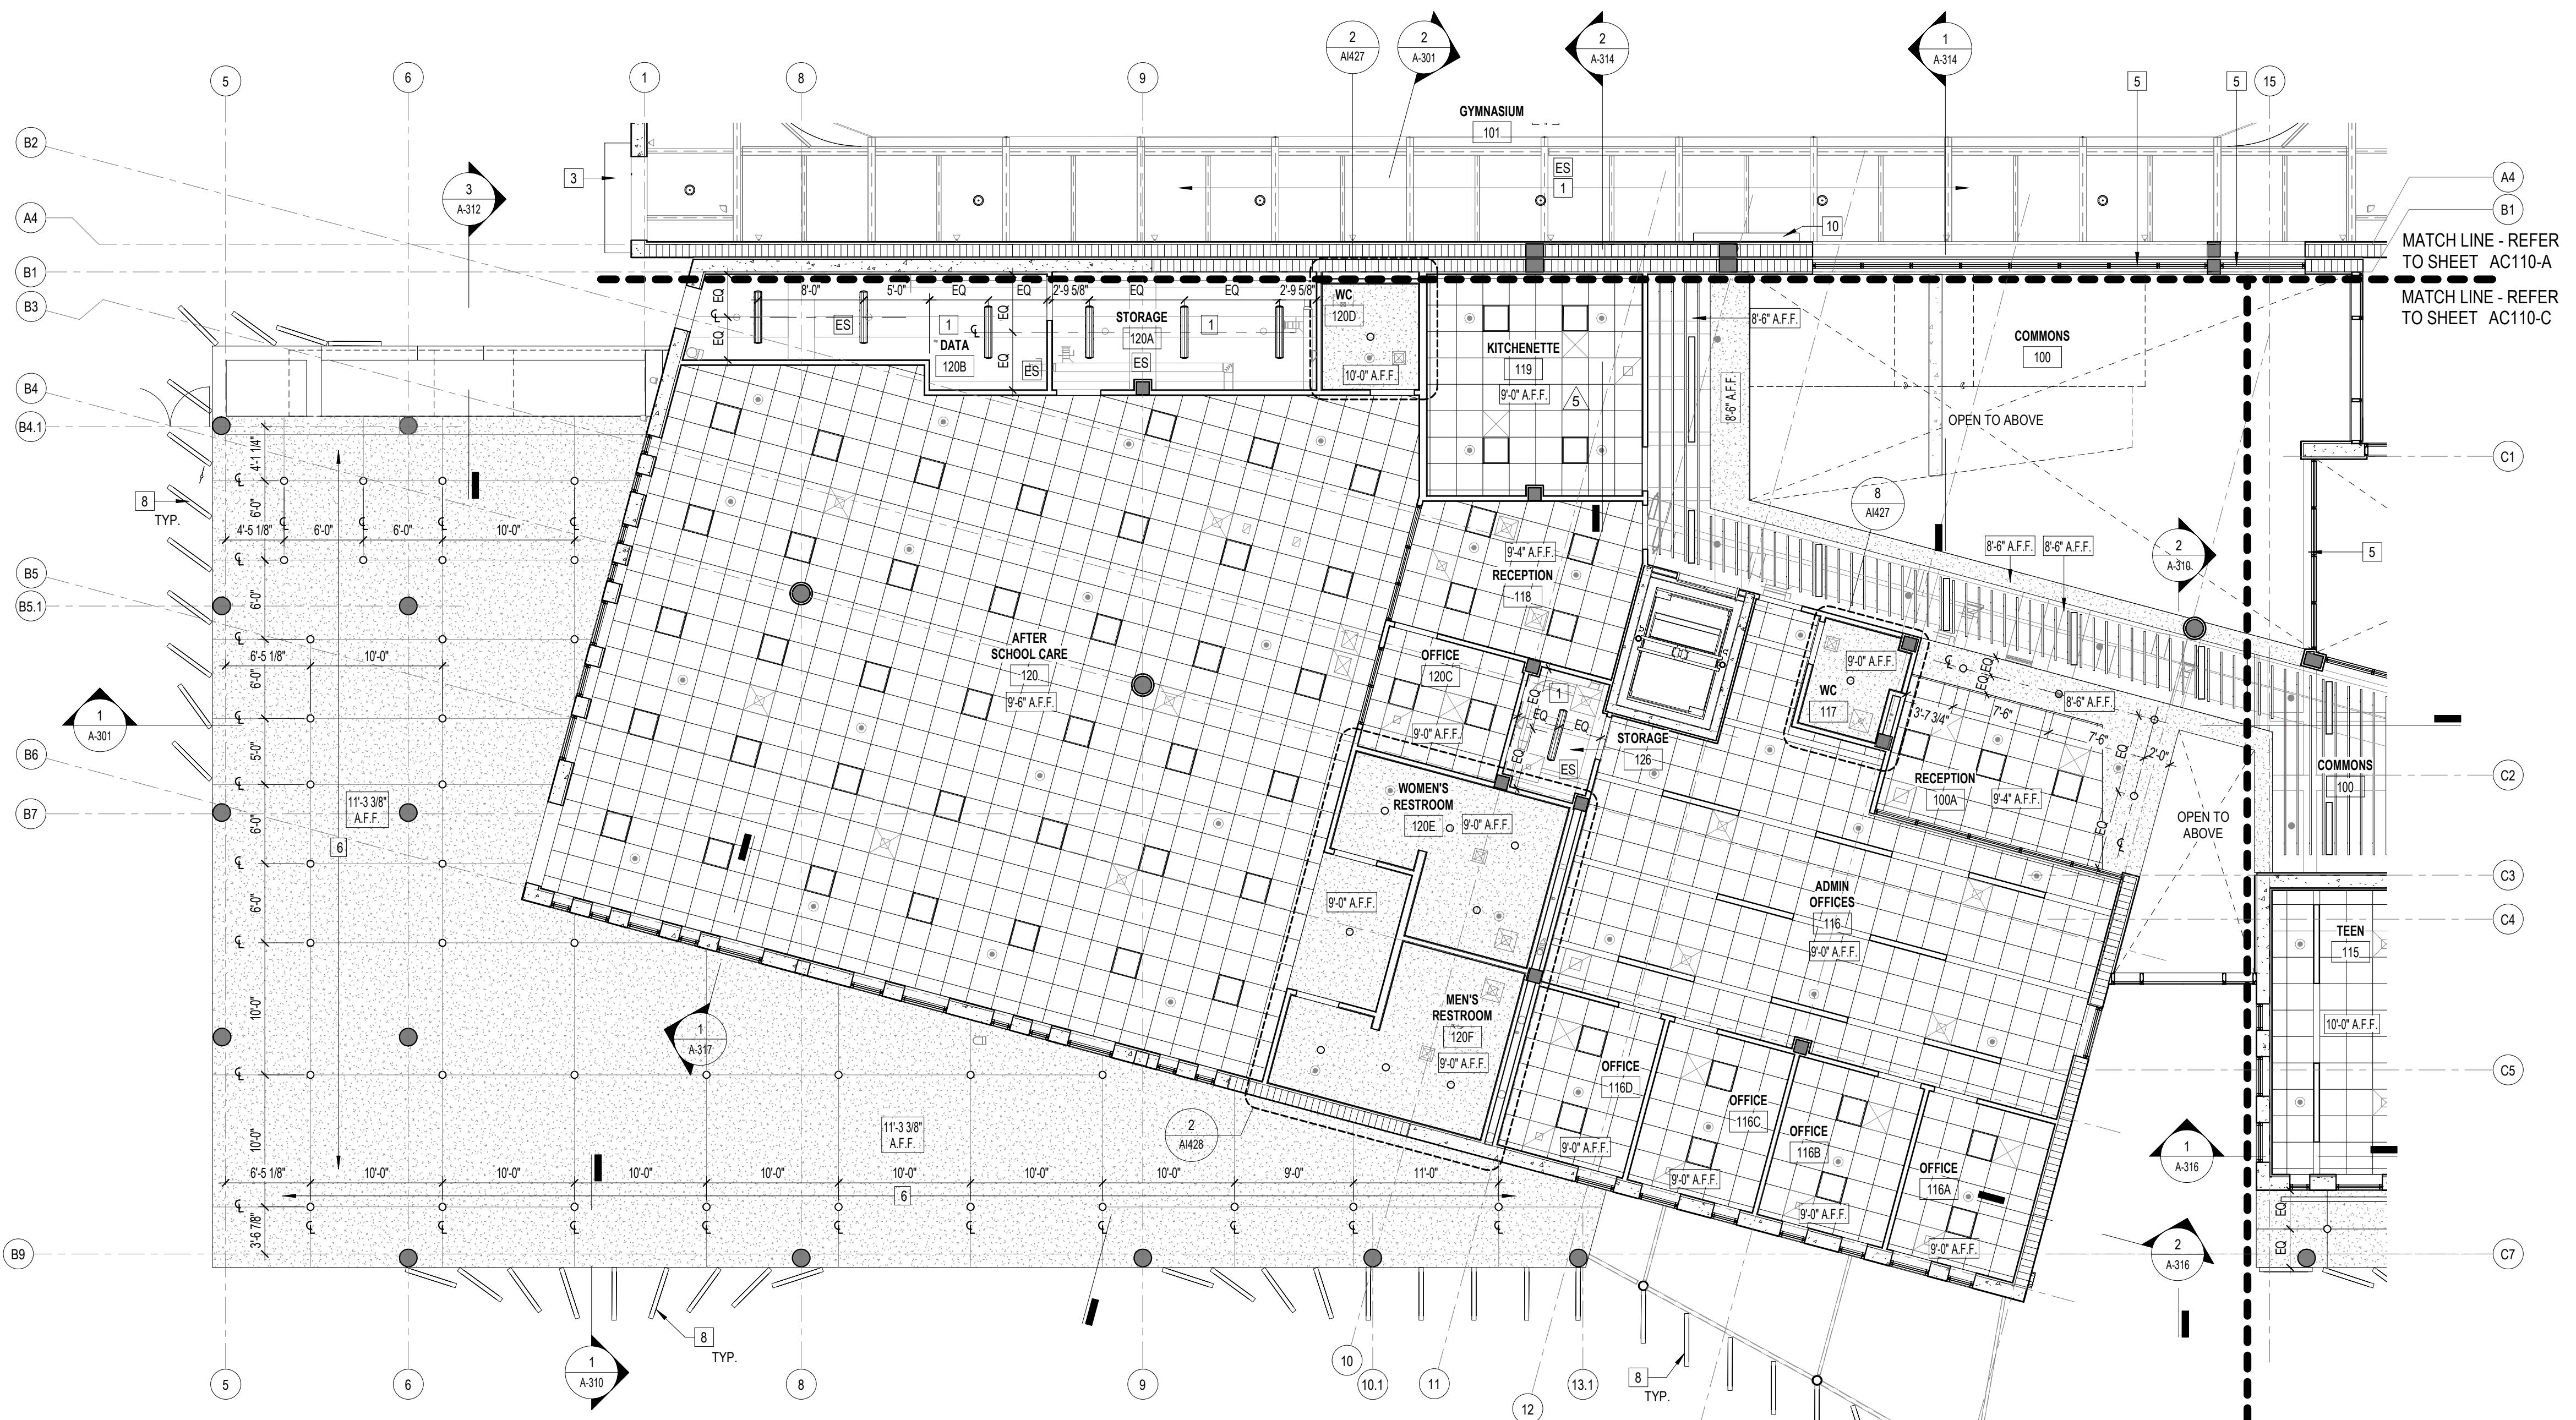


REFLECTED CEILING PLAN - GROUND LEVEL (AREA B)

Scale: 1/8" = 1'-0"

GENERAL NOTES	
A.	PROJECT REFERENCE ELEVATION 0'-0" = N.A.V.D. 18.10'
B.	ALL SPOT ELEVATIONS REFER TO CEILING HEIGHT ABOVE FLOOR LEVEL, BELOW.
C.	REFERENCE CEILING FIXTURES, ENGINEERING DOCUMENTS FOR ALL LIGHT FIXTURE LOCATIONS, SPECIFICATIONS, AND INFORMATION.
D.	REFERENCE MECHANICAL ENGINEERING DOCUMENTS FOR ALL DIFFUSERS AND RETURN AIR GRILLE LOCATIONS, INFORMATION AND SPECIFICATIONS.
E.	REFERENCE FIRE ALARM DOCUMENTS FOR ALL CEILING MOUNTED FIRE ALARM LOCATIONS, INFORMATION, AND SPECIFICATIONS. INCLUDES ANY BDA DEVICES.
F.	REFERENCE FIRE SPRINKLER PROTECTION PLAN AND SHOP DRAWINGS FOR FIRE SPRINKLER DEVICES, HEADS, AND LOCATIONS.
G.	PROVIDE ACOUSTICAL INSULATION ABOVE ALL ENCLOSED HARD CEILING.
H.	PROVIDE ALL SHOWERS AND LOCKER ROOM CEILINGS WITH PAPERLESS MOULURE RESISTANT BOARD. TYPICAL FOR ALL CEILINGS, SCREWS, AND NAILS.
I.	PAINT EXPOSED STRUCTURES AT GYMNASIUM, AND MAIN CORRIDOR/PLATE SW 9179 ANCHOR AWEIGH INCLUDE PAINTING OF ALL CONDUITS, PIPES, DUCT WORK, OR EXPOSED ELEMENTS.
J.	ALL HARD CEILINGS TO BE PAINTED TO MATCH DECOR.
K.	NO COMBUSTIBLE MATERIALS ALLOWED IN CONCEALED SPACES.
L.	TRIMS FOR ALL FIXTURES, SPEAKERS, DIFFUSERS TO MATCH CEILING COLOR FINISH. DO NOT PAINT ON SITE; ALL PAINTED BY MANUFACTURER OR SHOP.
M.	PROVIDE FIRE RATED WIRE SUSPENSION FOR ALL ACOUSTICAL SYSTEMS.
N.	REFERENCE ENGINEERING PLANS FOR ALL CEILING MOUNTED MOTION SENSOR DEVICES. COLOR TO MATCH CEILING COLOR AND DECOR.
O.	ALL PENDANT MOUNTED FIXTURES HAVE MINIMUM 9 A.F.F. DO NOT MOUNT LOWER TO AVOID KIDS HITTING THEM, ETC.
P.	PROVIDE ACCESS PANELS AT ALL REQUIRED LOCATIONS. CONTRA VALVES, TESTING DEVICES, OR REQUIRED ACCESS FOR ABOVE MOUNTED CEILING EQUIPMENT. MIN. SIZE 2'x2' OR LARGER WHERE REQUIRED TO ACCESS A/C UNITS OR FILTERS. PROVIDED AND INSTALLED BY GENERAL CONTRACTOR. REFERENCE ALL ENGINEERING AND SHOP DRAWINGS. PROVIDE WHERE REQUIRED.
Q.	ALL ACCESS PANELS TO BE METAL COLOR TO MATCH DECOR.
R.	AREAS WHERE BAFFLES OR ACOUSTICAL PANELS ARE LOCATED BELOW A/C UNITS OR AREA WITH NEED OF ACCESS PROVIDE SUSPENSION SYSTEM OR MOUNTING CAPABLE OF BEING REMOVED FOR ACCESS.
S.	PROVIDE 1 HR RATED SPRAY FIRE PROOFING TO UNDERSIDE OF ROOF DECK.
T.	PROVIDE SPRAY-APPLIED FIRE RESISTANT MATERIAL TO ALL INTERIOR DECK AND STEEL BEAMS.

REFLECTED CEILING PLAN LEGEND

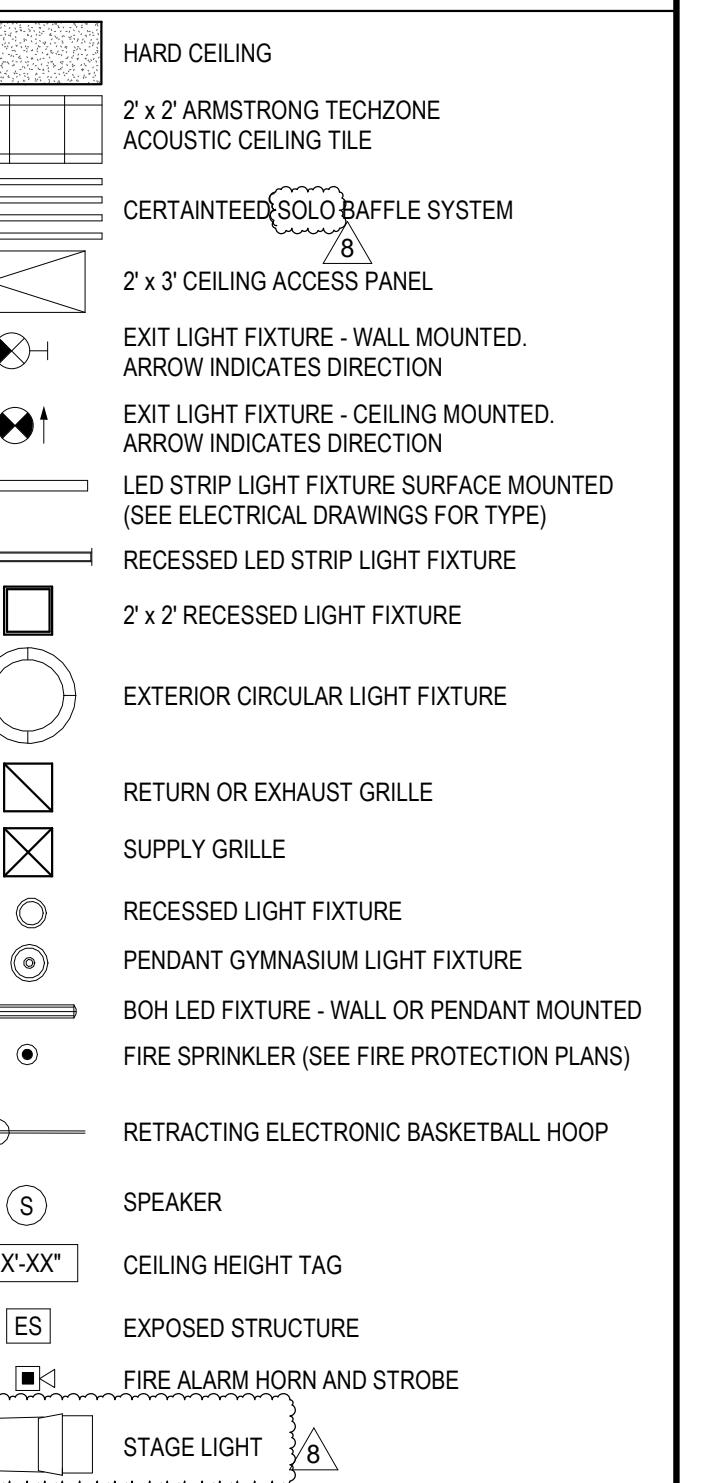

REFLECTED CEILING PLAN KEY NOTES

1. EXPOSED STRUCTURE AND EXPOSED CEILING ELEMENTS TO BE PAINTED FLAT SW 9179 ANCHOR AWEIGH.
2. RETRACTING ELECTRONIC BASKETBALL HOOP HUNG AND BRACED FROM ROOF FRAMING ABOVE (TYP. OF #6 (SEE STRUCTURAL DOCUMENTS).
3. PRE-FABRICATED ALUMINUM CANOPY BY SPECIALTY ENGINEER; SEE PRODUCT APPROVAL CERTIFICATION PRIOR TO INSTALLATION.
4. EXTERIOR SHOWERS.
5. AUTOMATIC SPRINKLERS TO PROVIDE 1-HR FIRE RATING ALONG BOTH SIDES OF STOREFRONT STUCCO HARD CEILING, NOT USED.
6. SUN SCREENS MECHANICALLY FASTENED TO SIDE OF BUILDING CONTINUOUS VENT.
7. ELECTRONIC SCOREBOARD, NEVCO - MODEL 2750 MPCW (TYP. OF 4).
8. GYMNASIUM DIVIDER CURTAIN.

CONFORMED SET 09/22/2025

TITLE: GROUND LEVEL REFLECTED CEILING PLAN - AREA B

DATE: Dec 27, 2022


DRAWN BY: SV, CC, FE, LS

CHECKED BY: JBL, LS, JS


JOB NO: 2122


SHEET:

AC110-B

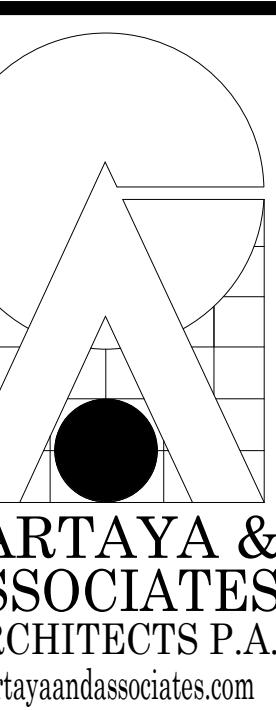2400 E. COMMERCIAL BLVD. SUITE 201
FT. LAUDERDALE, FLORIDA 33308
954-771-2724SEAL:
AA C001388

ALL DESIGN AND DATA IS OWNERSHIP RESERVED BY THIS DRAWING. THIS DRAWING IS FOR THE USE AND INFORMATION CONCERNING THE PROJECT ONLY. THE CONTRACTOR SHALL VERIFY ALL EXISTING CONDITIONS AND DIMENSIONS. THE CONTRACTOR SHALL NOT MAKE ANY CHANGES TO THE DRAWINGS WITHOUT THE WRITTEN CONSENT OF THE OWNER. THE CONTRACTOR PLEADS TO THE EXERCISE OF DUE CARE IN THE USE OF THESE DRAWINGS.

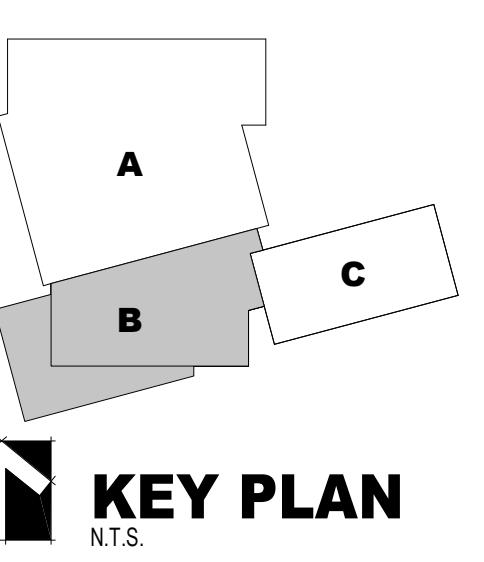PROJECT: CITY OF DELRAY BEACH
POMPEY PARK REC CENTER
1101 NW 2ND ST. DELRAY BEACH
FL 33444REVISIONS:
5 03-09-2023 BD COMMENTS
8 09-22-2025 CONFORMED SETKEY PLAN
N.T.S.

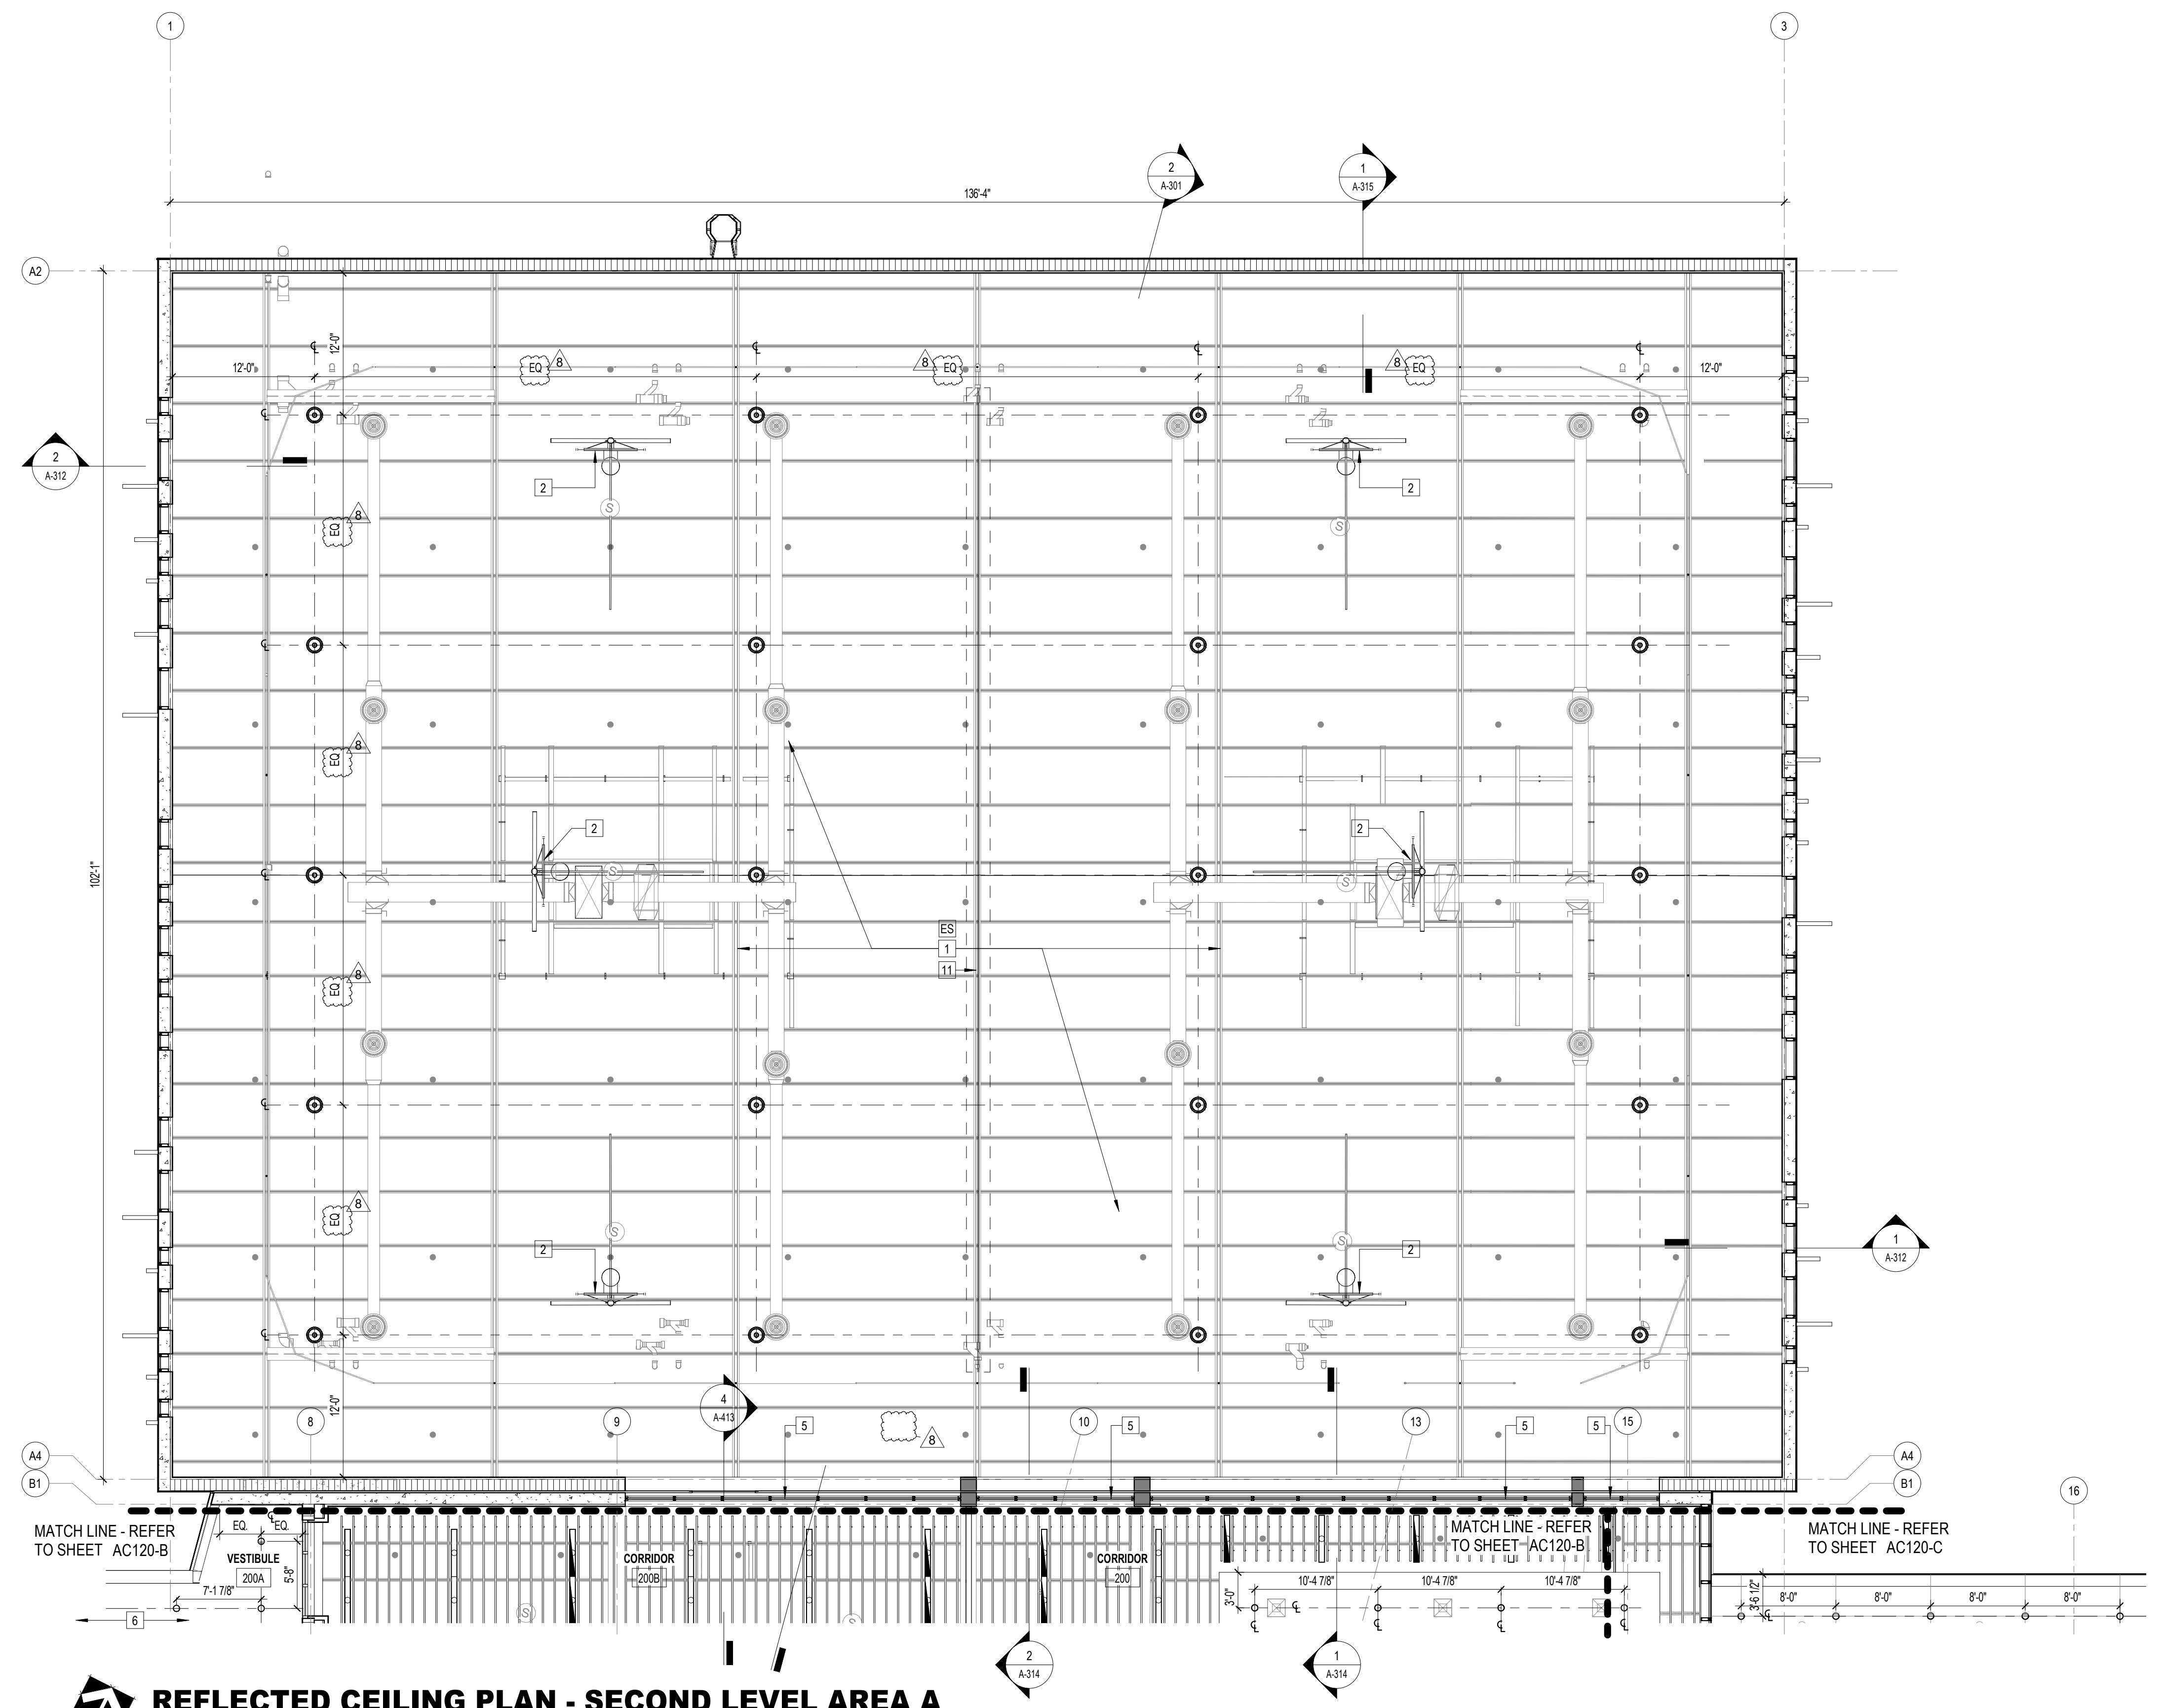

REFLECTED CEILING PLAN - SECOND LEVEL AREA A
Scale: 1/8" = 11.2"

Scale: 1/8" =

GENERAL NOTES

ENCE ELEVATION 0'-0" = N.A.V.D. 18.10'
TIONS REFER TO CEILING HEIGHT ABOVE
LEVEL BELOW.

CTRICAL ENGINEERING DOCUMENTS FOR ALL
OCATIONS, SPECIFICATIONS, AND INFORMATION.
CHANICAL ENGINEERING DOCUMENTS FOR ALL
RETURN AIR GRILLE LOCATIONS, INFORMATION
IONS.

E ALARM DOCUMENTS FOR ALL CEILING
ALARM LOCATIONS, INFORMATION, AND
. INCLUDES ANY BDA DEVICES.

E SPRINKLER PROTECTION PLAN AND SHOP
FIRE SPRINKLER DEVICES, HEADS, AND

TICAL INSULATION ABOVE ALL ENCLOSED HARD
8
OWERS AND LOCKER ROOM CEILINGS WITH
TURE RESISTANT BOARD. TYPICAL FOR ALL
SOFFITS, AND WALLS.

STRUCTURES AT GYMNASIUM, AND MAIN
SW 9179 ANCHOR AWEIGH; INCLUDE PAINTING
S, PIPES, DUCT WORK, OR EXPOSED ELEMENTS.
GS TO BE PAINTED TO MATCH DECOR.

E MATERIALS ALLOWED IN CONCEALED SPACES.
IXTURES, SPEAKERS, DIFFUSERS TO MATCH
FINISH. DO NOT PAINT ON SITE, ALL PAINTED BY
OR SHOP.

ATED WIRE SUSPENSION FOR ALL ACOUSTICAL

ENGINEERING PLANS FOR ALL CEILING MOUNTED
R DEVICES. COLOR TO MATCH CEILING COLOR

OUNTED FIXTURES HAVE MINIMUM 9' A.F.F.L. DO
VER TO AVOID KIDS HITTING THEM, ETC.

S PANELS AT ALL REQUIRED LOCATIONS,
S, TESTING DEVICES, OR REQUIRED ACCESS
NTED CEILING EQUIPMENT. MIN. SIZE 2'X2' OR
REQUIRED TO ACCESS A/C UNITS OR FILTERS.
INSTALLED BY GENERAL CONTRACTOR.

ENGINEERING AND SHOP DRAWINGS. PROVIDE
ED.

ELS TO BE METAL COLOR TO MATCH DECOR.
AFFLES OR ACOUSTICAL PANELS ARE LOCATED
S OR AREA WITH NEED OF ACCESS PROVIDE
STEM OR MOUNTING CAPABLE OF BEING
CCESS.

ATED SPRAY FIRE PROOFING TO UNDERSIDE OF

APPLIED FIRE RESISTANT MATERIAL TO ALL
AND STEEL BEAMS

2400 E. COMMERCIAL BLVD. SUITE 201
FT. LAUDERDALE, FLORIDA 33308
954-771-2724

SEAL:

THIS IS THE
MISSION FROM
DIMENSIONS
OF A MISSIONIC

**CITY OF DELRAY BEACH
POMPEY PARK REC CENTER
1101 NW 2ND ST, DELRAY BEACH
FL 33444**

PROJECT:	
VISIONS:	
20-2023	BD COMMENTS
09-2024	REVISION
22-2025	CONFORMED SET

DATE: Dec 27, 2022
DRAWN BY: SV, CC, EEE
CHECKED BY: JJ, LS, JS

TITLE: SECON
CEILING

JOB NO: 2122

SHEET:
AC120-A

ED CEILING PLAN LEGEND

ARD CEILING

x 2' ARMSTRONG TECHZONE
COUSTIC CEILING TILE

ERTAINTEED SOLO BAFFLE SYSTEM


x 3' CEILING ACCESS PANEL

KIT LIGHT FIXTURE - WALL MOUNTED.
RROW INDICATES DIRECTION

KIT LIGHT FIXTURE - CEILING MOUNTED.
RROW INDICATES DIRECTION

ED STRIP LIGHT FIXTURE SURFACE MOUNTED
(SEE ELECTRICAL DRAWINGS FOR TYPE)

ECESSED LED STRIP LIGHT FIXTURE

x 2' RECESSED LIGHT FIXTURE

TERIOR CIRCULAR LIGHT FIXTURE

TURN OR EXHAUST GRILLE

UPPLY GRILLE

ECESSED LIGHT FIXTURE

ENDANT GYMNASIUM LIGHT FIXTURE

OH LED FIXTURE - WALL OR PENDANT MOUNTED
RE SPRINKLER (SEE FIRE PROTECTION PLANS)

TRACTING ELECTRONIC BASKETBALL HOOP

PEAKER

EILING HEIGHT TAG

XPOSED STRUCTURE

RE ALARM HORN AND STROBE


AGE LIGHT


CEILING PLAN KEY NOTES

STRUCTURE AND EXPOSED CEILING ELEMENTS TO BE
W 9179 ANCHOR AWEIGH / 8

ELECTRONIC BASKETBALL HOOP HUNG AND
ROOF FRAMING ABOVE (TYP. OF 6) (SEE
DOCUMENTS)

ALUMINUM CANOPY BY SPECIALTY ENGINEER.
T APPROVAL CERTIFICATION PRIOR TO

VERS

INKLERS TO PROVIDE 1-HR FIRE RATING ALONG
STOREFRONT

EILING

MECHANICALLY FASTENED TO SIDE OF BUILDING
NT

OREBOARD, NEVCO - MODEL 2750 MPCW (TYP.)


DER CURTAIN

The diagram consists of three irregularly shaped regions labeled A, B, and C. Region A is a large gray polygon in the upper-left quadrant. Region B is a white polygon with black outlines, located below and to the left of A. Region C is a white polygon with black outlines, located below and to the right of A. The regions overlap in a complex, non-contiguous manner.




KEY PLAN

N.T.S.

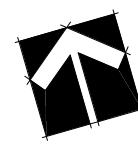

REFLECTED CEILING PLAN - SECOND LEVEL (AREA C)

Scale: 1/8" = 1'-0"

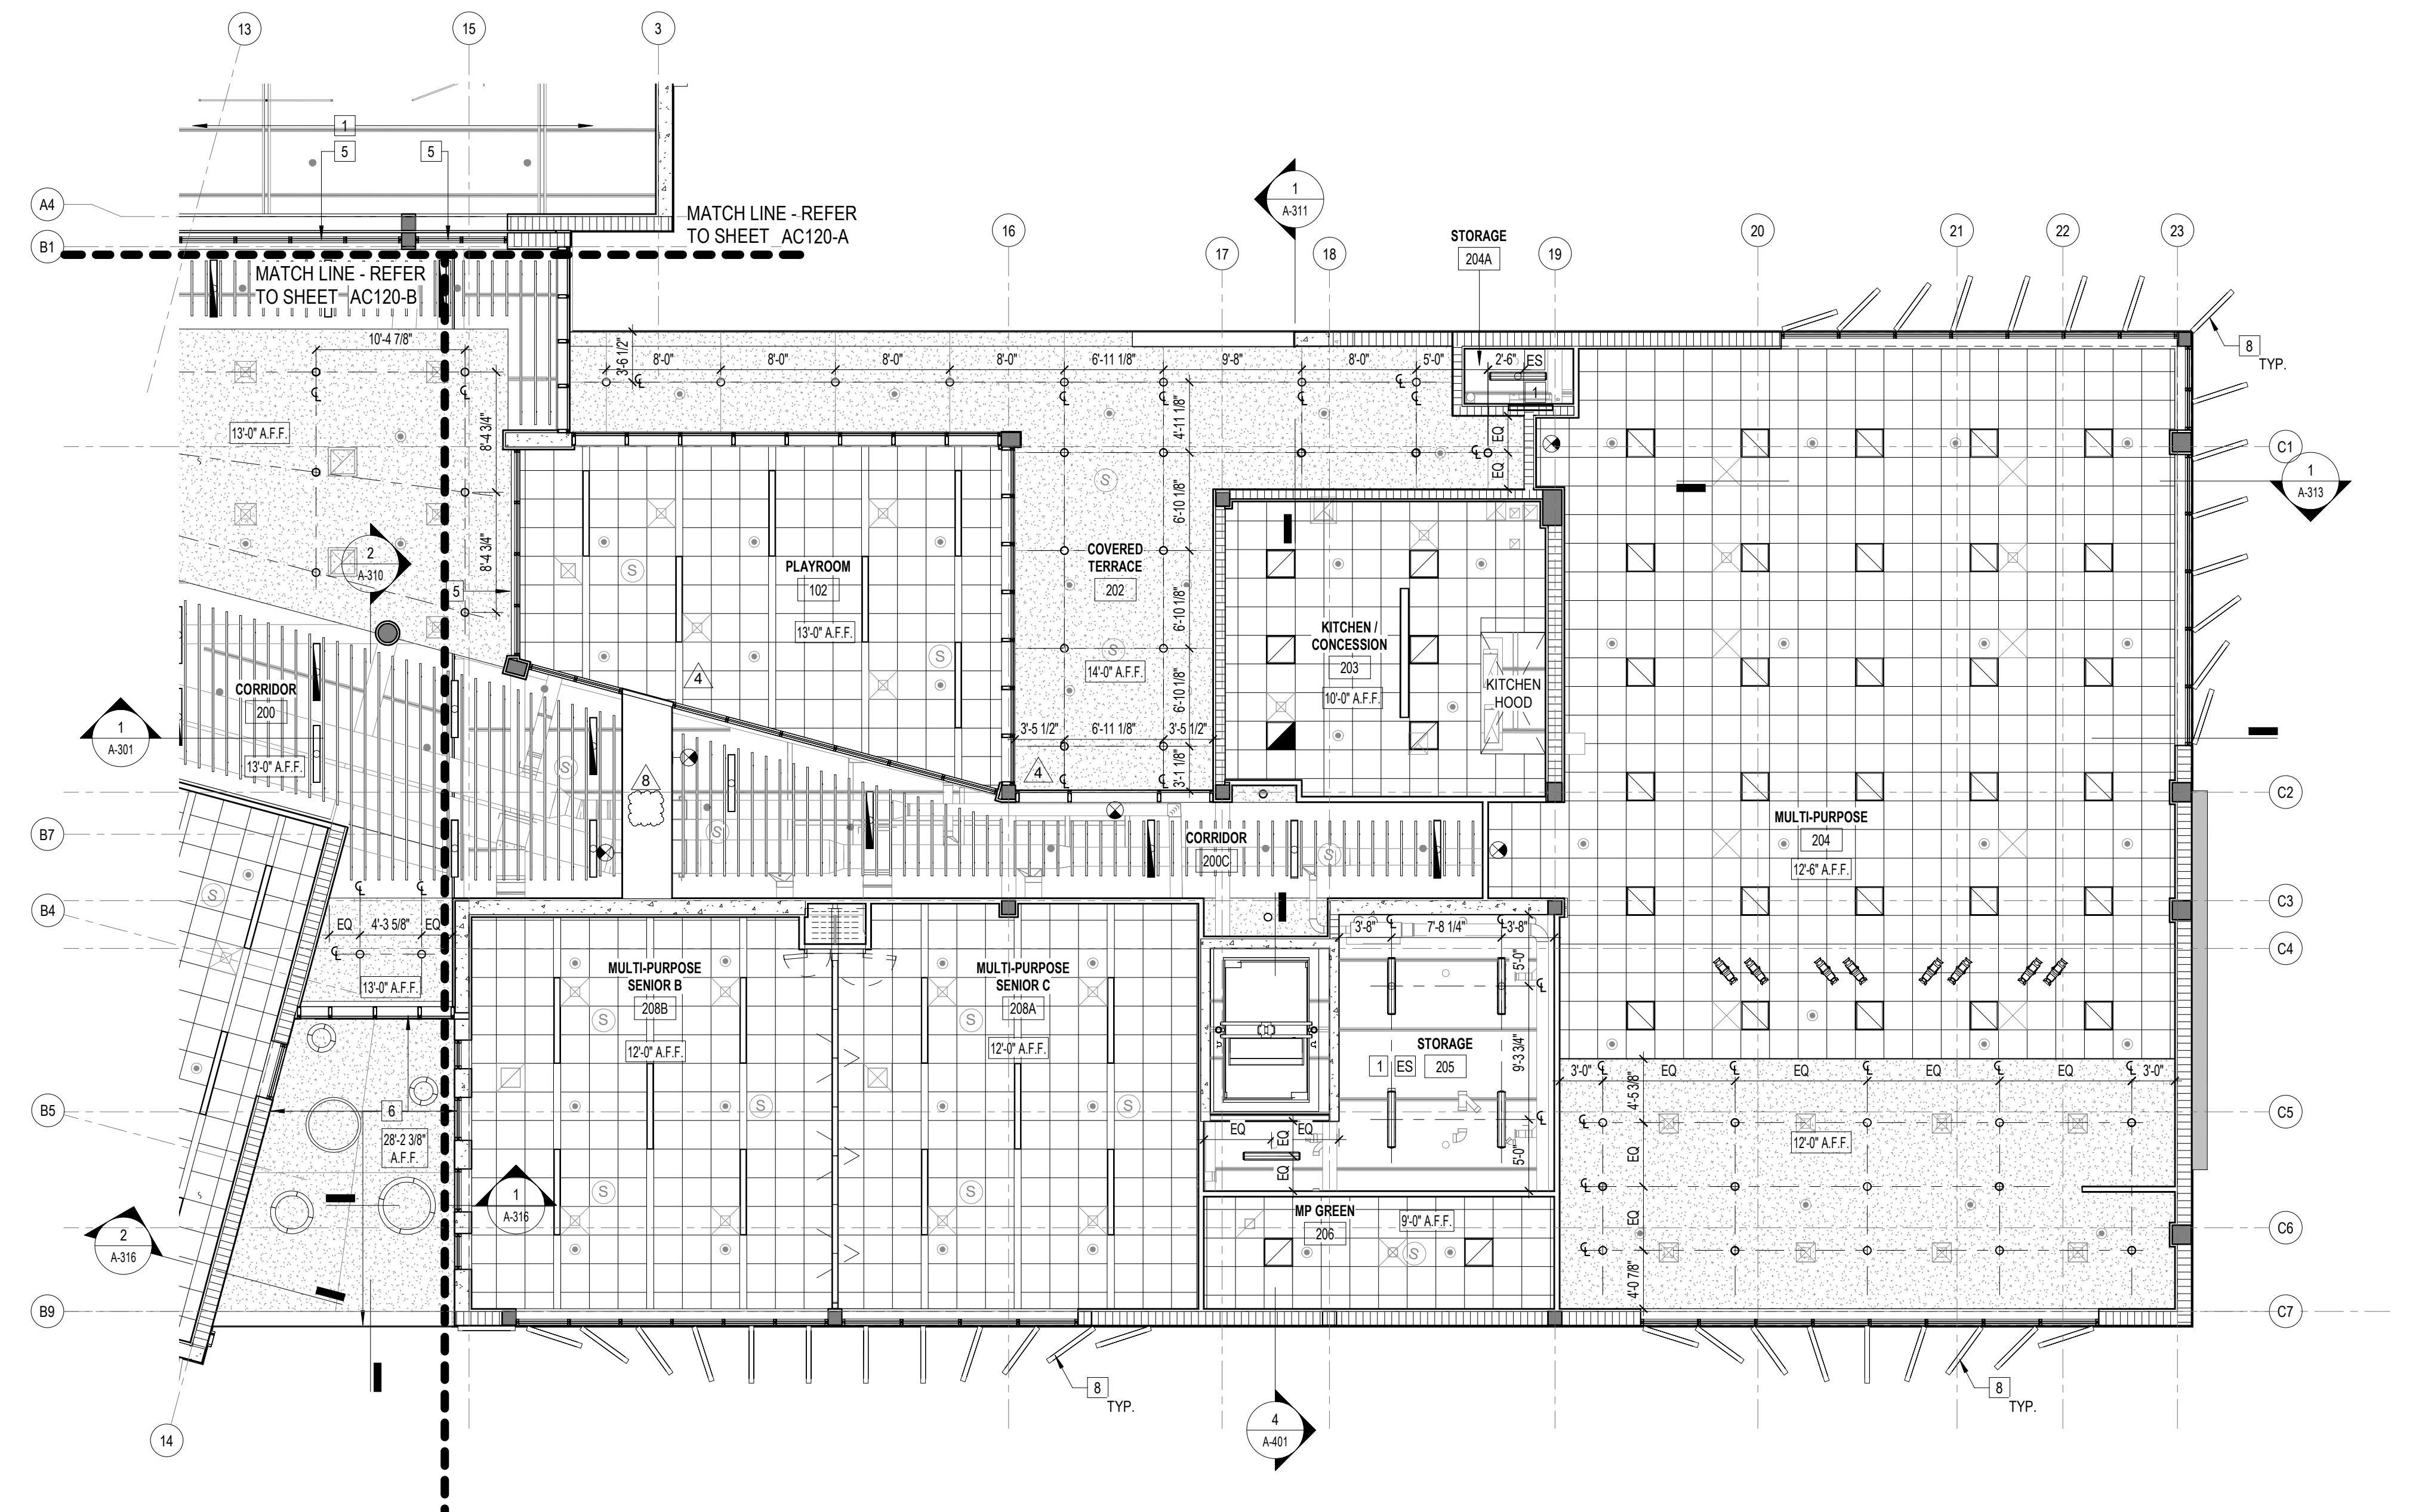

GENERAL NOTES

REFERENCE ELEVATION 0'-0" = N.A.V.D. 18.10' ELEVATIONS REFER TO CEILING HEIGHT ABOVE FLOOR LEVEL BELOW.

ELECTRICAL ENGINEERING DOCUMENTS FOR ALL RE LOCATIONS, SPECIFICATIONS, AND INFORMATION. MECHANICAL ENGINEERING DOCUMENTS FOR ALL INLET AND RETURN AIR GRILLE LOCATIONS, INFORMATION CATIONS.

FIRE ALARM DOCUMENTS FOR ALL CEILING RE ALARM LOCATIONS, INFORMATION, AND ONS. INCLUDES ANY BDA DEVICES.

FIRE SPRINKLER PROTECTION PLAN AND SHOP FOR FIRE SPRINKLER DEVICES, HEADS, AND

ACOUSTICAL INSULATION ABOVE ALL ENCLOSED HARD
SHOWERS AND LOCKER ROOM CEILINGS WITH
MOISTURE RESISTANT BOARD. TYPICAL FOR ALL
GS, SOFFITS, AND WALLS.

SED STRUCTURES AT GYMNASIUM, AND MAIN
AT SW 9179 ANCHOR AWEIGH; INCLUDE PAINTING
OUTS, PIPES, DUCT WORK, OR EXPOSED ELEMENTS.
ELINGS TO BE PAINTED TO MATCH DECOR.

TABLE MATERIALS ALLOWED IN CONCEALED SPACES.
ALL FIXTURES, SPEAKERS, DIFFUSERS TO MATCH
OR FINISH. DO NOT PAINT ON SITE, ALL PAINTED BY
ER OR SHOP.

E RATED WIRE SUSPENSION FOR ALL ACOUSTICAL

ENGINEERING PLANS FOR ALL CEILING MOUNTED FLOOR DEVICES. COLOR TO MATCH CEILING COLOR

CEILING MOUNTED FIXTURES HAVE MINIMUM 9' A.F.F.L. DO LOWER TO AVOID KIDS HITTING THEM, ETC.

ACCESS PANELS AT ALL REQUIRED LOCATIONS, VALVES, TESTING DEVICES, OR REQUIRED ACCESS MOUNTED CEILING EQUIPMENT. MIN. SIZE 2'X2' OR WHERE REQUIRED TO ACCESS A/C UNITS OR FILTERS. AND INSTALLED BY GENERAL CONTRACTOR.


ALL ENGINEERING AND SHOP DRAWINGS. PROVIDE REQUIRED.

PANELS TO BE METAL COLOR TO MATCH DECOR. WHERE BAFFLES OR ACOUSTICAL PANELS ARE LOCATED UNITS OR AREA WITH NEED OF ACCESS PROVIDE A SYSTEM OR MOUNTING CAPABLE OF BEING FOR ACCESS.

E RATED SPRAY FIRE PROOFING TO UNDERSIDE OF

RAY-APPLIED FIRE RESISTANT MATERIAL TO ALL BLACK AND STEEL BEAMS

REFLECTED CEILING PLAN LEGEND

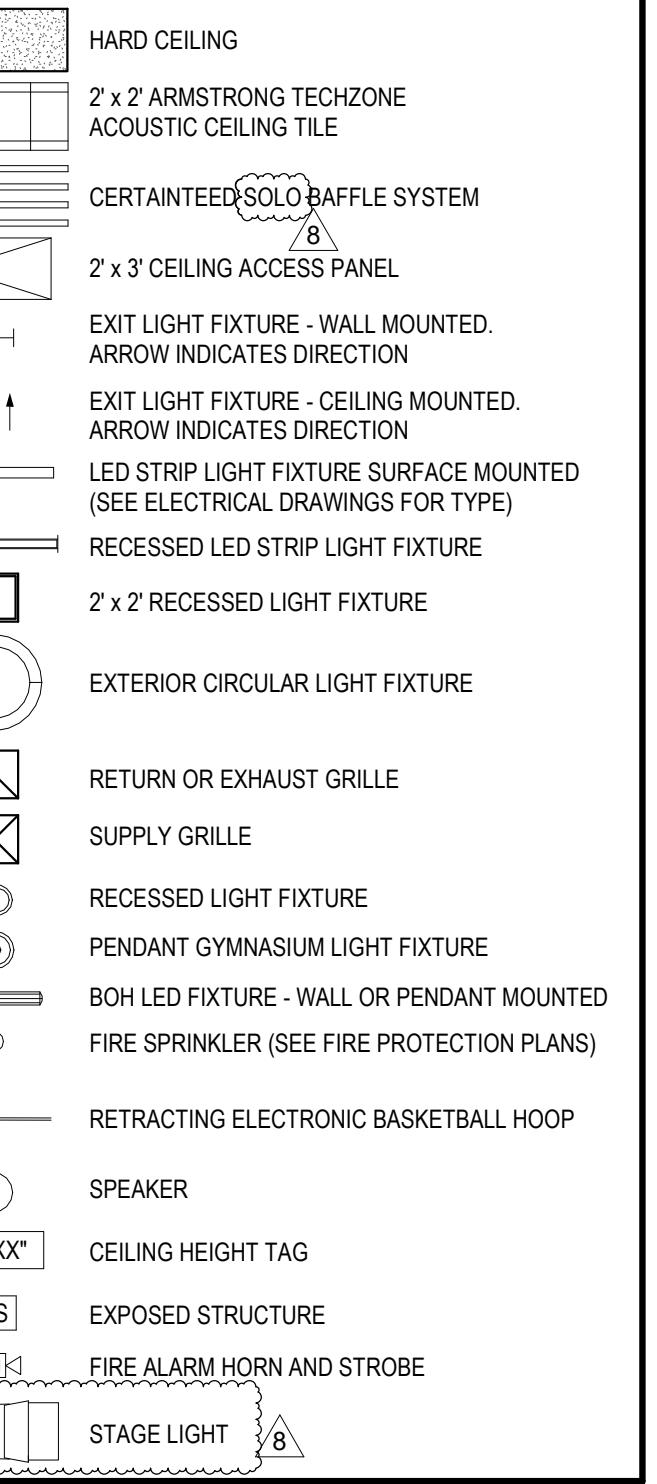

SELECTED CEILING PLAN KEY NOTES

STRUCTURE AND EXPOSED CEILING ELEMENTS TO BE
ED FLAT SW 9179 ANCHOR AWEIGH 8
ACTING ELECTRONIC BASKETBALL HOOP HUNG AND
ED FROM ROOF FRAMING ABOVE (TYP. OF 6) (SEE
CTURAL DOCUMENTS)

ABRICATED ALUMINUM CANOPY BY SPECIALTY ENGINEER,
IT PRODUCT APPROVAL CERTIFICATION PRIOR TO
LLATION

RIOR SHOWERS

MATIC SPRINKLERS TO PROVIDE 1-HR FIRE RATING ALONG
SIDES OF STOREFRONT

CO HARD CEILING

SED

SCREENS MECHANICALLY FASTENED TO SIDE OF BUILDING
NUOUS VENT

TRONIC SCOREBOARD, NEVCO - MODEL 2750 MPCW (TYP.)

ASIUM DIVIDER CURTAIN

TITLE: SECOND I EVENT REET ECT
CONFIRMED DATE: 03/12/2023

PFEI EFFECTS

ED SEI US
INDI EVER

CONFIRM

SH
A

0-2023 BD COMMENTS
9-2024 REVISION

4 03-2

- 5 -

SELECT
FACE

L'EST
- AR

LEV
DTAN

LUNG

卷二

145

MEET





KEY PLAN

N.T.S.