


5

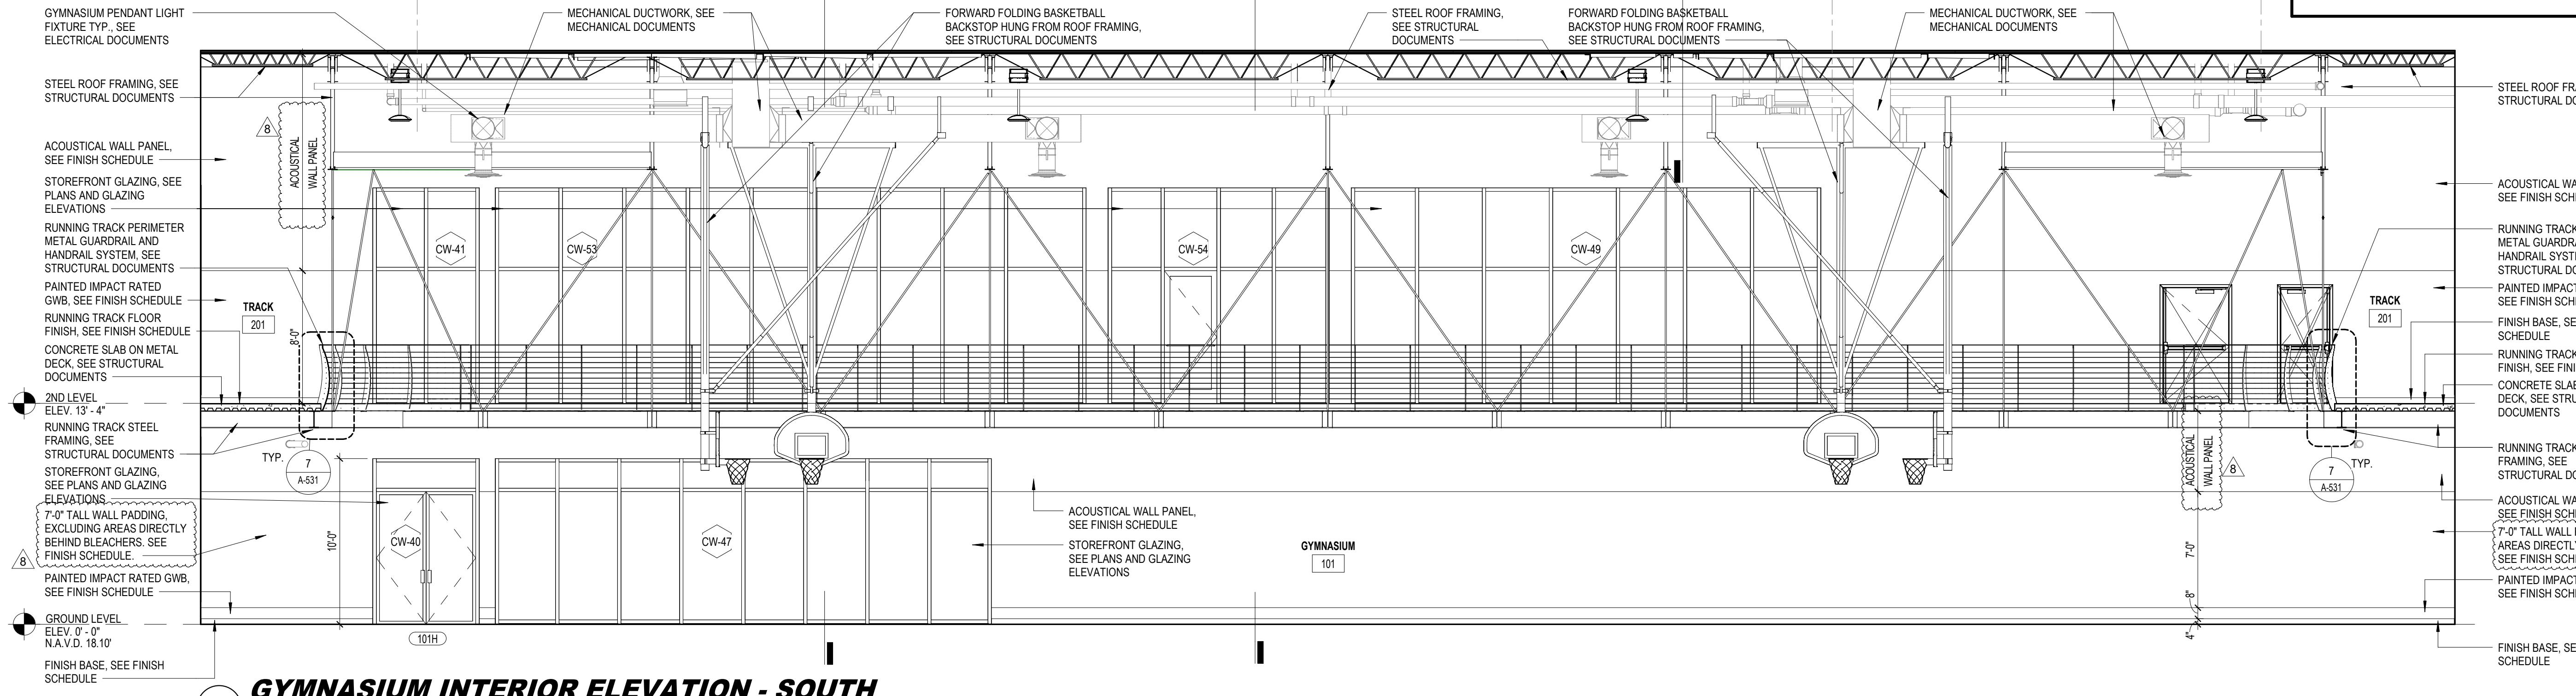

GYMNASIUM INTERIOR ELEVATION - SOUTH


Scale: 3/16" = 1'-0"

FINISH SCHEDULE NOTES	
1.	GYMNASIUM WALLS TO RECEIVE ACOUSTICAL PANELS ON WALLS.
2.	TYPICAL AT BOTH LEVELS.
3.	ADDITIONAL ACOUSTICAL WALLS AT GYMNASIUM FLOOR LEVEL EXCLUDING AREAS DIRECTLY BEHIND BLEACHERS. AREAS DIRECTLY BEHIND BLEACHERS TO BE PAINTED GYPSUM BOARD.
4.	IMPACT RESISTANT GYPSUM WALL BOARD MIN. 8'-0" THROUGHOUT (TYPICAL) WHERE SPECIFIED IN FINISH SCHEDULE.
5.	PAINT EXPOSED ROOF STRUCTURE ABOVE COLOR FLAT SW9179 - EPOXY PAINT FINISH.
6.	PAINT EXPOSED STRUCTURE IN B.O.H. ROOMS EXCEPT AS NOTED ON THE FINISH SCHEDULE ON SHEET A-640.
7.	ALL EXTERIOR OR NON AC ROOMS TO HAVE M.R. BOARDS OR STUCCO FINISH WITH NON-ABSORBENT PAINT FINISH.
8.	PAPERLESS M.R. GYPSUM WALL BOARD PAINTED WITH NON-ABSORBENT PAINT FINISH FOR ALL INTERIOR RESTROOMS AND LOCKERS.
9.	PAINT ALL EXPOSED CONCRETE CEILINGS WITH NON-ABSORBENT PAINT, COLOR TO MATCH.
10.	MILLWORK FINISH TO BE DEKTON LUNAR, SATIN SMOOTH, MITERED/ROUNDED CORNERS.
11.	CEMENTITIOUS BACKER BOARD SHALL BE USED FOR ALL TILE WALLS.
12.	LOCKERS MANUFACTURED BY PRENCO, COLOR REFLEX BLUE.
13.	3/4" AC GRADE PLYWOOD PAINTED FRONT, BACK AND ALL SIDES WITH FIRE RETARDANT PAINT. PLYWOOD SHALL BE MOUNTED ON ALL WALLS OF THE ROOM, 8' FROM THE FLOOR EXTENDING TO THE CEILING.
14.	REFER TO FLOOR PATTERN LAYOUT.
15.	STAIR SHALL BE TILE FINISH. STEPS SHALL BE LAMBOO DESERT SAND.


































GYMNASIUM INTERIOR ELEVATION - NORTH

Scale: 3/16" = 1'-0"

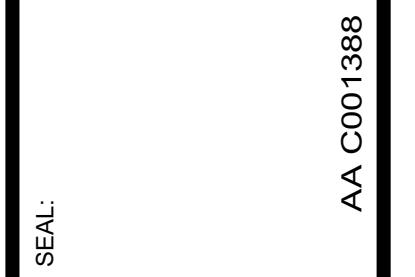
CITY OF DELRAY BEACH
POMPEY PARK REC CENTER
1101 NW 2ND ST, DELRAY BEACH
FL 33444

ALL DESIGN AND DATA IS OWNERS PROPERTY. THIS DRAWING IS THE PROPERTY OF THE CITY OF DELRAY BEACH AND IS FOR THE EXCLUSIVE USE AND CONFIDENCE OF THE CONTRACTOR. THE CONTRACTOR SHALL NOT REPRODUCE, COPY, OR DISTRIBUTE THIS DRAWING IN WHOLE OR IN PART, NOR SHALL HE DISCLOSE THE CONTENTS OF THIS DRAWING TO ANYONE ELSE, UNLESS AUTHORIZED IN WRITING BY THE CITY OF DELRAY BEACH. ANYONE WHO VIOLATES THIS AGREEMENT SHALL BE SUBJECT TO THE PENALTIES PROVIDED FOR IN THE CONTRACT.

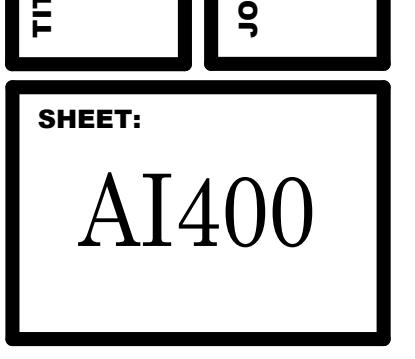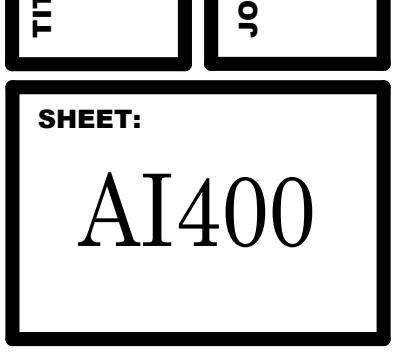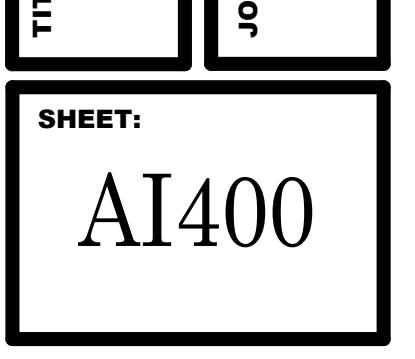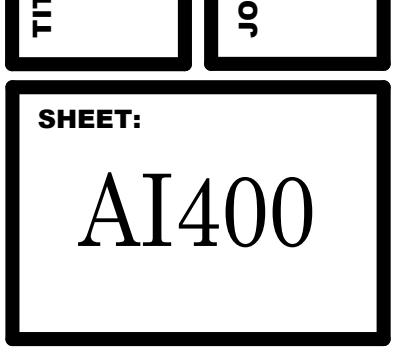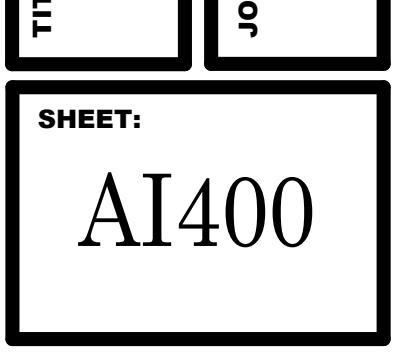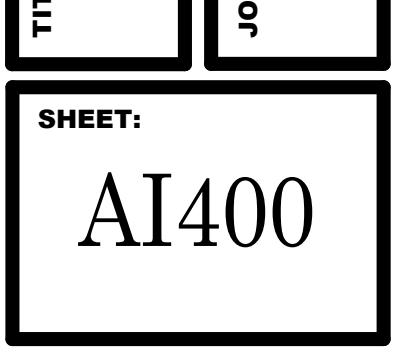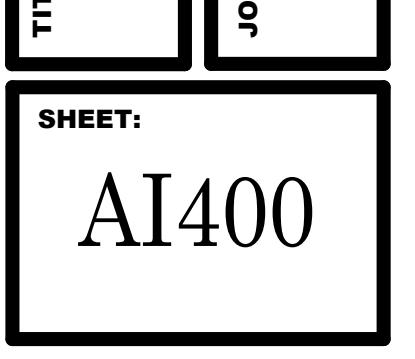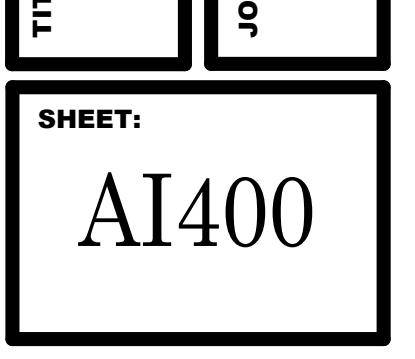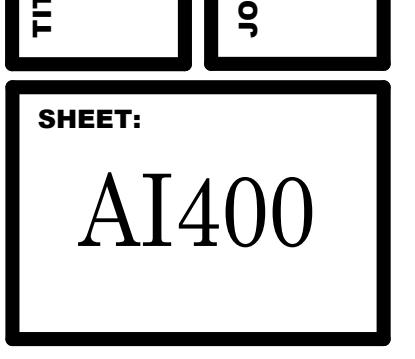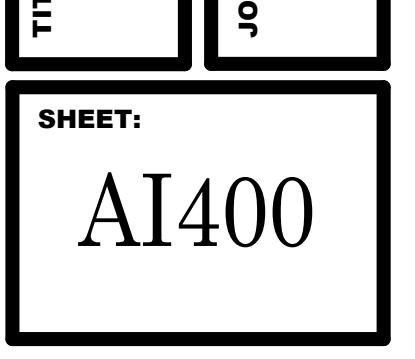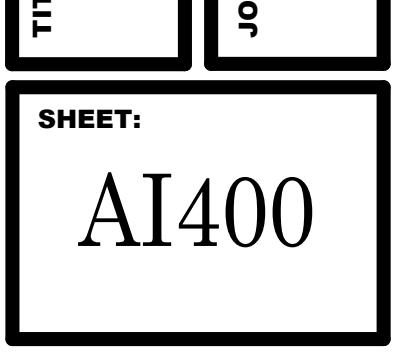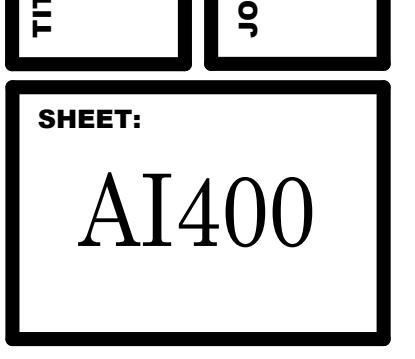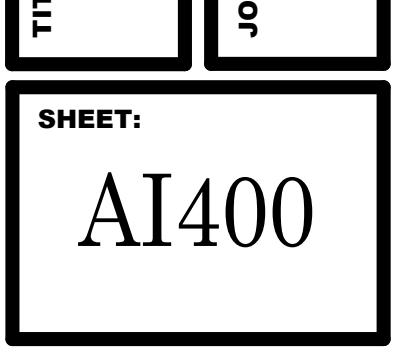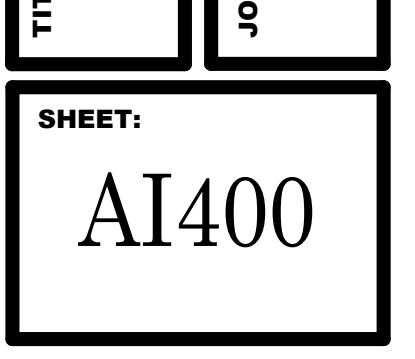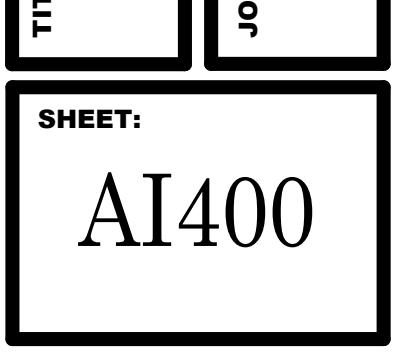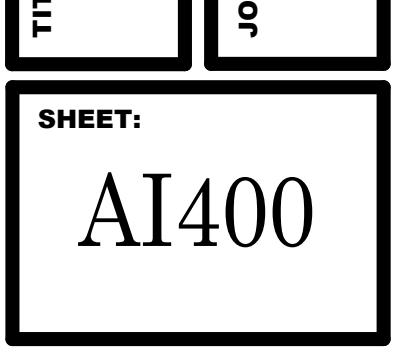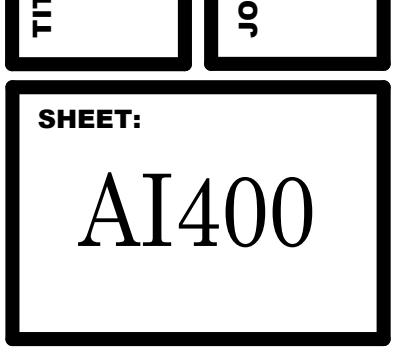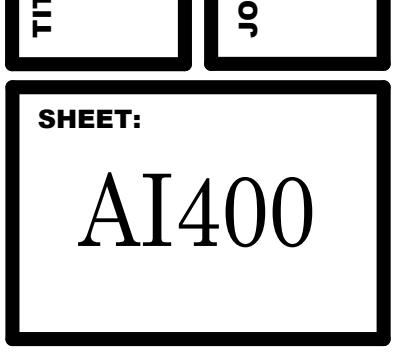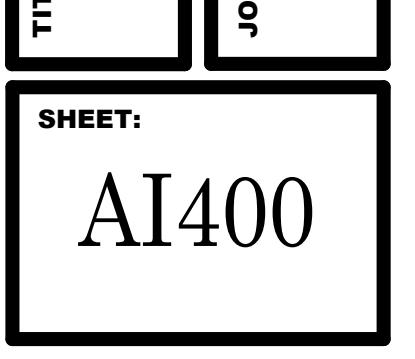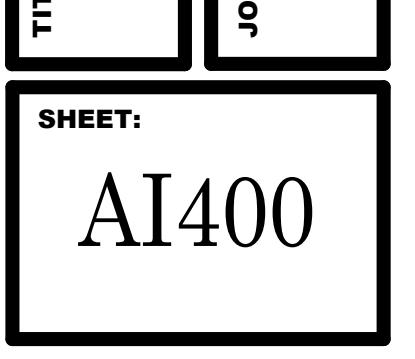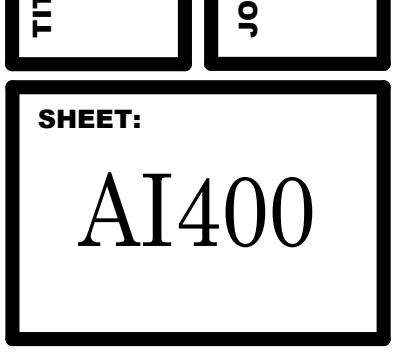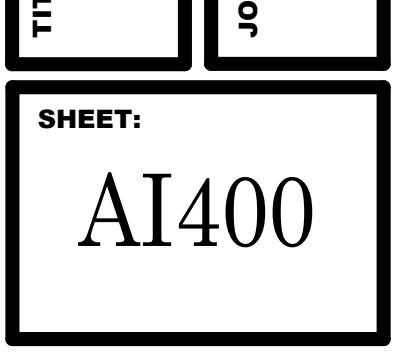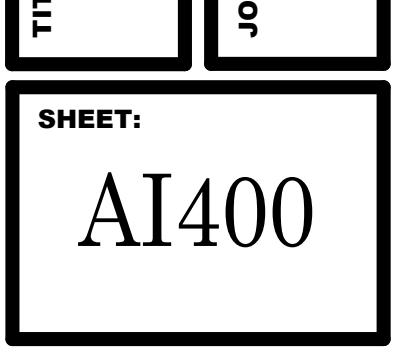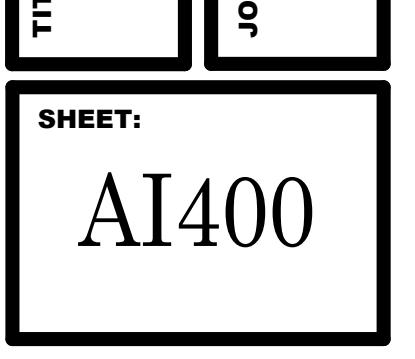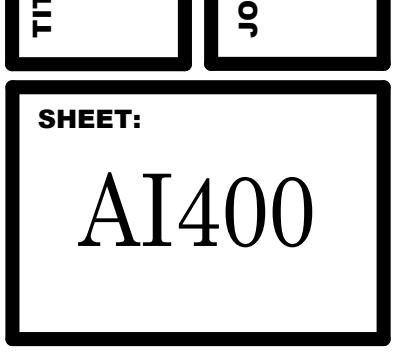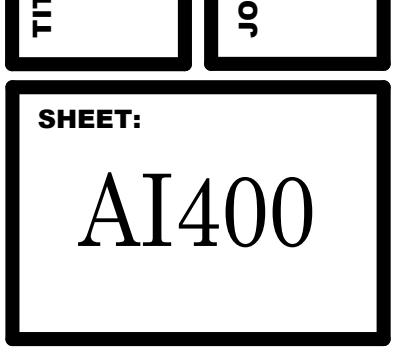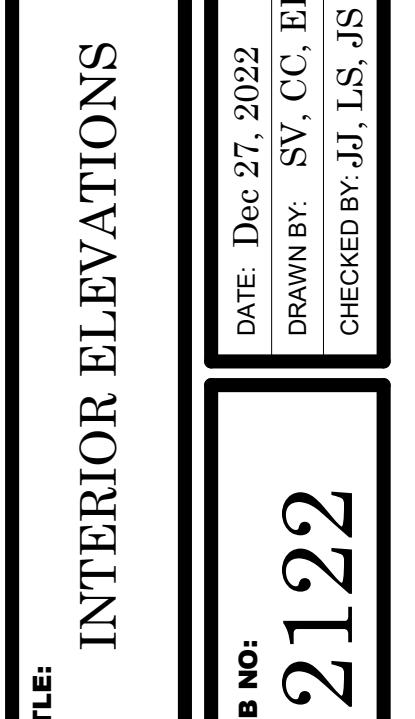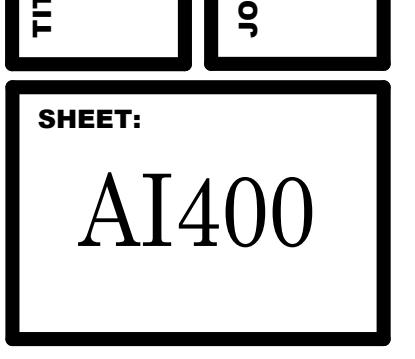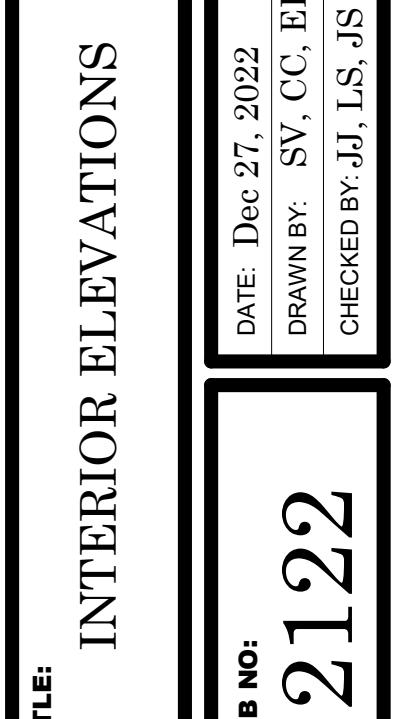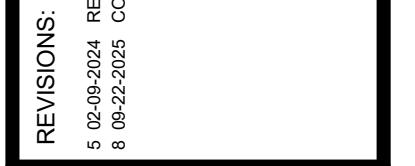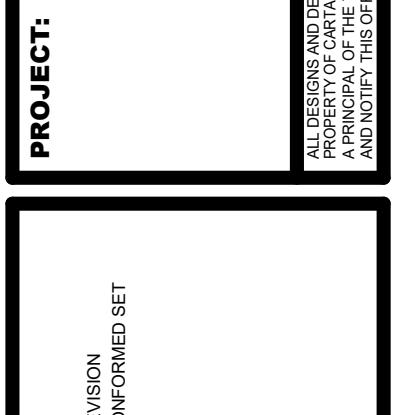


PLAYROOM INTERIOR ELEVATION - WEST

Scale: 3/16" = 1'-0"

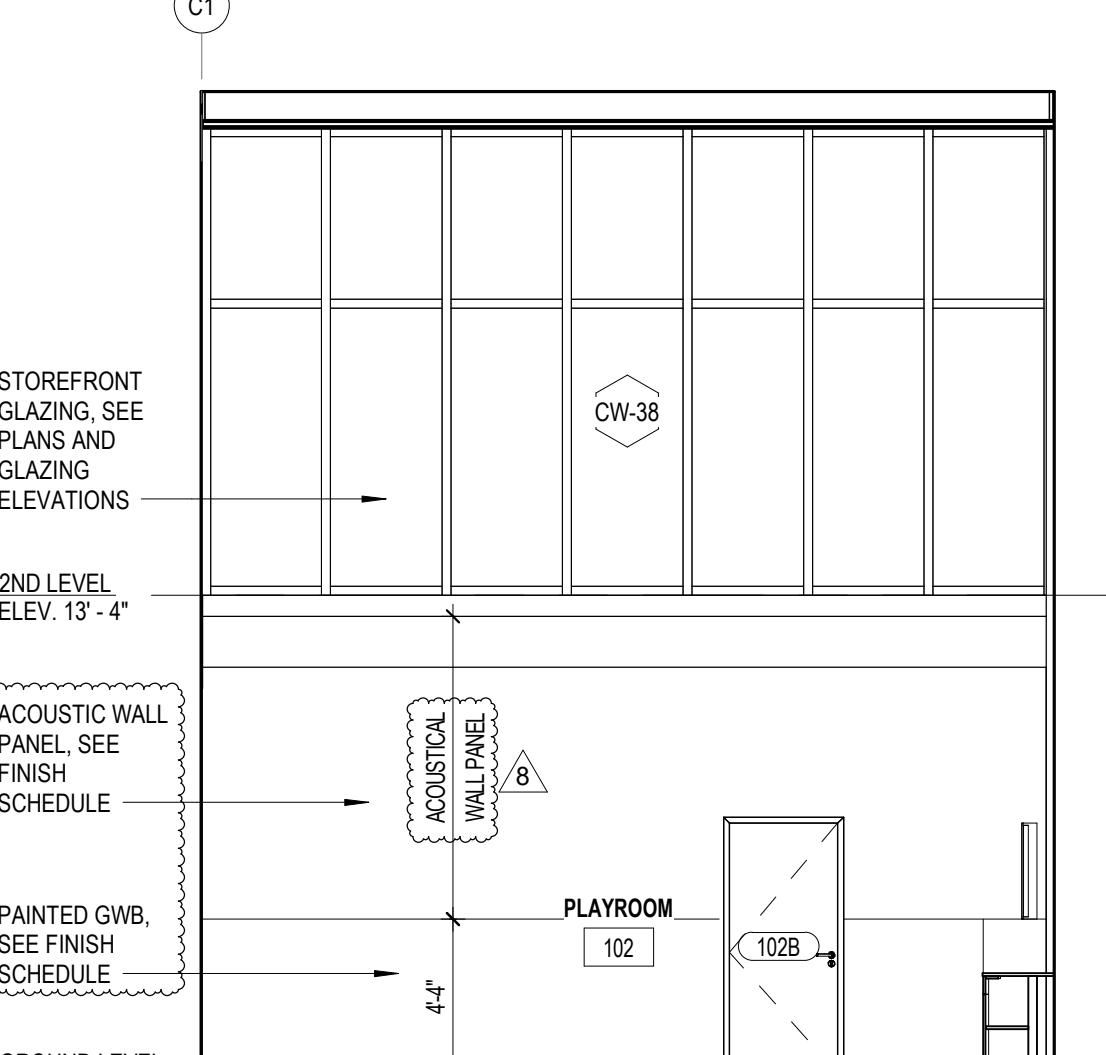


PLAYROOM INTERIOR ELEVATION - EAST

Scale: 3/16" = 1'-0"

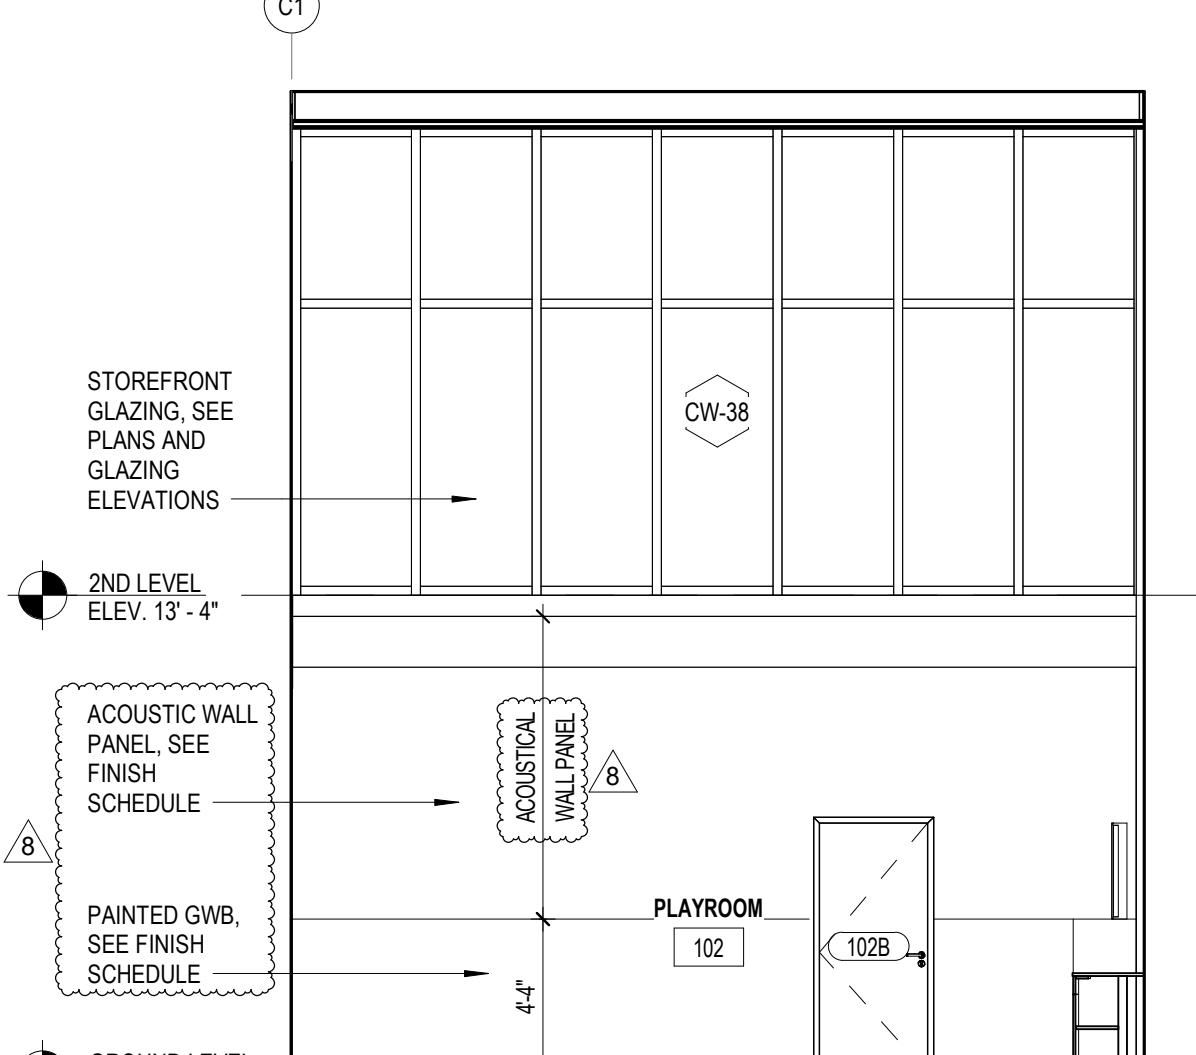


GYMNASIUM INTERIOR ELEVATION - EAST

Scale: 3/16" = 1'-0"

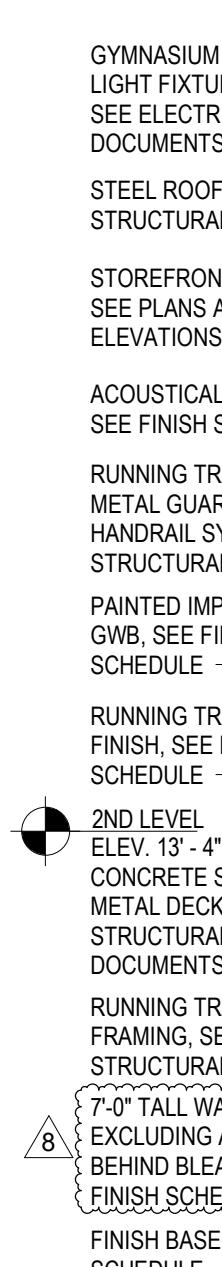

GYMNASIUM INTERIOR ELEVATION - WEST

Scale: 3/16" = 1'-0"

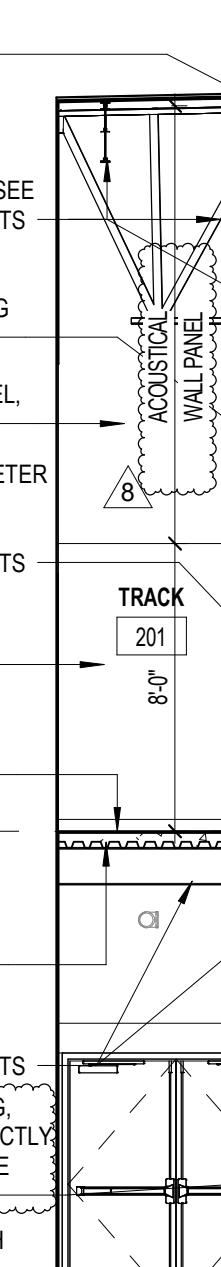


GYMNASIUM INTERIOR ELEVATION - WEST

Scale: 3/16" = 1'-0"




PLAYROOM INTERIOR ELEVATION - SOUTH

Scale: 3/16" = 1'-0"




















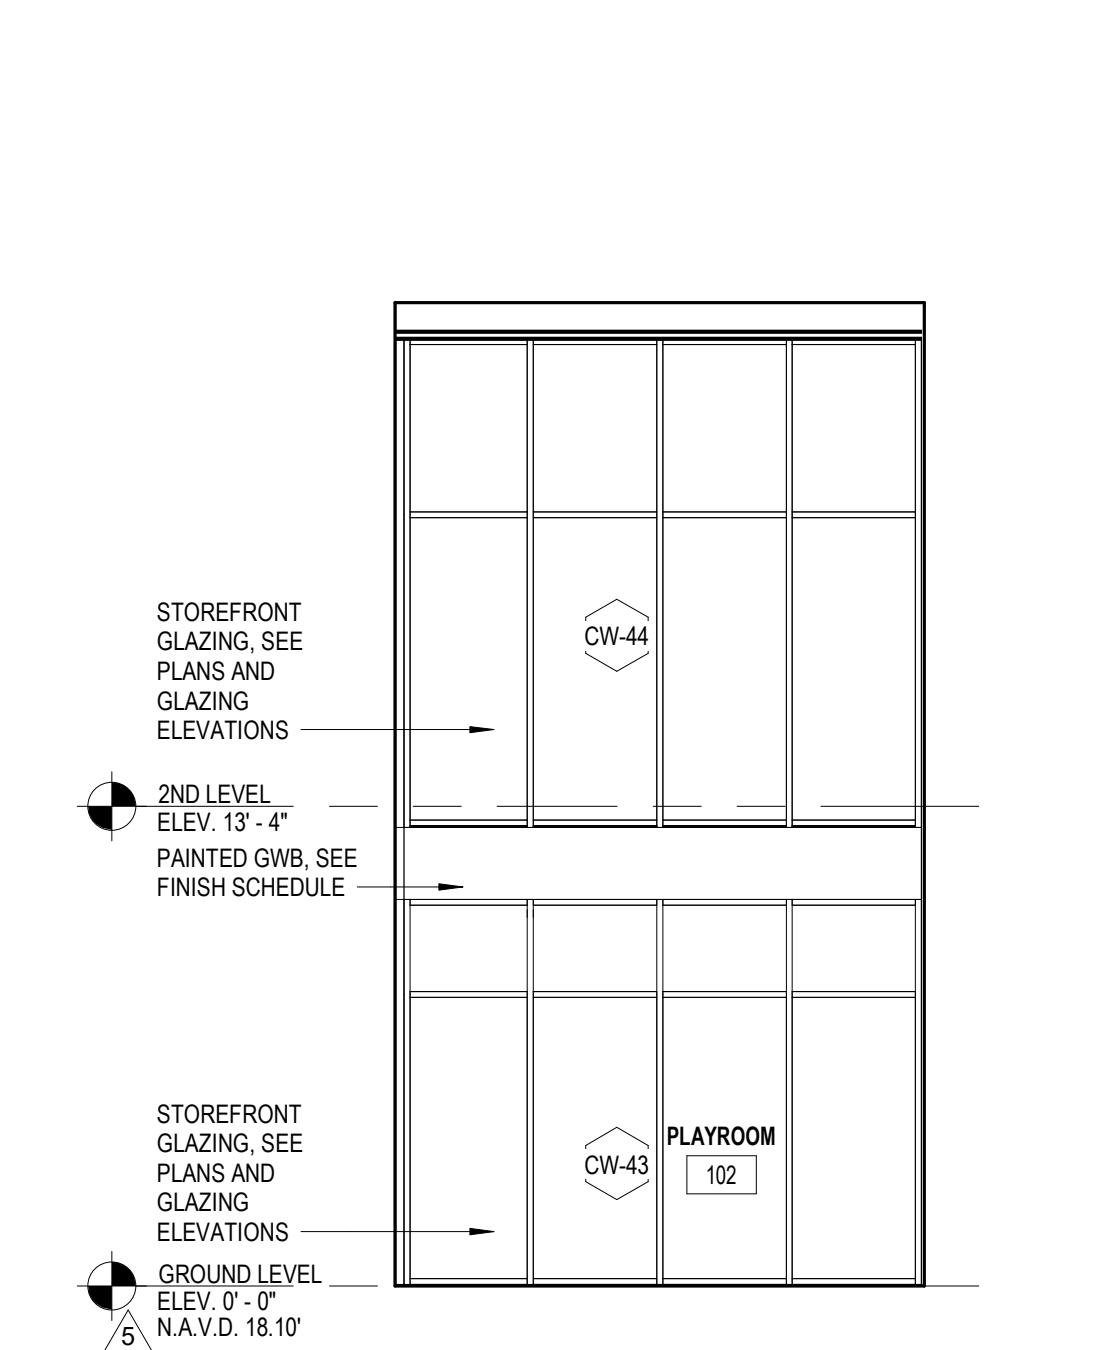



PLAYROOM INTERIOR ELEVATION - NORTH

Scale: 3/16" = 1'-0"

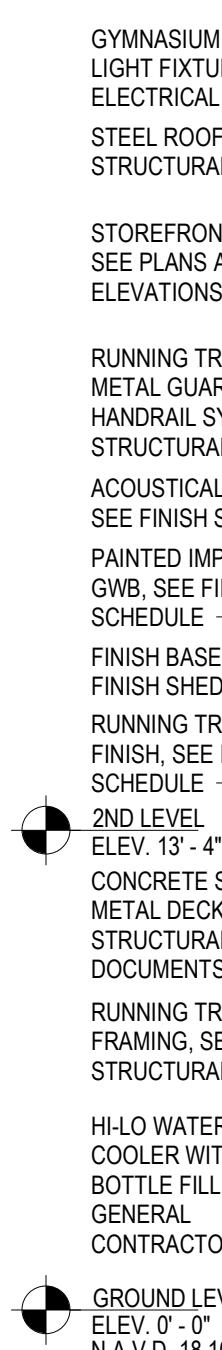

FINISH SCHEDULE NOTES	
1.	GYMNASIUM WALLS TO RECEIVE ACOUSTICAL PANELS ON WALLS.
2.	CEMENTITIOUS BACKER BOARD SHALL BE USED FOR ALL TILE WALLS.
3.	ADDITIONAL ACOUSTIC WALLS AT GYMNASIUM FLOOR LEVEL EXCLUDING AREAS DIRECTLY BEHIND BLEACHERS. AREAS DIRECTLY BEHIND BLEACHERS TO BE PAINTED GYPSUM BOARD.
4.	IMPACT RESISTANT GYPSUM WALL BOARD MIN. 8'-0" THROUGH (TYPICAL) WHERE SPECIFIED IN FINISH SCHEDULE.
5.	PAINT EXPOSED ROOF STRUCTURE ABOVE COLOR FLAT SW9179 - ANCHOR AWEIGH. PAINT ALL EXPOSED STRUCTURE, DUCTWORK, ETC. PROVIDE BLOCC FILLER AT ALL BLOCK WALLS WITH NON-ABSORBENT EPOXY PAINT FINISH.
6.	PAINT EXPOSED STRUCTURE IN B.O.H. ROOMS EXCEPT AS NOTED ON THE FINISH SCHEDULE ON SHEET A-640.
7.	ALL EXTERIOR OR NON A/C ROOMS TO HAVE M.R. BOARDS OR STUCCO FINISH WITH NON-ABSORBENT PAINT FINISH.
8.	PAPERLESS M.R. GYPSUM WALL BOARD PAINTED WITH NON-ABSORBENT PAINT FOR ALL EXTERIOR RESTROOMS AND LOCKERS.
9.	PAINT ALL EXPOSED CONCRETE CEILINGS WITH NON-ABSORBENT PAINT, COLOR TO MATCH.
10.	MILLWORK FINISH TO BE DEKTON LUNAR, SATIN SMOOTH, MITERED/ROUNDED CORNERS.
11.	CEMENTITIOUS BACKER BOARD SHALL BE USED FOR ALL TILE WALLS.
12.	LOCKERS MANUFACTURED BY PRENCO, COLOR REFLEX BLUE.
13.	3/4" AC GRADE PLYWOOD PAINTED FRONT, BACK, STEEL AND ALL SIDES WITH FIRE RETARDANT PAINT. PLYWOOD SHALL BE MOUNTED ON ALL WALLS OF THE ROOM. 8" FROM THE FLOOR EXTENDING TO THE CEILING.
14.	REFER TO FLOOR PATTERN LAYOUT.
15.	STAIR SHALL BE TILE FINISH. STEPS SHALL BE LAMBOO DESERT SAND.

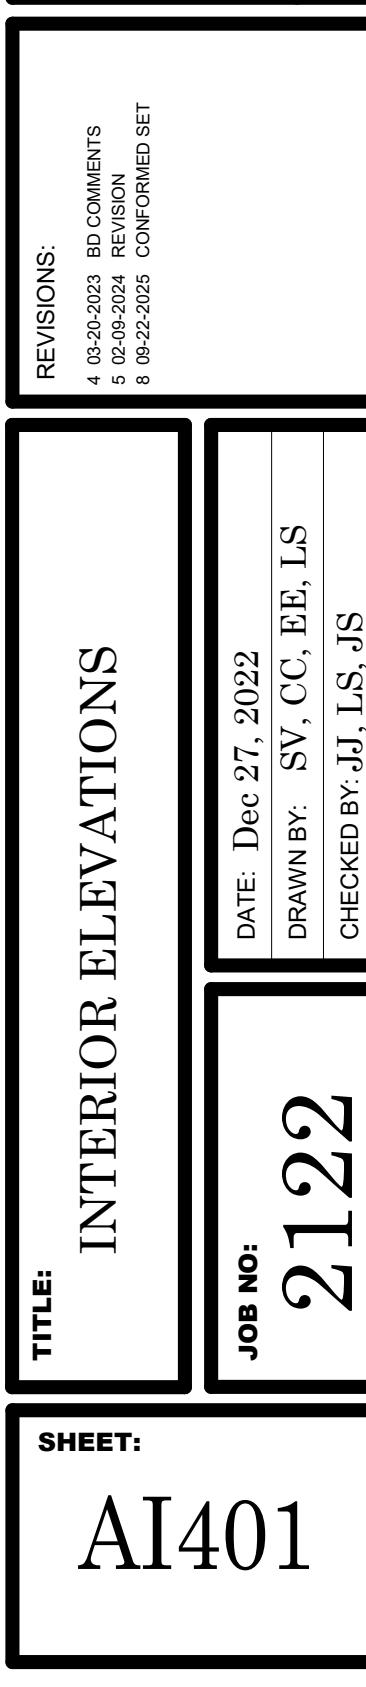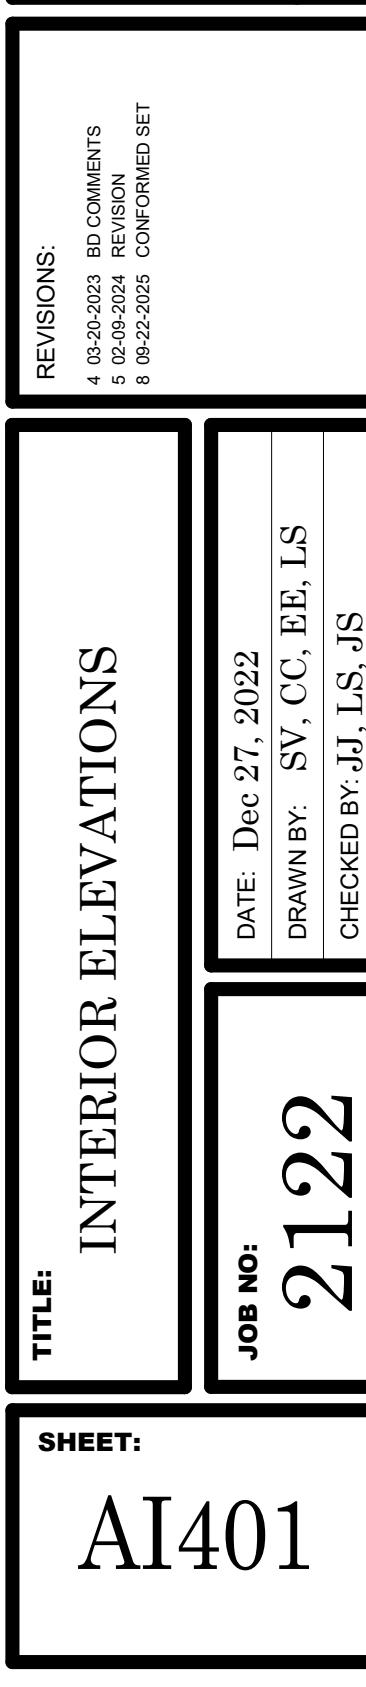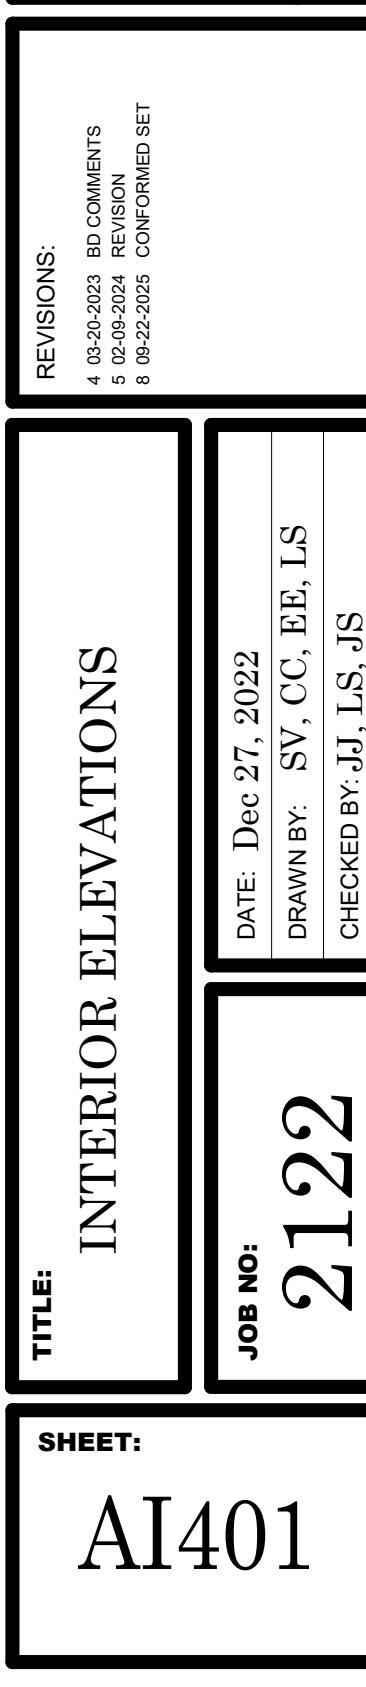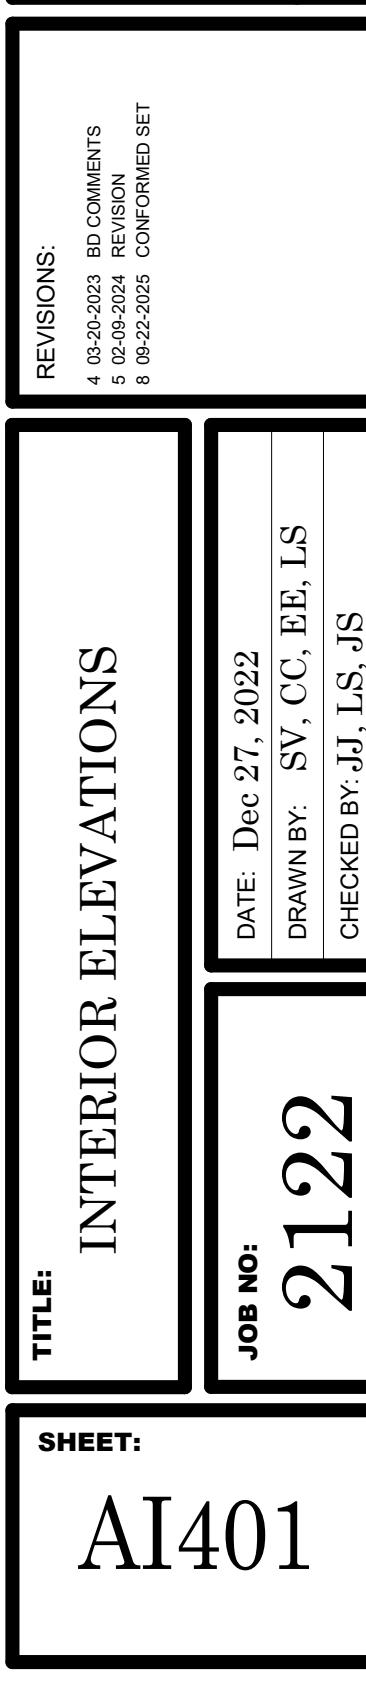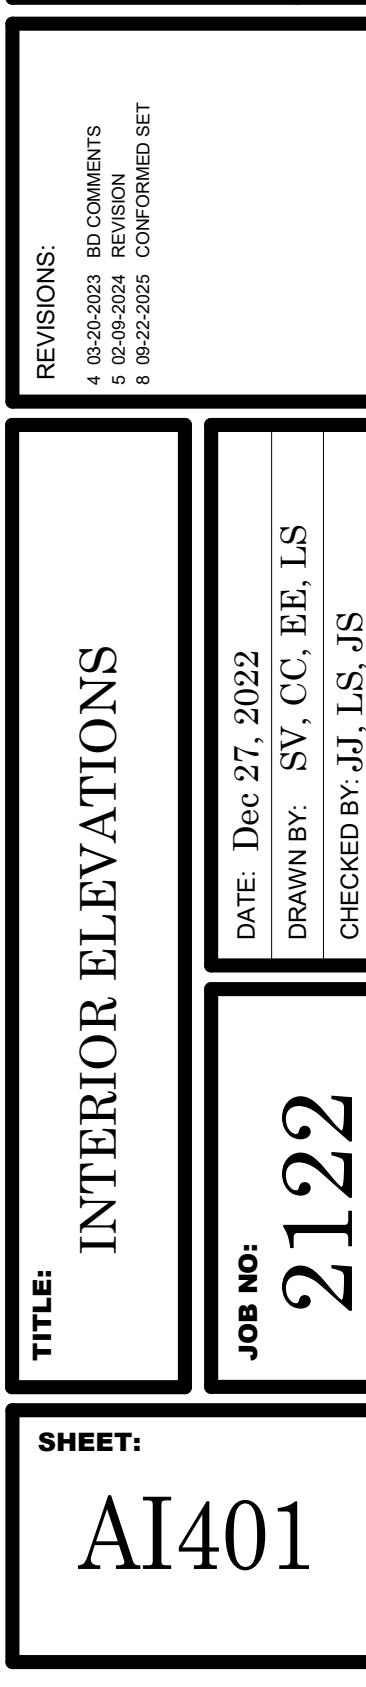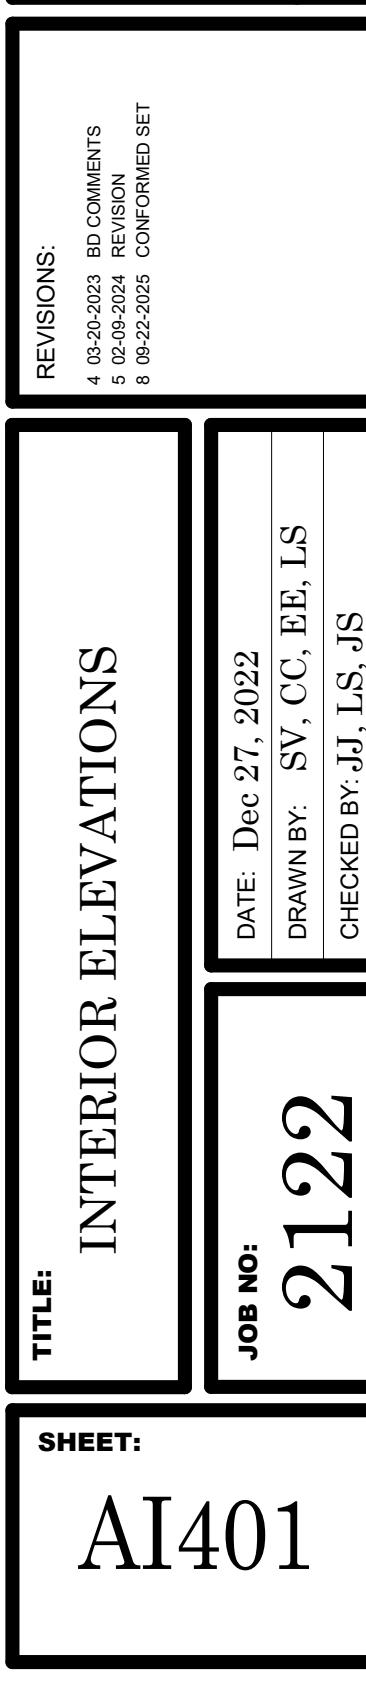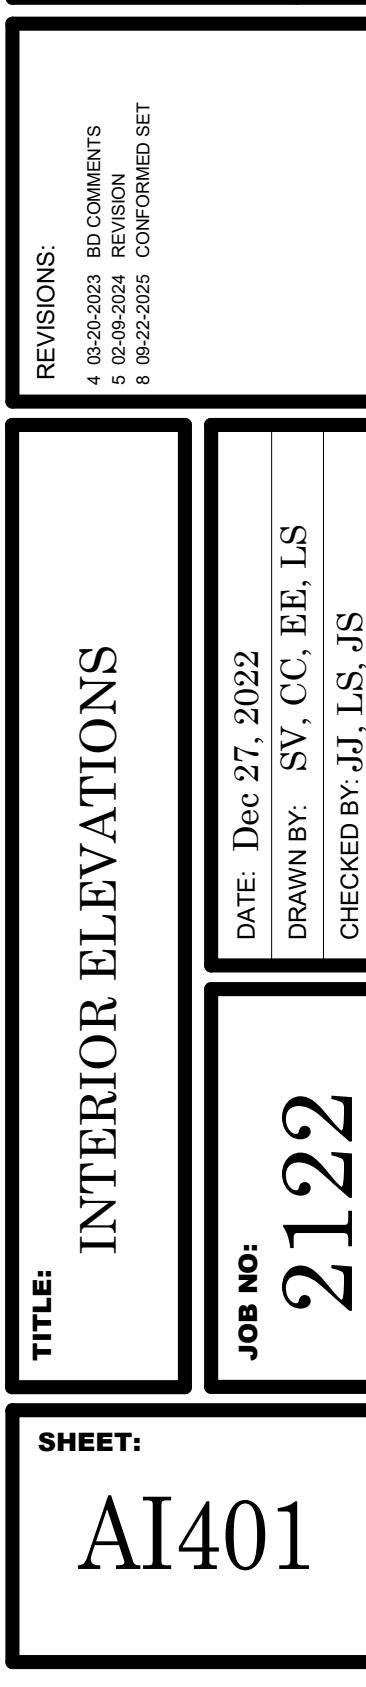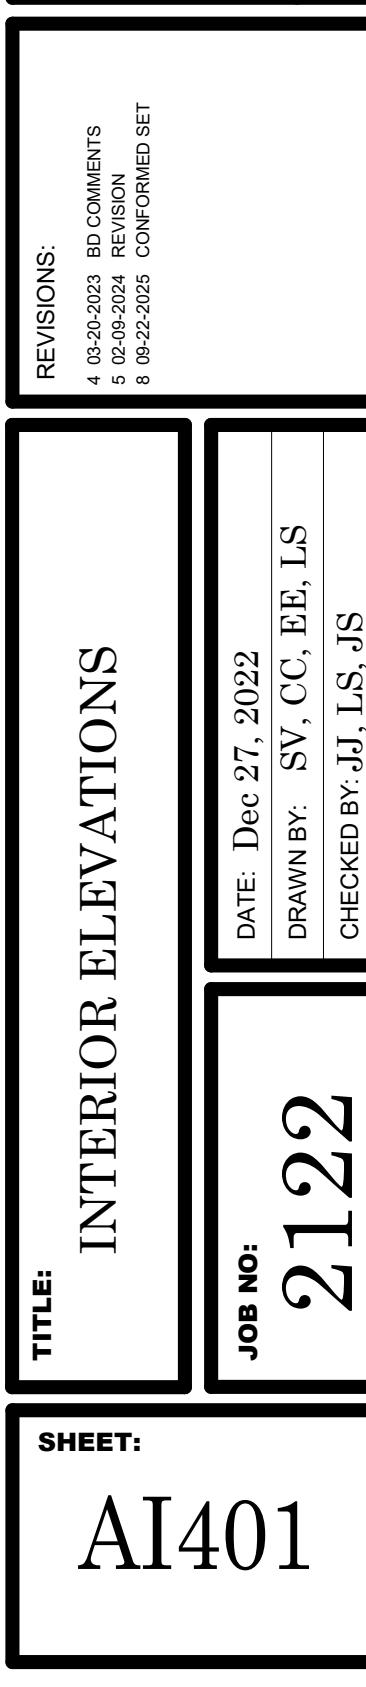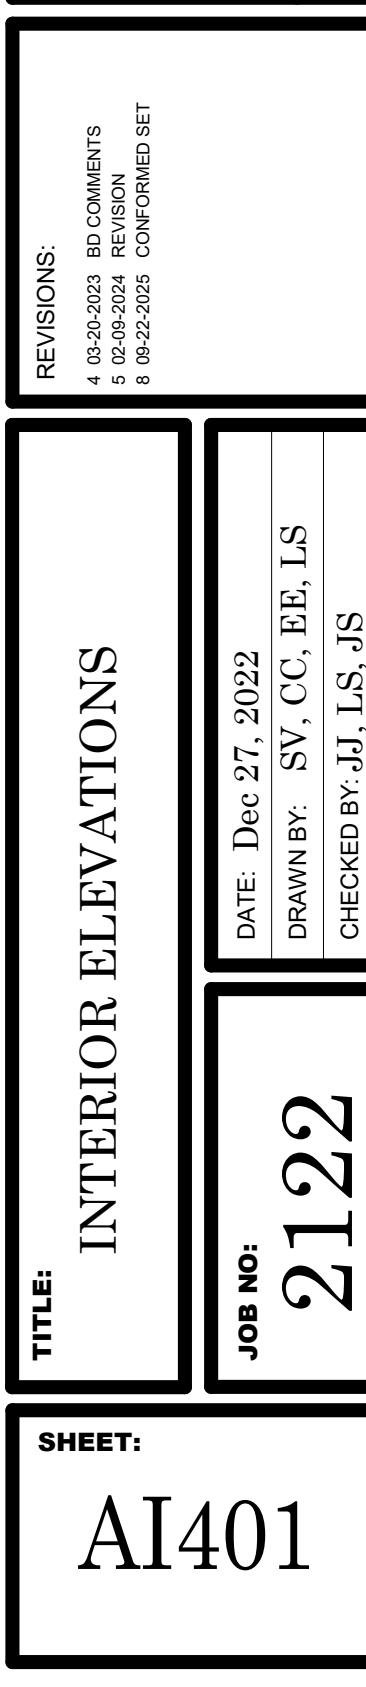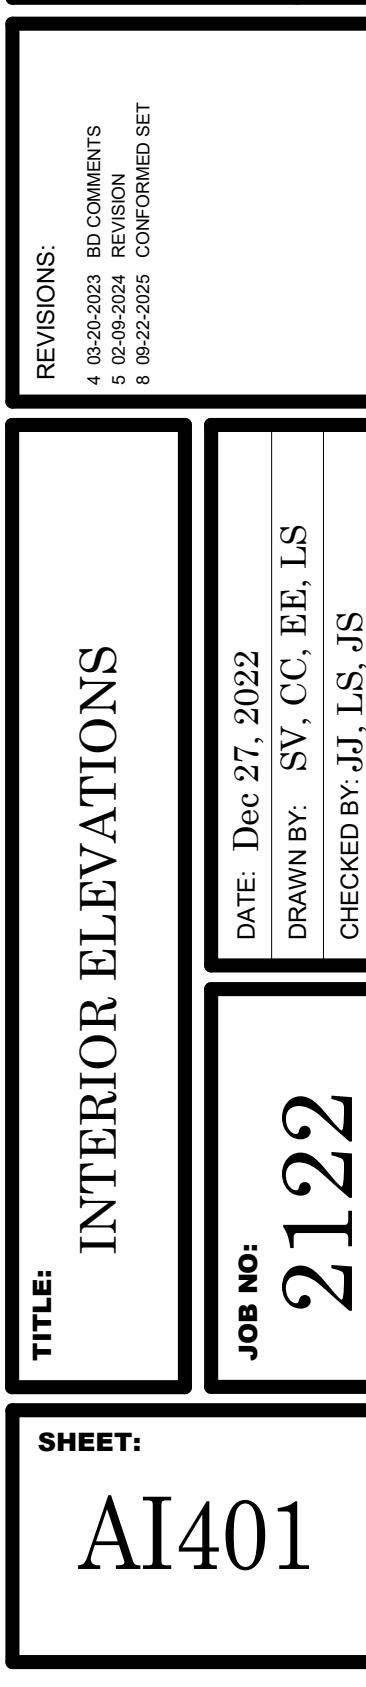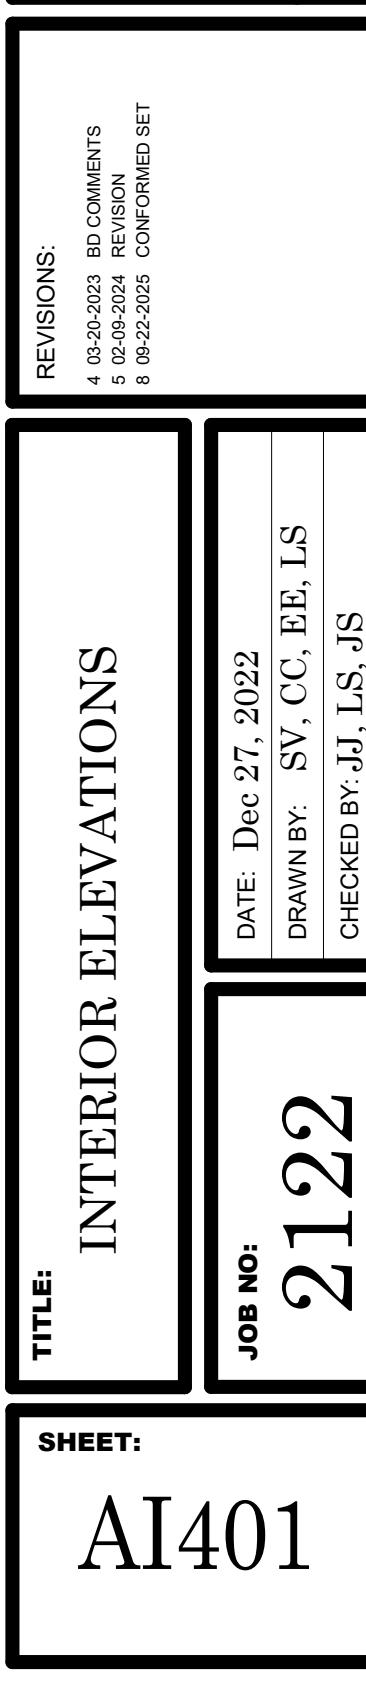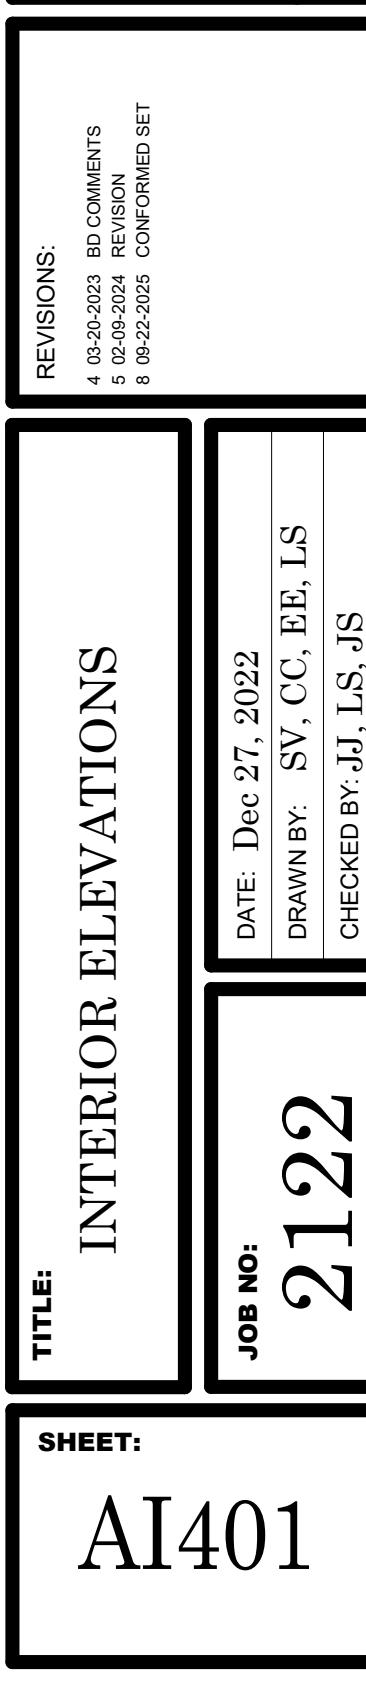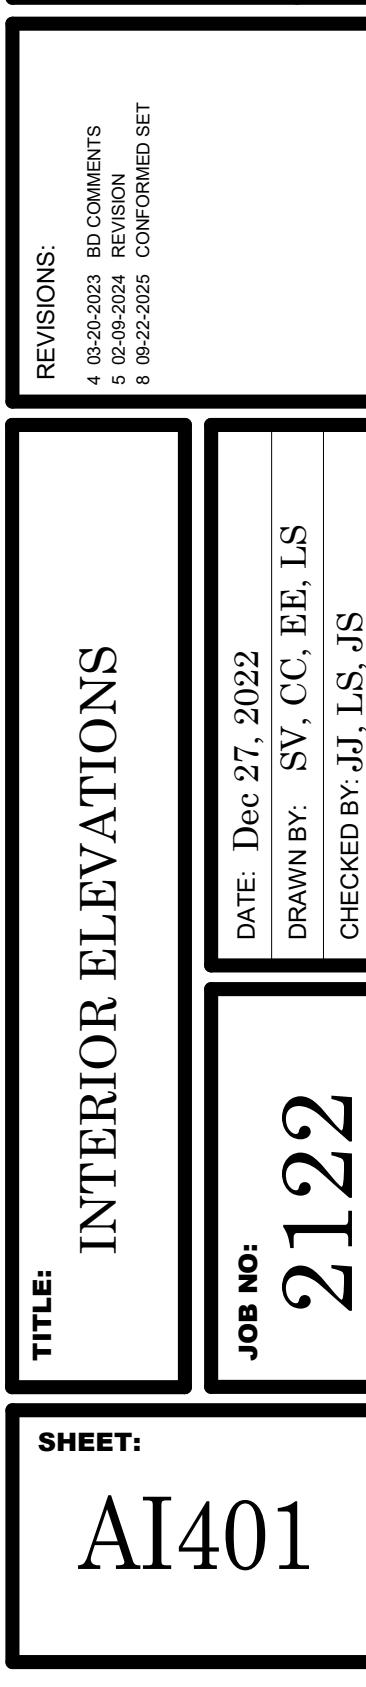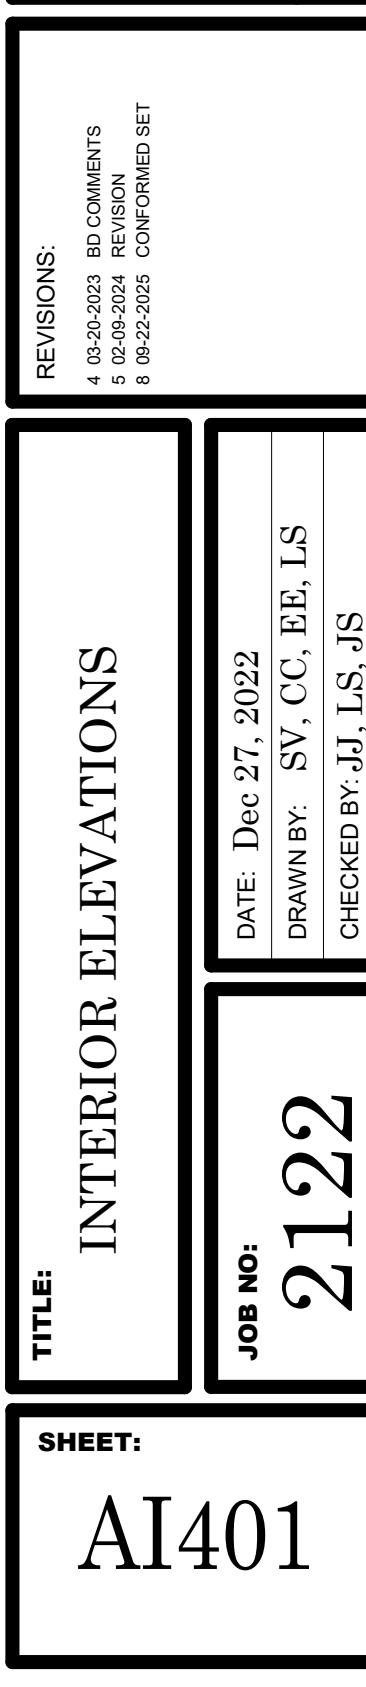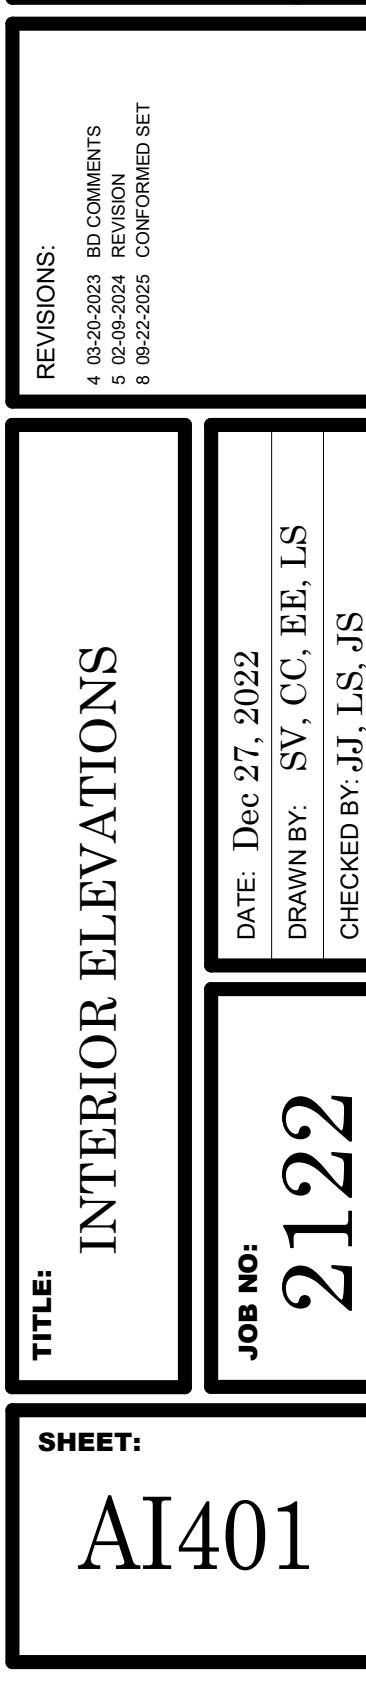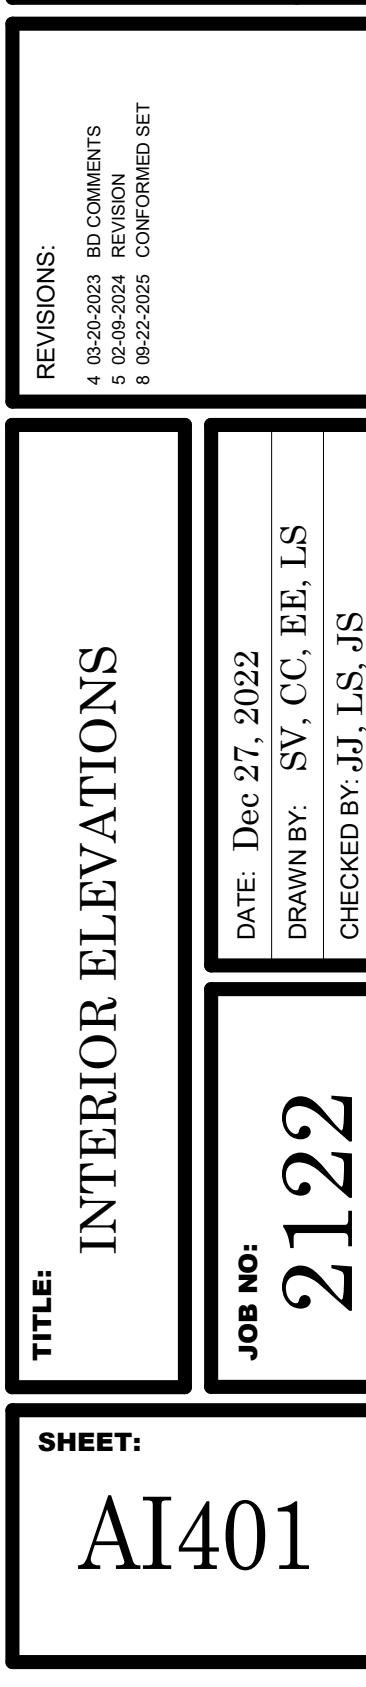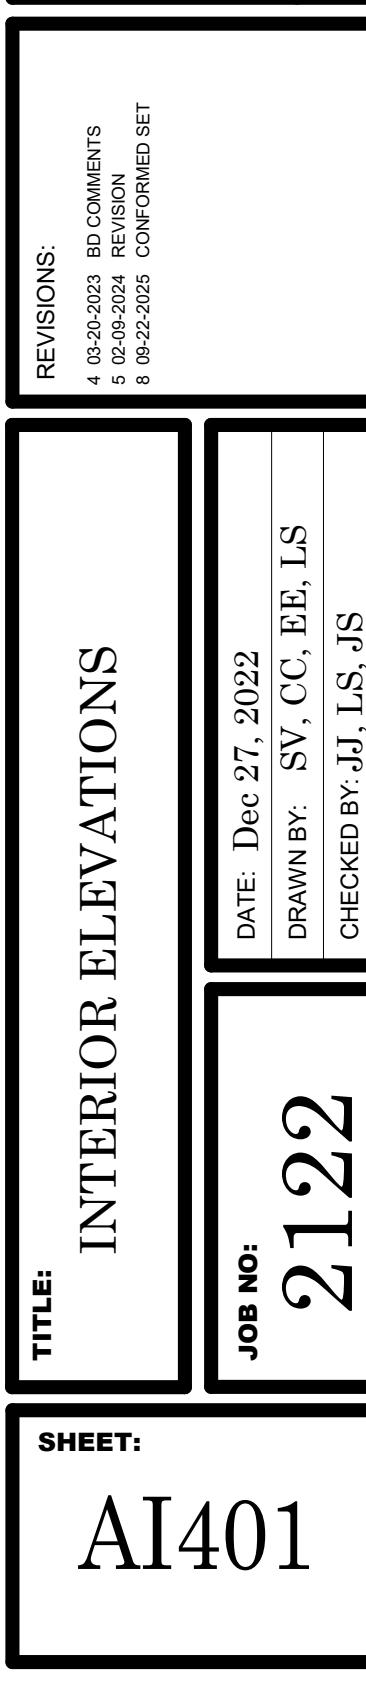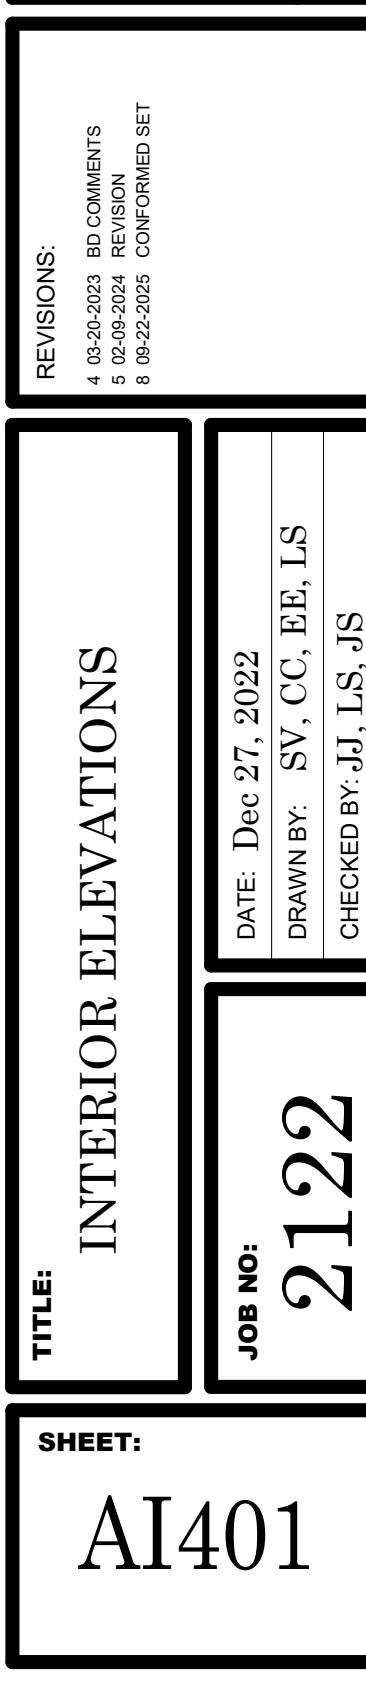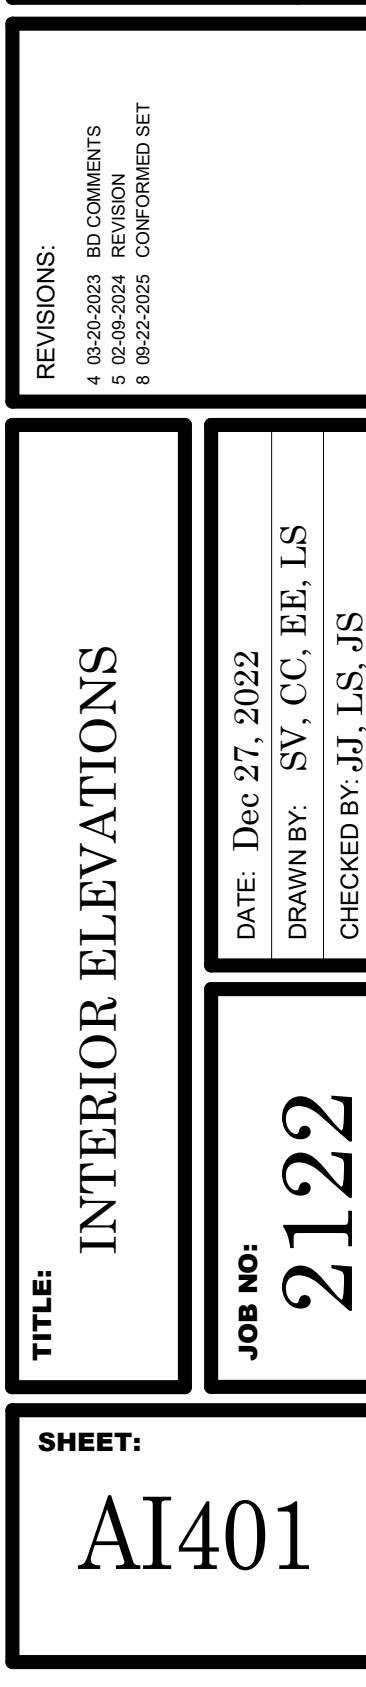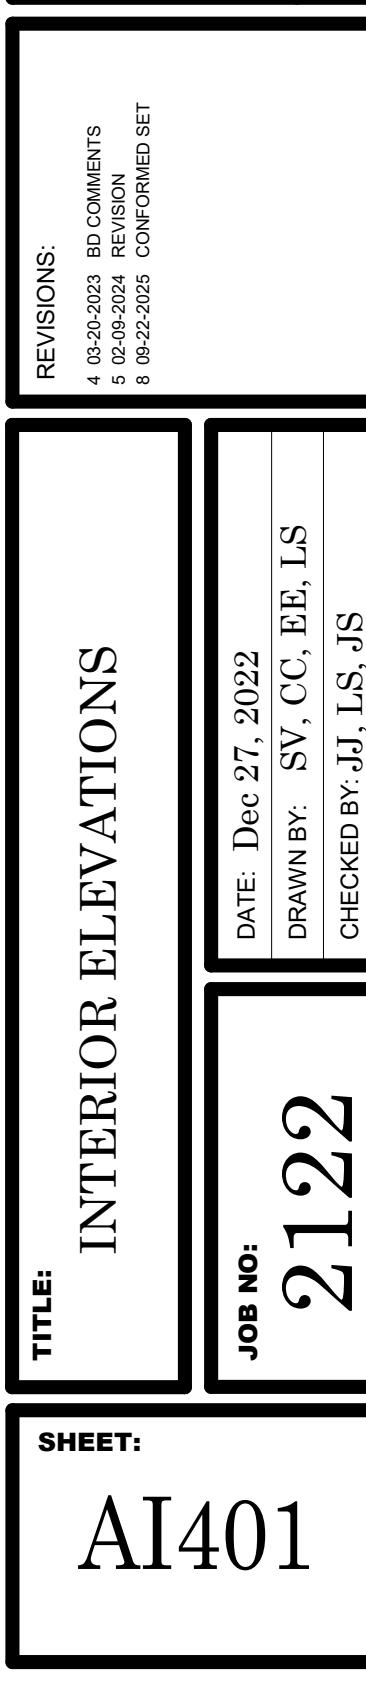


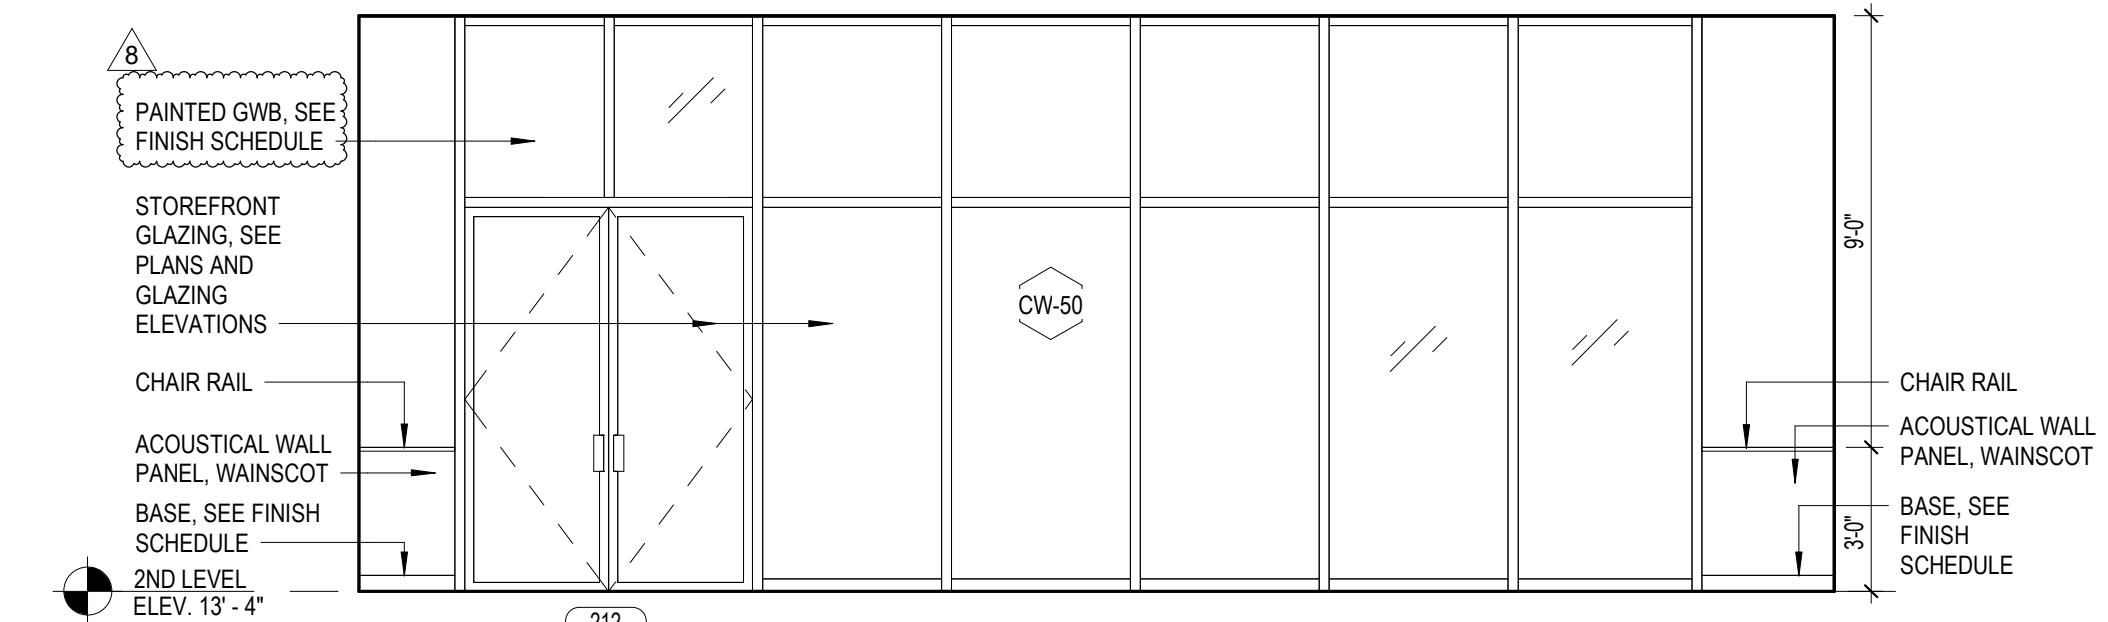

FITNESS INTERIOR ELEVATION - NORTH

5


Scale: 1/4" = 1'-0"

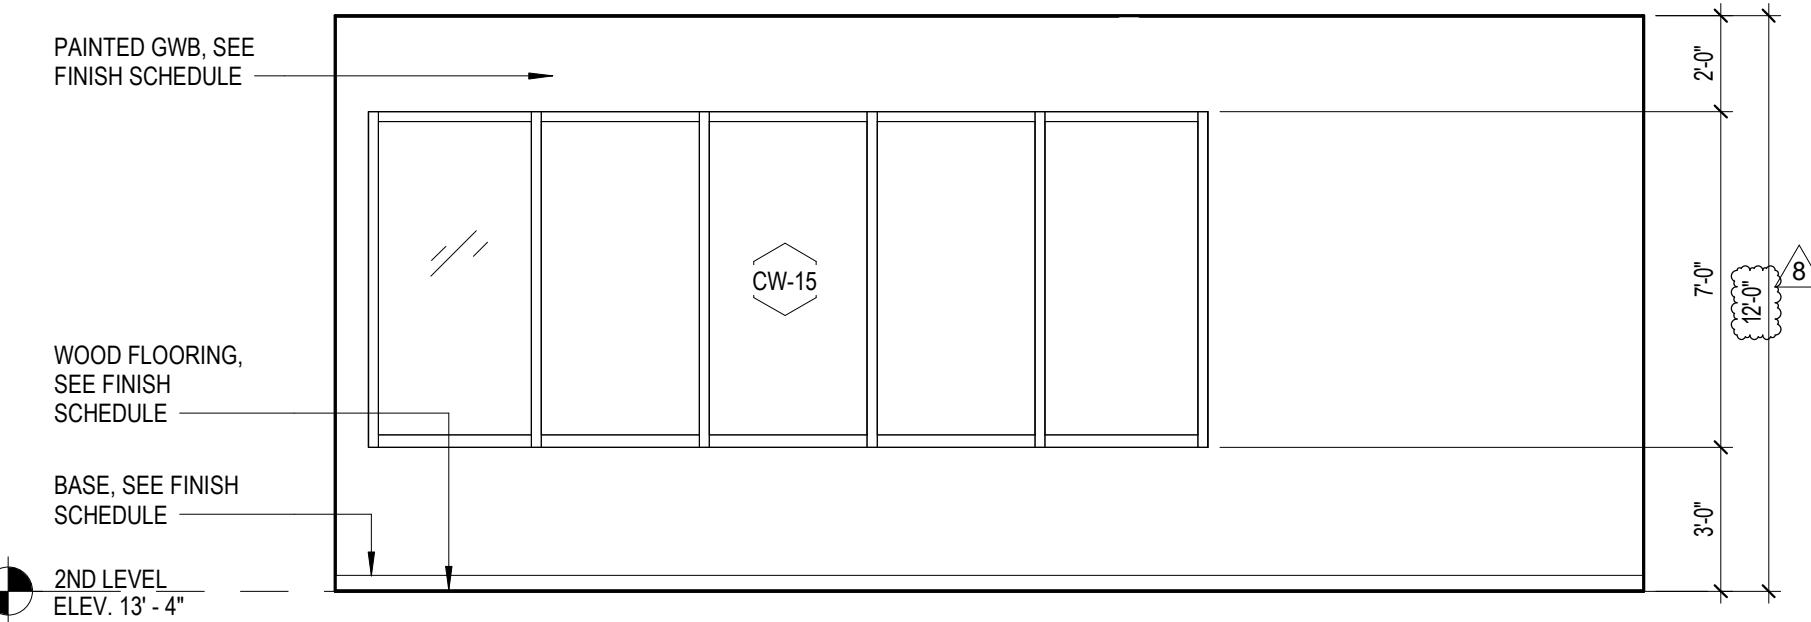

DANCE - AEROBICS INTERIOR ELEVATION - SOUTH

4


Scale: 1/4" = 1'-0"

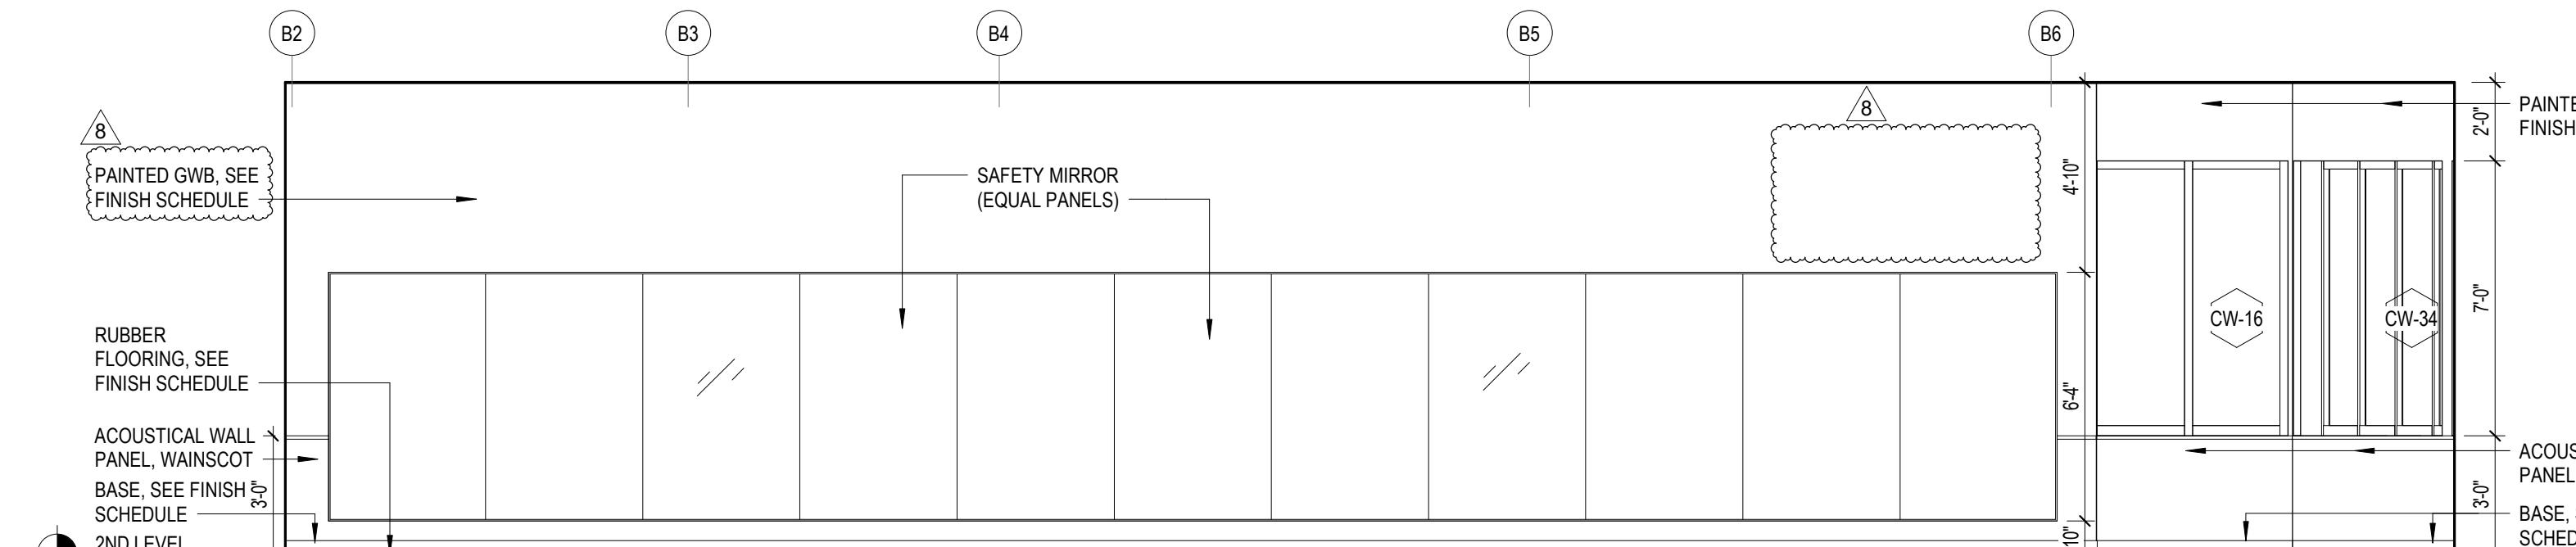

FITNESS INTERIOR ELEVATION - EAST

8


Scale: 1/4" = 1'-0"

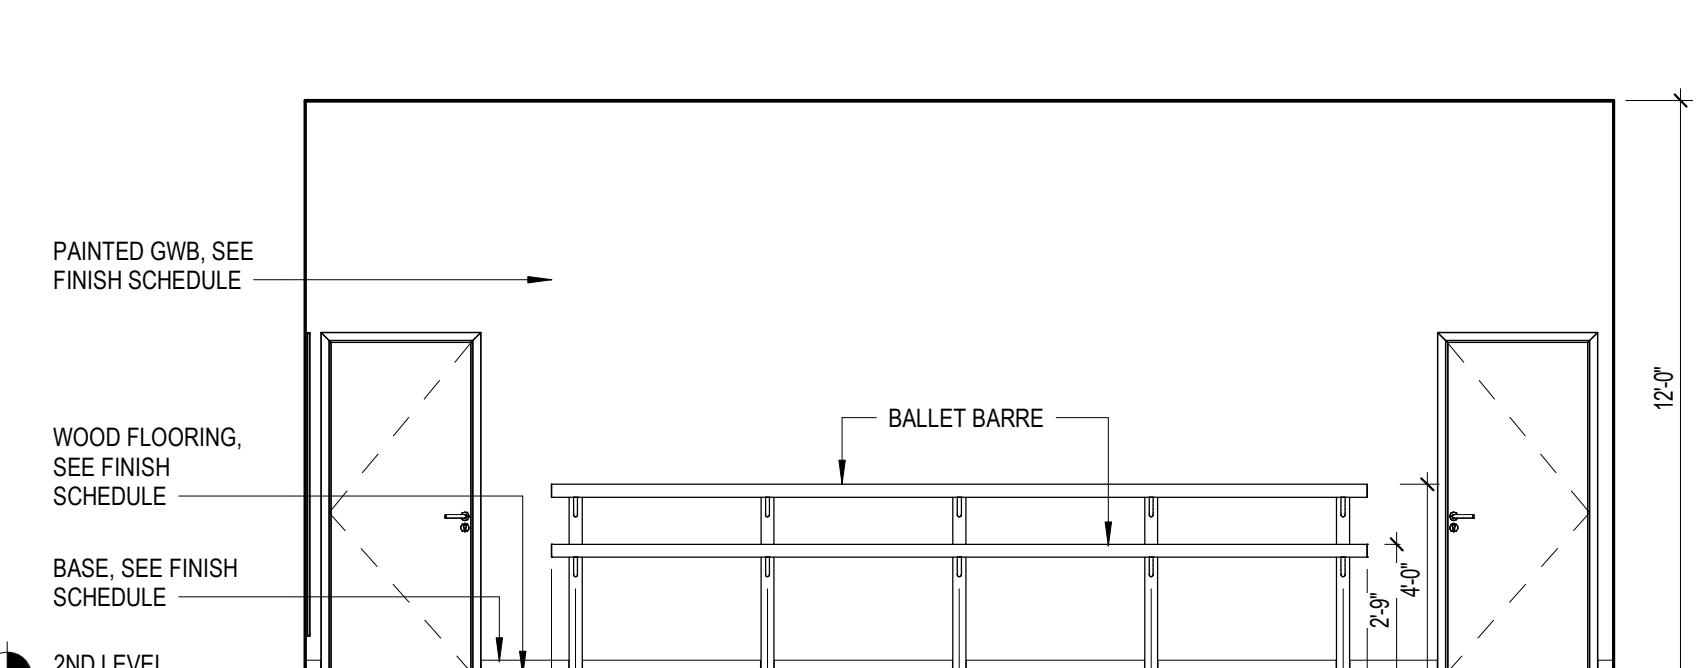

DANCE - AEROBICS INTERIOR ELEVATION - NORTH

3


Scale: 1/4" = 1'-0"

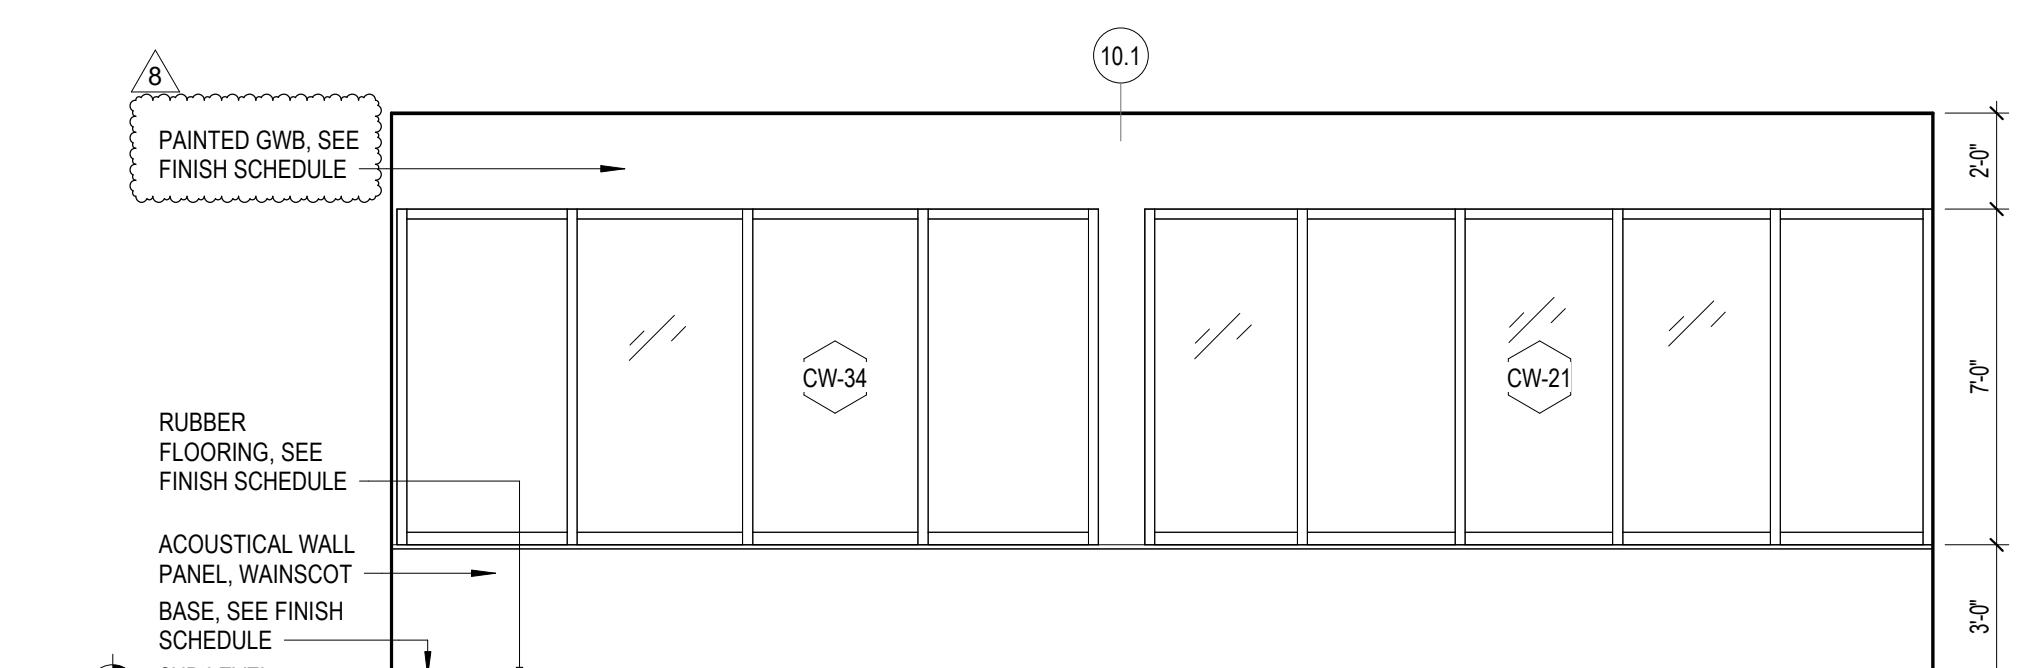

FITNESS INTERIOR ELEVATION - SOUTH

7


Scale: 1/4" = 1'-0"

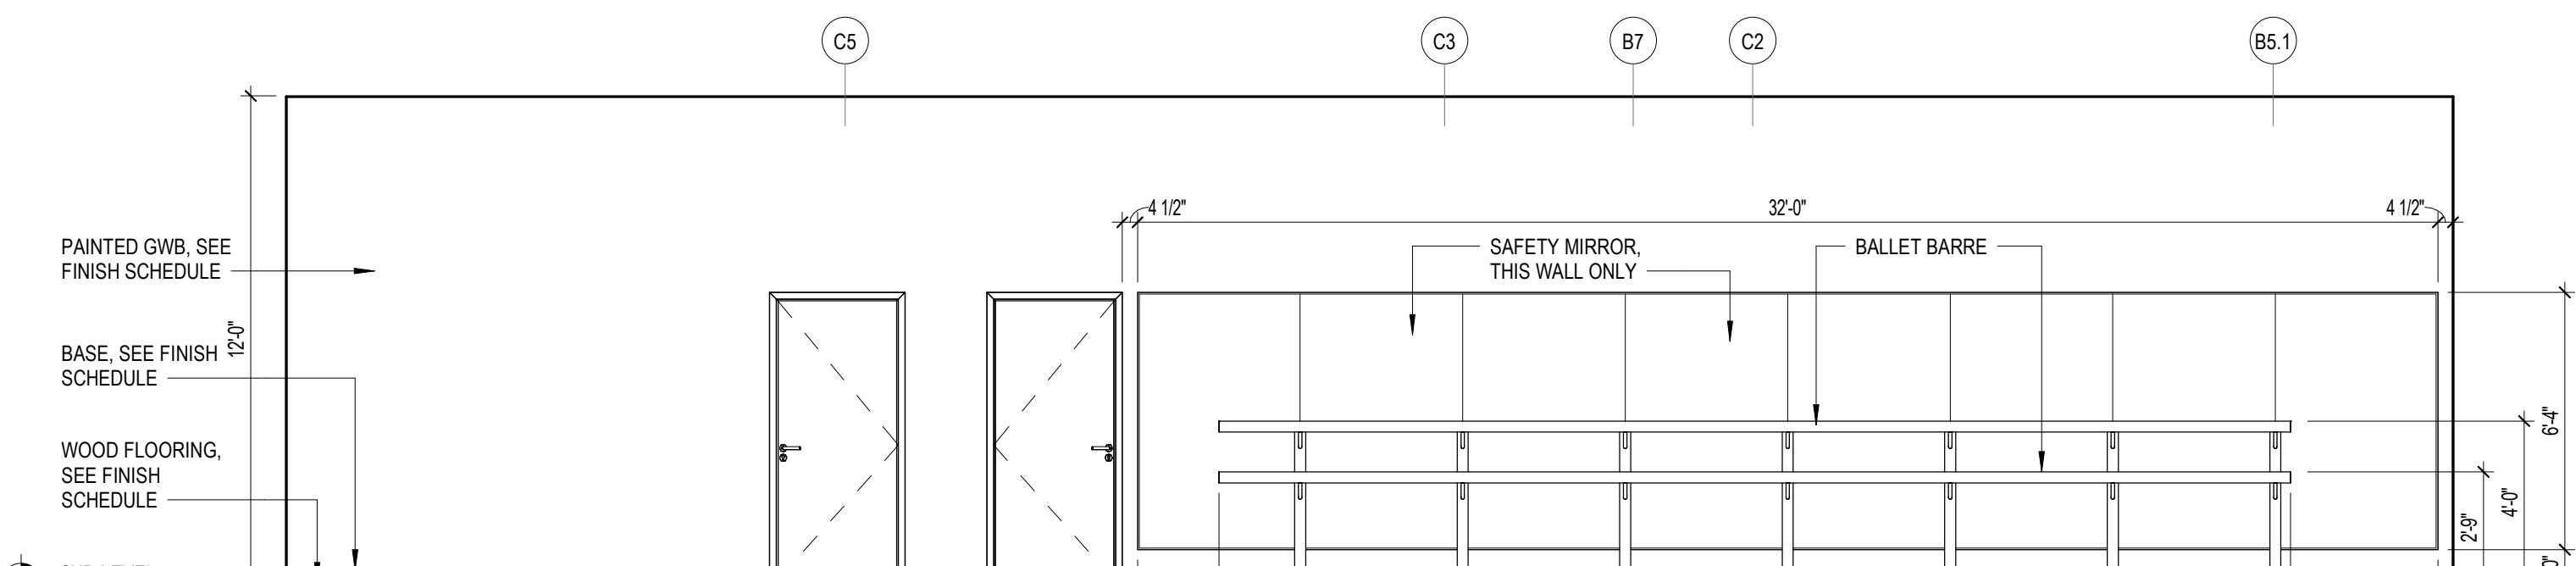

DANCE - AEROBICS INTERIOR ELEVATION - WEST

2


Scale: 1/4" = 1'-0"

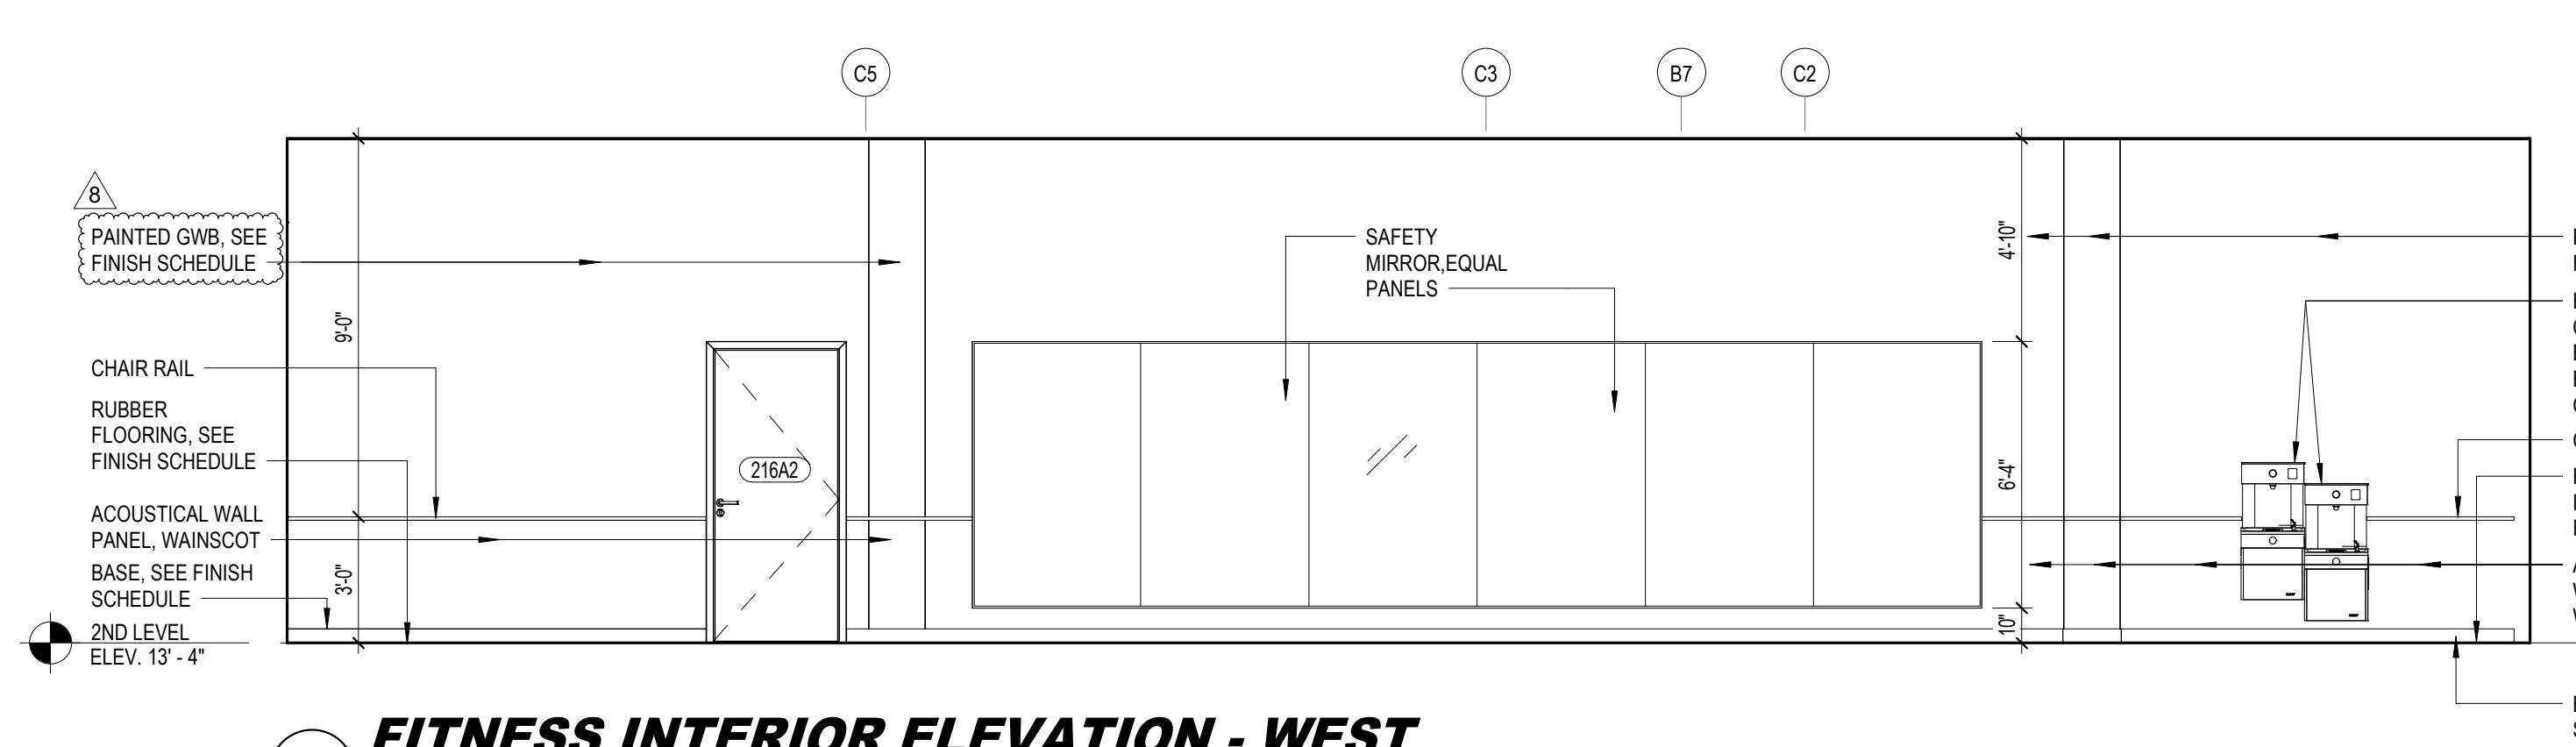

FITNESS INTERIOR ELEVATION - WEST

6

Scale: 1/4" = 1'-0"


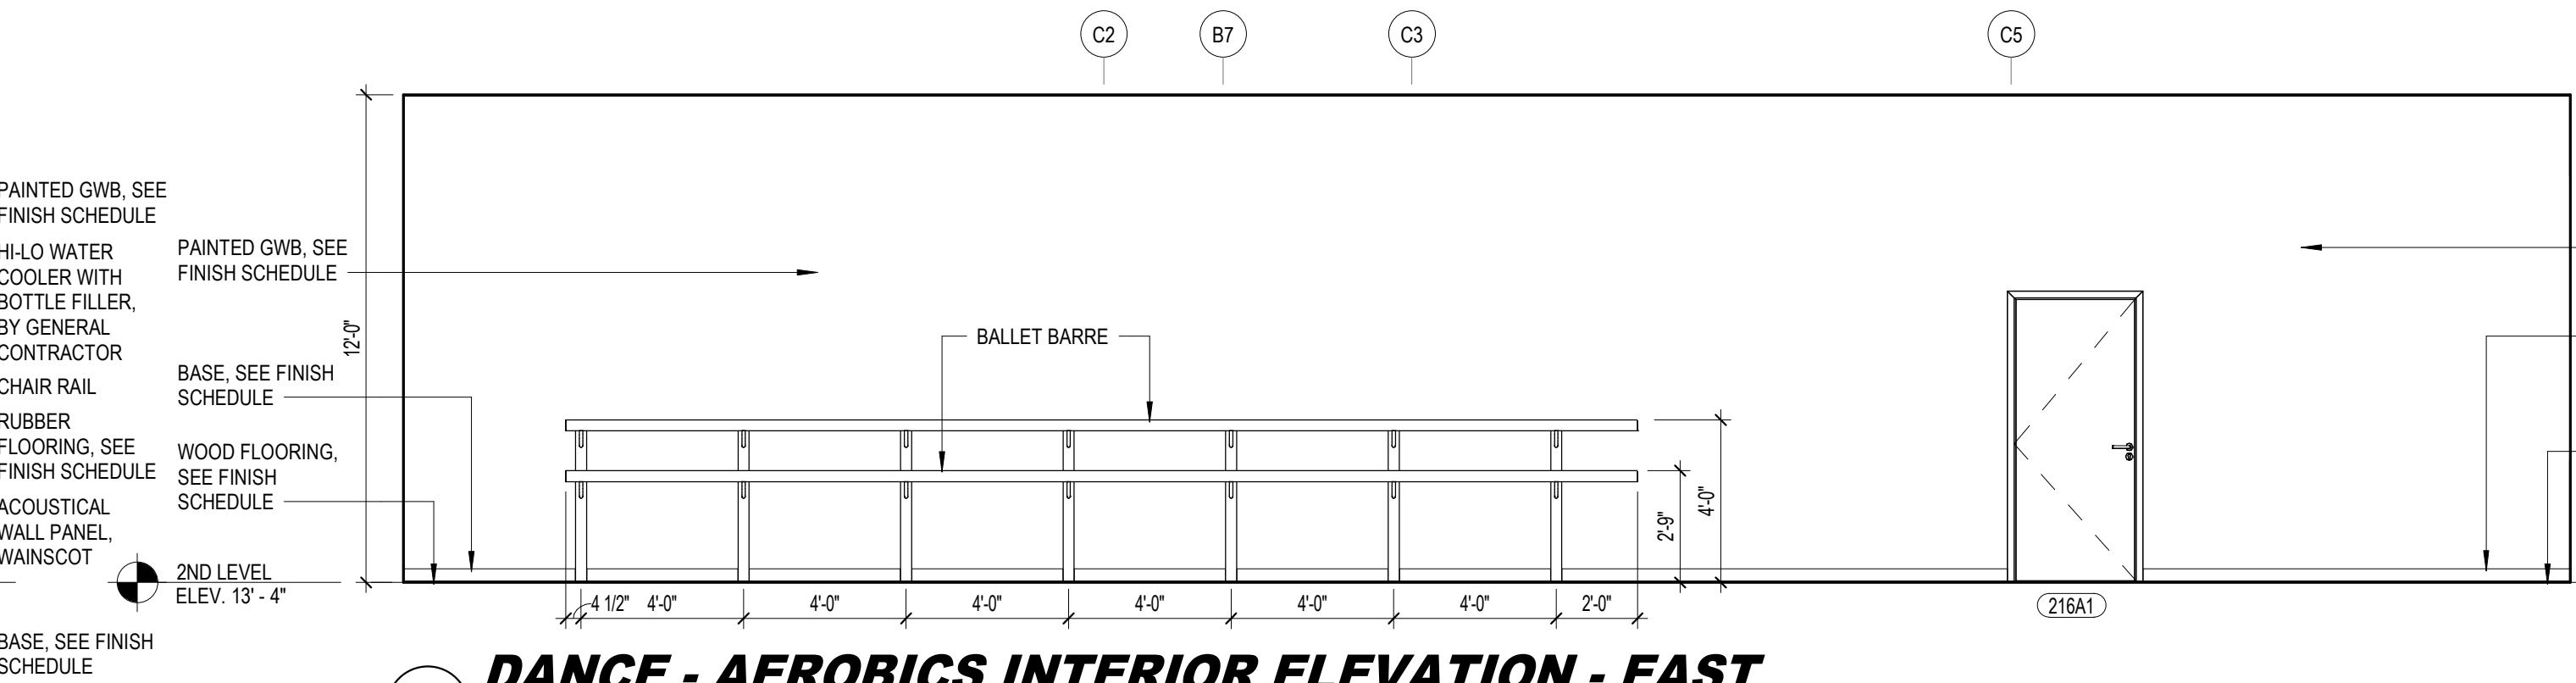



DANCE - AEROBICS INTERIOR ELEVATION - EAST

1

Scale: 1/4" = 1'-0"


FINISH SCHEDULE NOTES	
1. GYMNASIUM WALLS TO RECEIVE ACOUSTICAL PANELS ON WALLS. TYPICAL AT BOTH LEVELS.	
2. ADDITIONAL PERFORATED WALLS AT GYMNASIUM FLOOR LEVEL EXCLUDING AREAS DIRECTLY BEHIND BLEACHERS. AREAS DIRECTLY BEHIND BLEACHERS TO BE PAINTED GYPSUM BOARD.	
3. IMPACT RESISTANT GYPSUM WALL BOARD MIN. 8'-0" THROUGHOUT (TYPICAL) WHERE SPECIFIED IN FINISH SCHEDULE.	
4. PAINT EXPOSED ROOF STRUCTURE ABOVE COLOR FLAT SW9179 - ANCHOR AWEIGH. PAINT ALL EXPOSED STRUCTURE, DUCTWORK, ETC.	
5. PROVIDE BLOCC FILLER AT ALL BLOCK WALLS WITH NON-ABSORBENT EPOXY PAINT FINISH.	
6. PAINT EXPOSED STRUCTURE IN B.O.H. ROOMS EXCEPT AS NOTED ON THE FINISH SCHEDULE ON SHEET A-640.	
7. ALL EXTERIOR OR NON A/C ROOMS TO HAVE M.R. BOARDS OR STUCCO FINISH WITH NON-ABSORBENT PAINT FINISH.	
8. PAPERLESS M.R. GYPSUM WALL BOARD PAINTED WITH NON-ABSORBENT PAINT FOR ALL INTERIOR RESTROOMS AND LOCKERS.	
9. PAINT ALL EXPOSED CONCRETE CEILINGS WITH NON-ABSORBENT PAINT. COLOR TO MATCH EXISTING.	
10. MILLWORK FINISH TO BE DEKTON LUNAR, SATIN SMOOTH, MITERED/ROUNDED CORNERS.	
11. CEMENTITIOUS BACKER BOARD SHALL BE USED FOR ALL TILE WALLS. LOCKERS MANUFACTURED BY PRENCO. COLOR REFLEX BLUE.	
12. 3/4" AC GRADE PLYWOOD PAINTED FRONT, BACK AND ALL SIDES WITH FIRE RETARDANT PAINT. PLYWOOD SHALL BE MOUNTED ON ALL WALLS OF THE ROOM. 8' FROM THE FLOOR EXTENDING TO THE CEILING.	
13. REFER TO FLOOR PATTERN LAYOUT.	
14. STAIR SHALL BE TILE FINISH. STEPS SHALL BE LAMBOO DESERT SAND.	
15. REFER TO FLOOR PATTERN LAYOUT.	

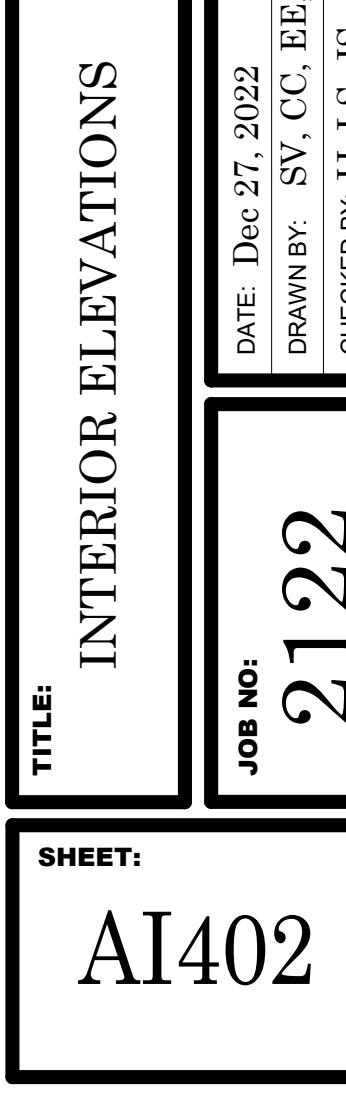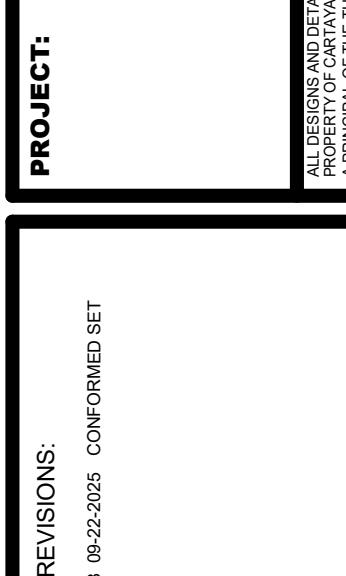

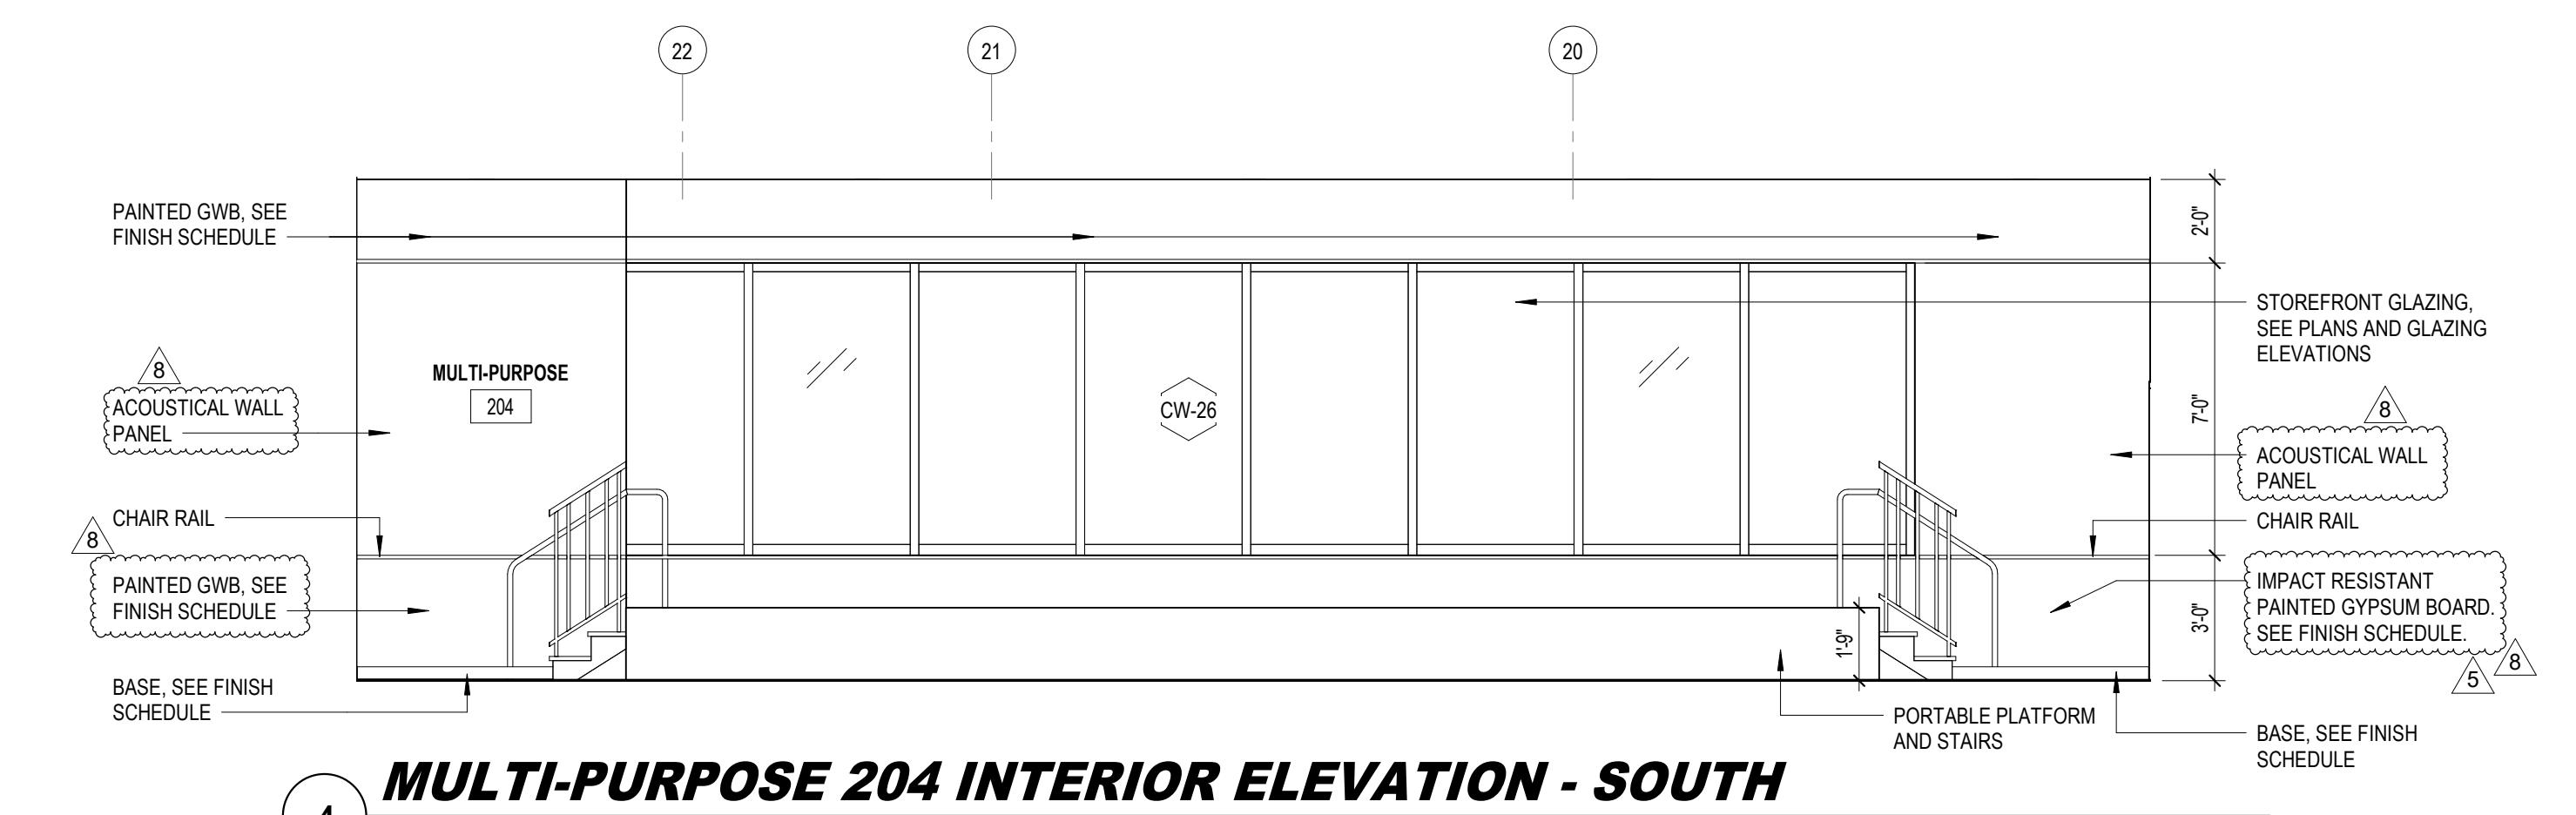


MULTI-PURPOSE 204 INTERIOR ELEVATION - SOUTH

4 Scale: 1/4" = 1'-0"

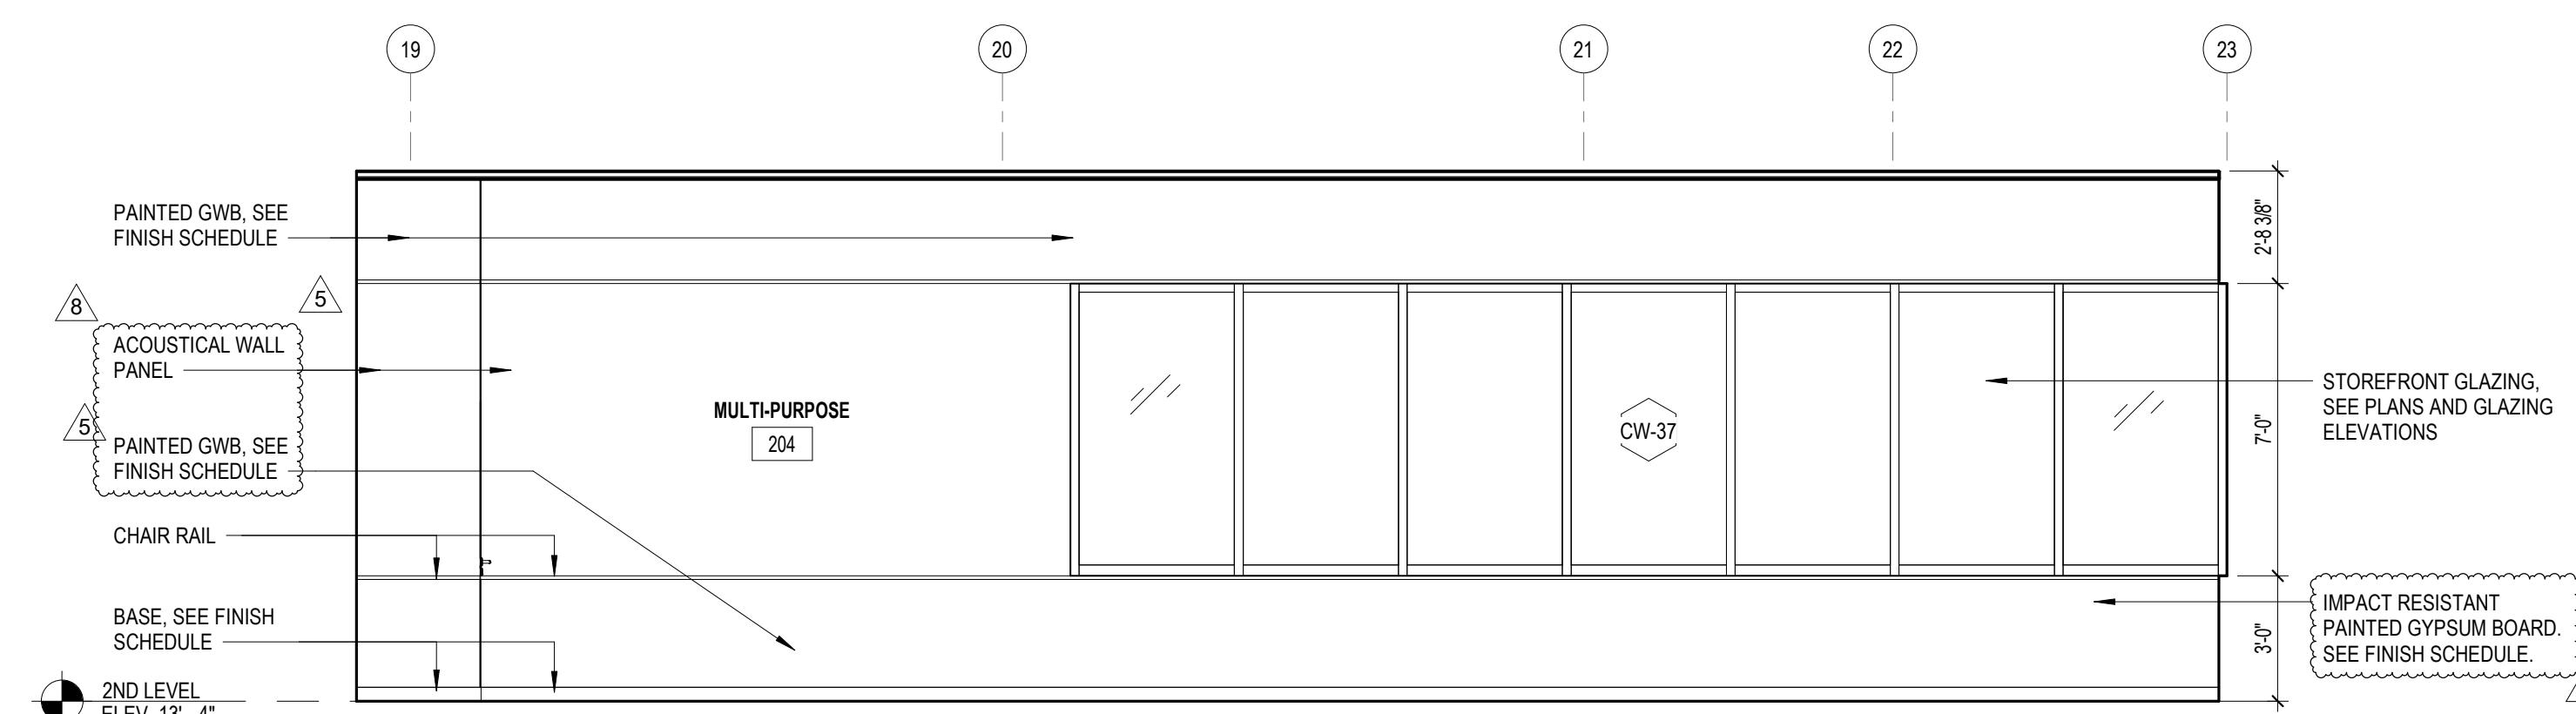


MULTI-PURPOSE 204 INTERIOR ELEVATION - NORTH

3 Scale: 1/4" = 1'-0"

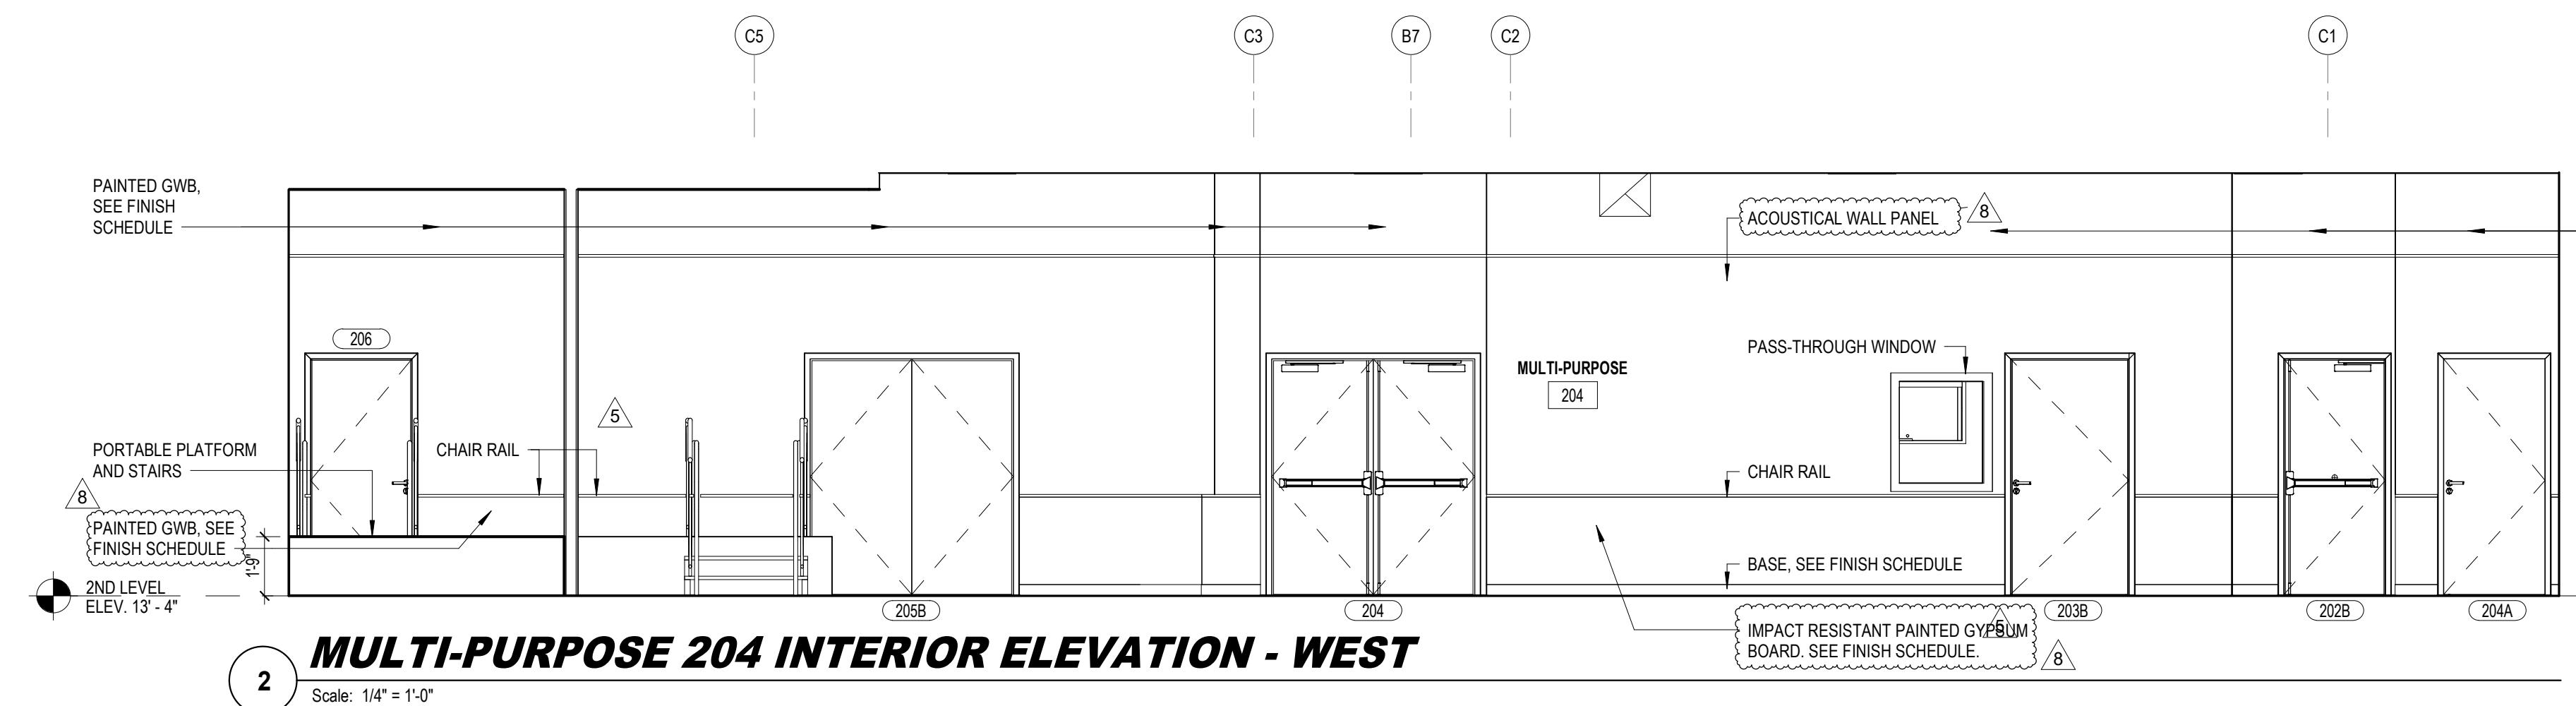

MULTI-PURPOSE 204 INTERIOR ELEVATION - WEST

2 Scale: 1/4" = 1'-0"

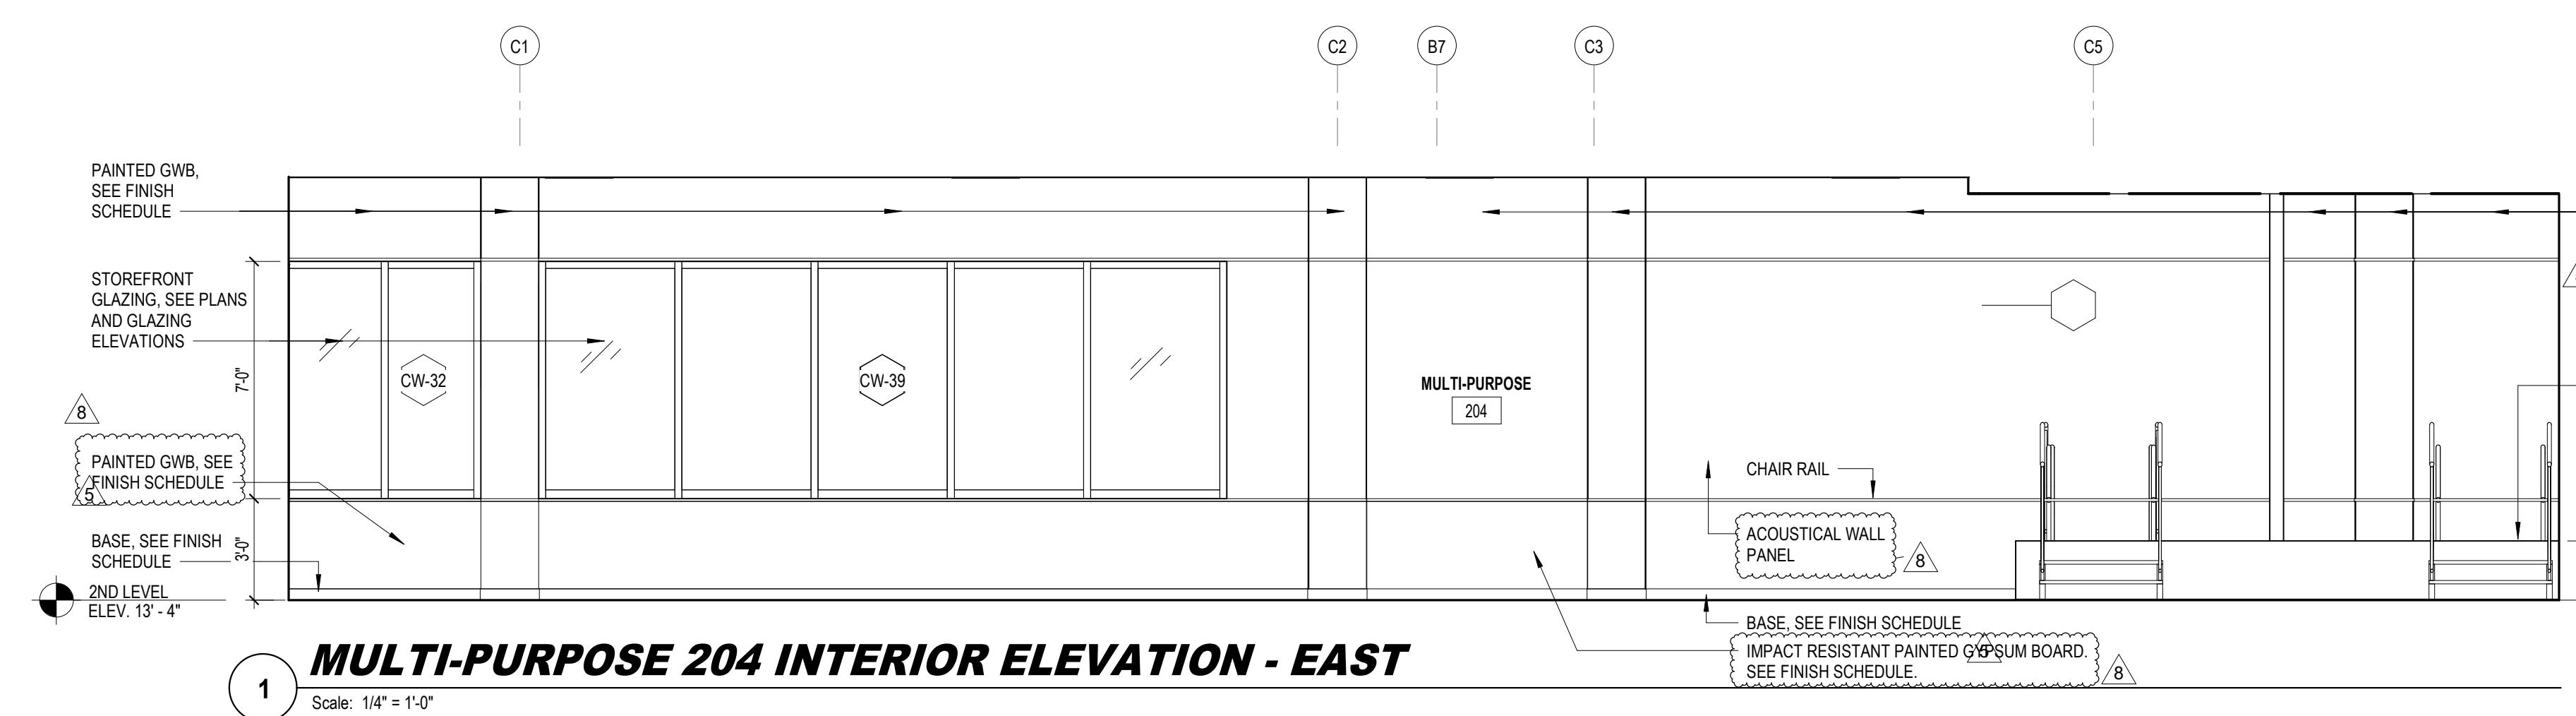

MULTI-PURPOSE 204 INTERIOR ELEVATION - EAST

Scale: 1/4" = 1'-0"

FINISH SCHEDULE NOTES

GYMNASIUM WALLS TO RECEIVE ACOUSTICAL PANELS ON WALLS.
TYPICAL AT BOTH LEVELS.

PADDING AT PERIMETER WALLS AT GYMNASIUM FLOOR LEVEL,
EXCLUDING AREAS DIRECTLY BEHIND BLEACHERS. AREAS DIRECTLY
BEHIND BLEACHERS TO BE PAINTED GYPSUM BOARD.

IMPACT RESISTANT GYPSUM WALL BOARD MIN. 8'-0" THROUGHOUT
TYPICAL), WHERE SPECIFIED IN FINISH SCHEDULE

PAINT EXPOSED ROOF STRUCTURE ABOVE. COLOR FLAT SW9179 -
ANCHOR AWEIGH. PAINT ALL EXPOSED STRUCTURE, DUCTWORK, ETC.
PROVIDE BLOCK FILLER AT ALL BLOCK WALLS WITH NON-ABSORBENT
EPOXY PAINT FINISH.

PAINT EXPOSED STRUCTURE IN B.O.H. ROOMS EXCEPT AS NOTED ON
THE FINISH SCHEDULE ON SHEET A-640.

ALL EXTERIOR OR NON A/C ROOMS TO HAVE M.R. BOARDS OR STUCCO
FINISH WITH NON-ABSORBENT PAINT FINISH.

PAPERLESS M.R. GYPSUM WALL BOARD PAINTED WITH NON-ABSORBENT
PAINT. TYPICAL FOR ALL INTERIOR RESTROOMS AND LOCKERS.


PAINT ALL EXPOSED CONCRETE CEILINGS WITH NON-ABSORBENT
PAINT. COLOR TO MATCH DECOR.

MILLWORK FINISH TO BE DEKTON LUNAR, SATIN SMOOTH,
MITERED/ROUNDED CORNERS.

CEMENTITIOUS BACKER BOARD SHALL BE USED FOR ALL TILE WALLS.
LOCKERS MANUFACTURED BY PRENCO. COLOR: REFLEX BLUE.

3/4" AC GRADE PLYWOOD PAINTED FRONT, BACK AND ALL SIDES WITH
FIRE RETARDANT PAINT. PLYWOOD SHALL BE MOUNTED ON ALL WALLS
OF THE ROOM, 8" FROM THE FLOOR EXTENDING TO THE CEILING.
REFER TO FLOOR PATTERN LAYOUT. 8

STAIR SHALL BE TILE FINISH. STEPS SHALL BE LAMBOO DESERT SAND.

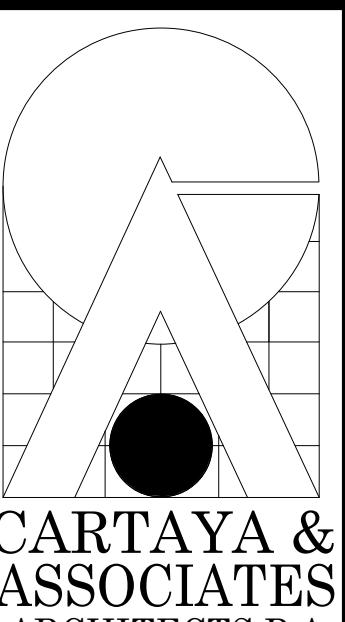

**CARTAYA &
ASSOCIATES
ARCHITECTS P.A.
cartayaandassociates.com**

2400 E. COMMERCIAL BLVD. SUITE 201
FT. LAUDERDALE, FLORIDA 33308
954-771-2724





EAL:

**CITY OF DELRAY BEACH
POMPEY PARK REC CENTER
1101 NW 2ND ST, DELRAY BEACH
FL 33444**




PROJECT: ALL DESIGNS AND PROPERTY OF CARTA
A PRINCIPLE OF THIS DESIGN AND NOTOPY THIS DESIGN


TITLE:	INTERIOR ELEVATIONS		
B NO:	2122		
DATE:	Dec 27, 2022		
DRAWN BY:	SV, CC, E		
CHECKED BY: JJ, LS, JS			

SHEET:
AI403

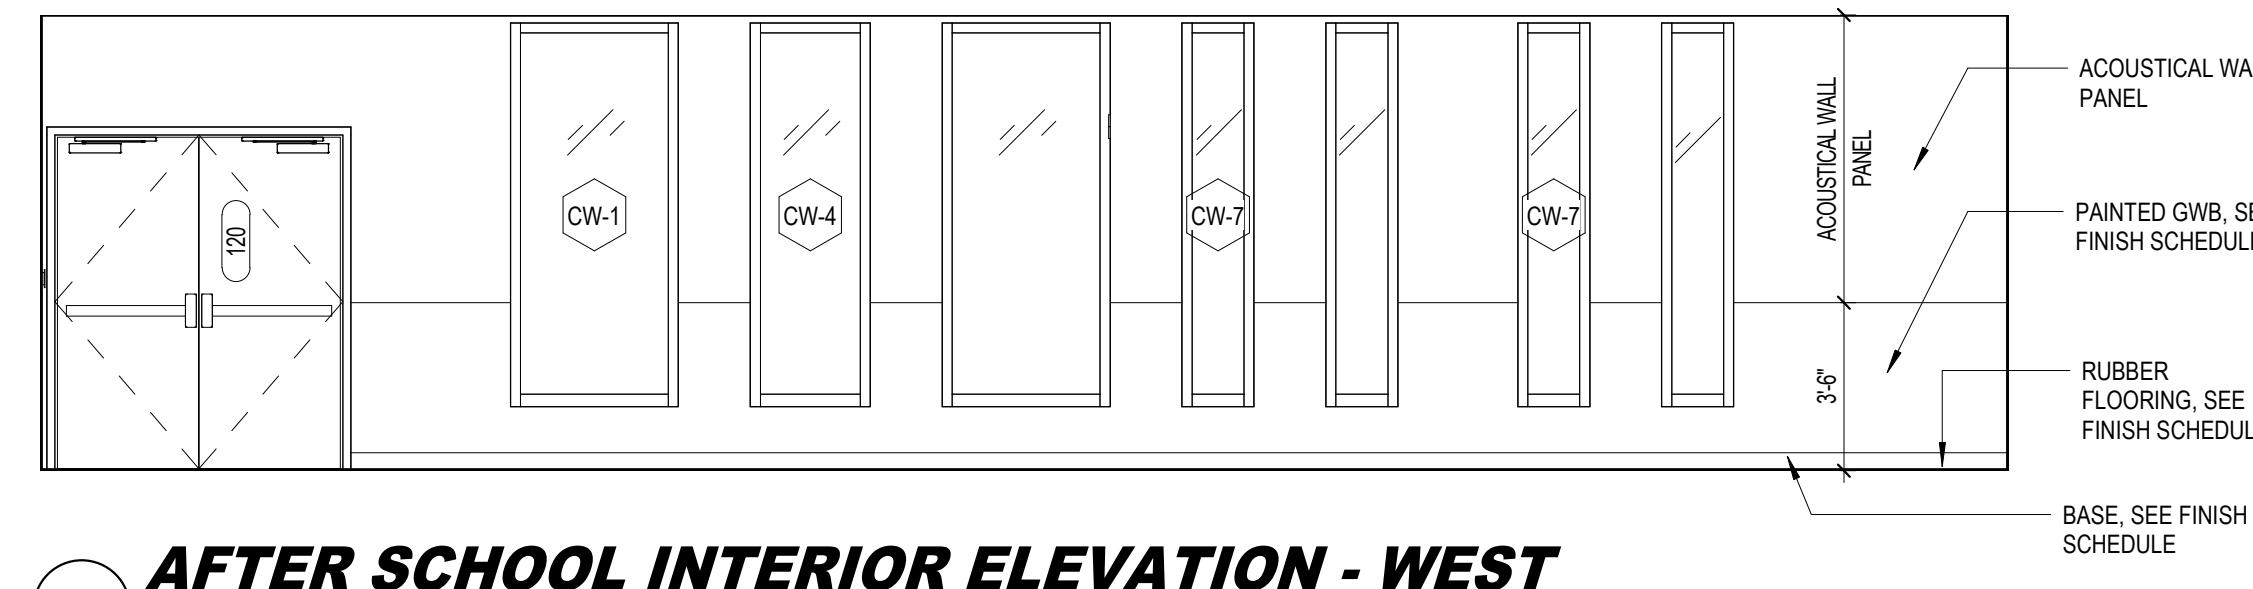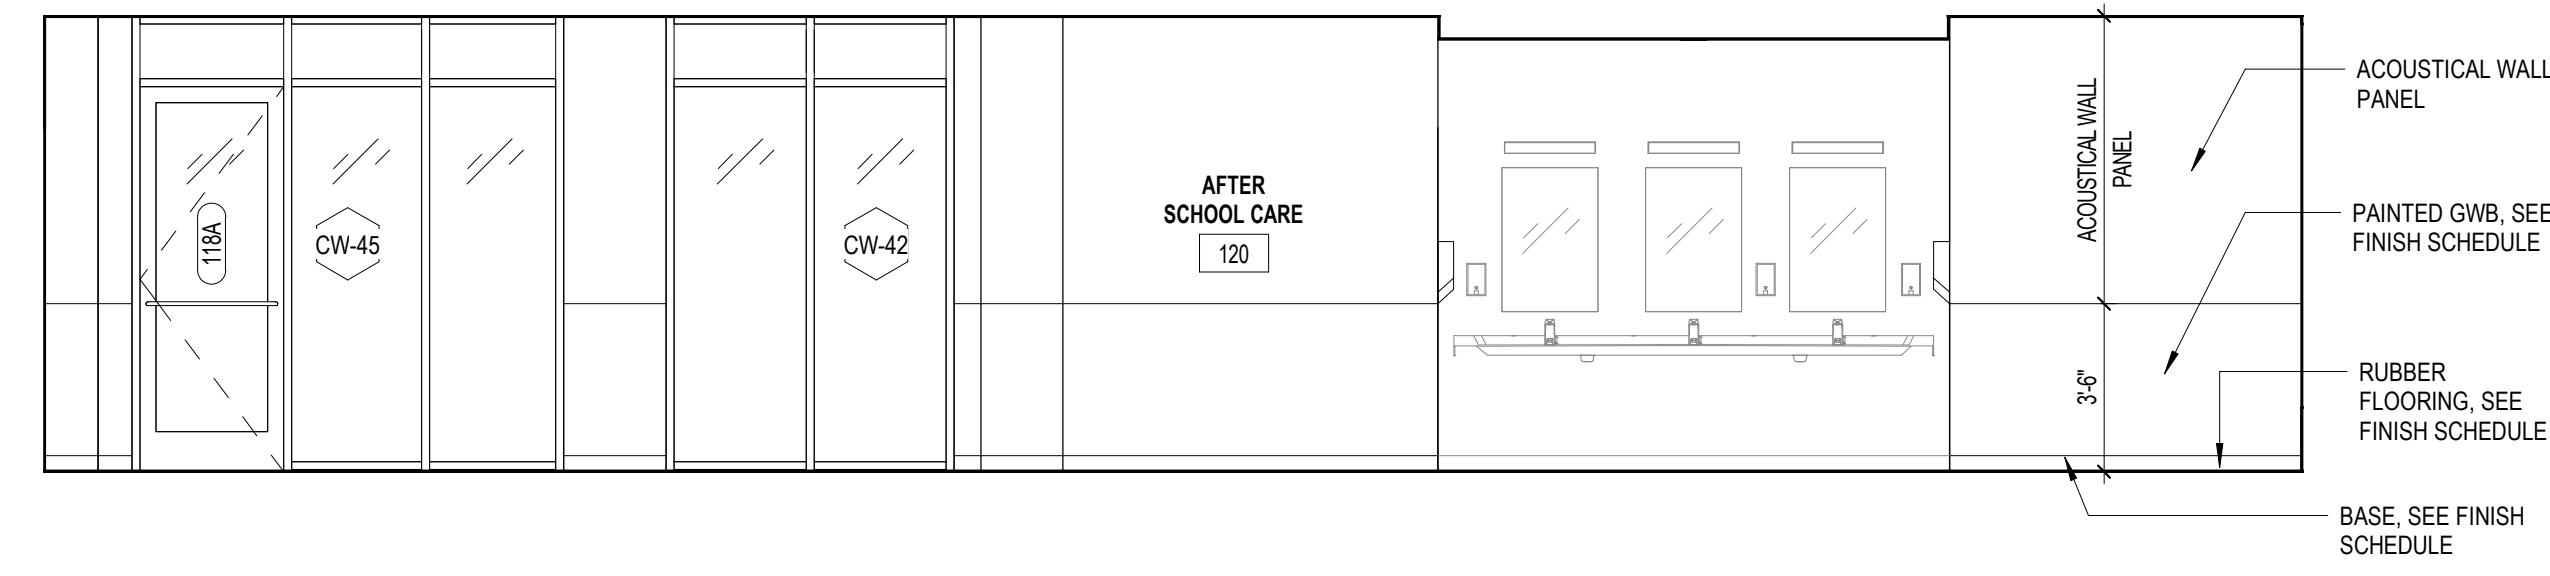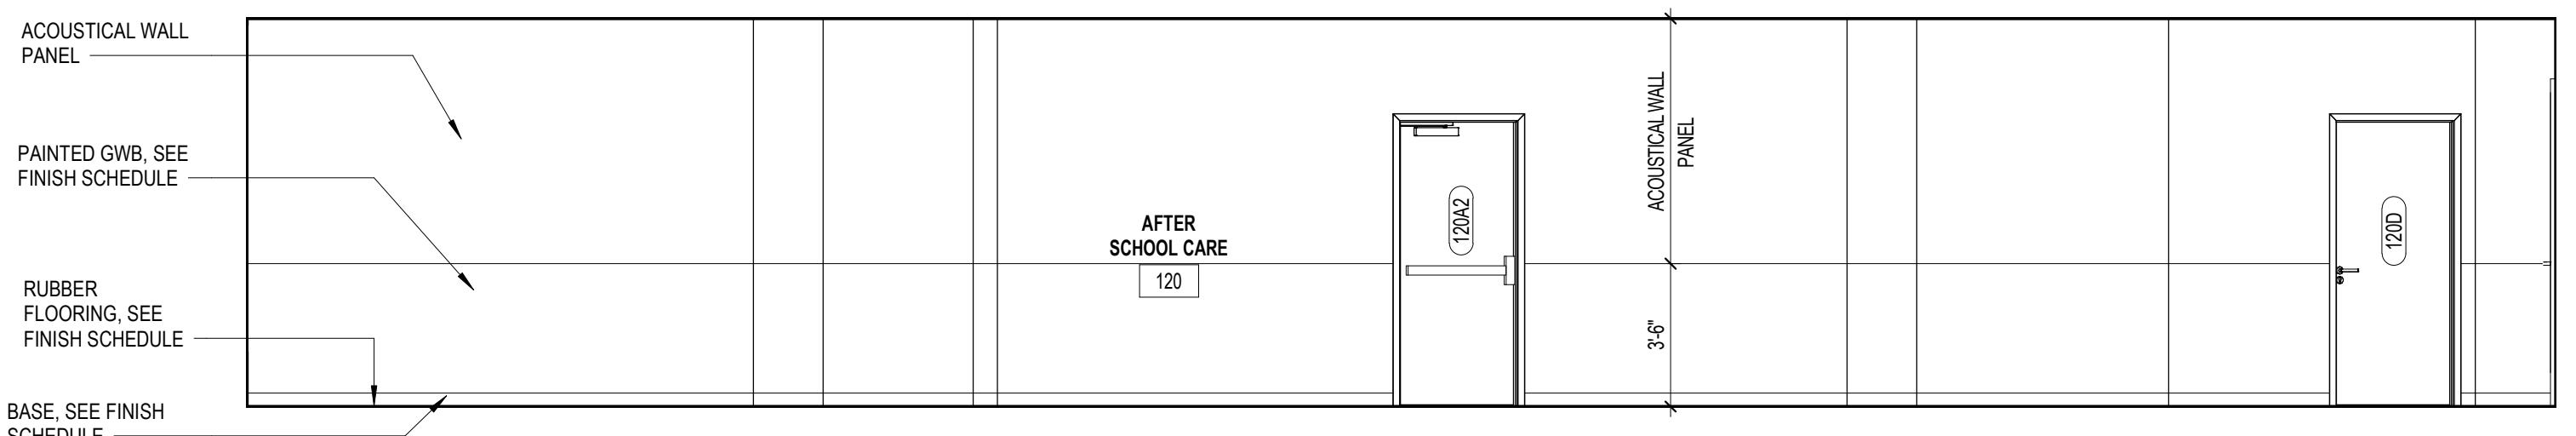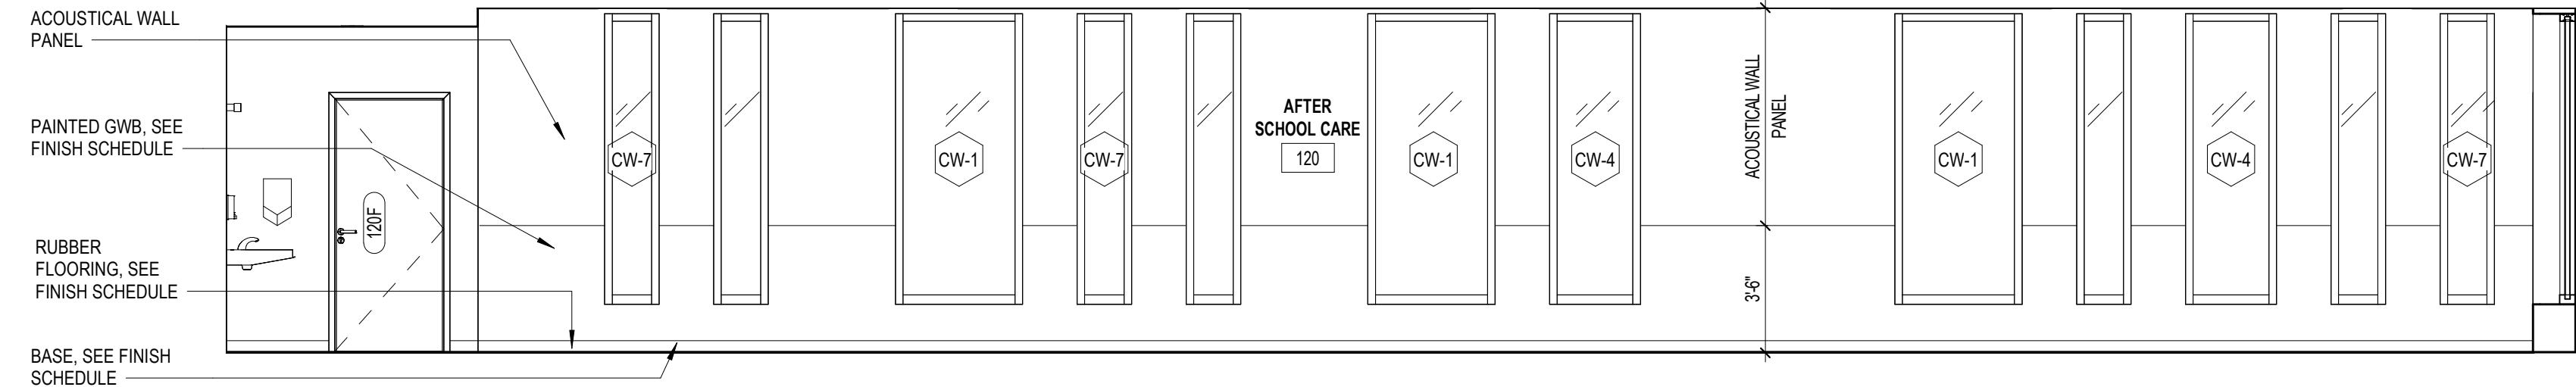**AFTER SCHOOL INTERIOR ELEVATION - WEST****AFTER SCHOOL INTERIOR ELEVATION - EAST****AFTER SCHOOL INTERIOR ELEVATION - NORTH****AFTER SCHOOL INTERIOR ELEVATION - SOUTH**

FINISH SCHEDULE NOTES	
1.	GYMNASIUM WALLS TO RECEIVE ACOUSTICAL PANELS ON WALLS.
2.	CEMENTITIOUS BACKER BOARD SHALL BE USED FOR ALL TILE WALLS. ADDITIONAL CEMENTITIOUS BACKER WALLS AT GYMNASIUM FLOOR LEVEL EXCLUDING AREAS DIRECTLY BEHIND BLEACHERS. AREAS DIRECTLY BEHIND BLEACHERS TO BE PAINTED GYPSUM BOARD.
3.	IMPACT RESISTANT GYPSUM WALL BOARD MIN. 8'-0" THROUGHOUT (TYPICAL) WHERE SPECIFIED IN FINISH SCHEDULE.
4.	PAINT EXPOSED ROOF STRUCTURE ABOVE COLOR FLAT SW9179 - ANCHOR AWEIGH. PAINT ALL EXPOSED STRUCTURE, DUCTWORK, ETC. PROVIDE BLOCC FILLER AT ALL BLOCK WALLS WITH NON-ABSORBENT EPOXY PAINT FINISH.
5.	PAINT EXPOSED STRUCTURE IN B.O.H. ROOMS EXCEPT AS NOTED ON THE FINISH SCHEDULE ON SHEET A-640.
6.	ALL EXTERIOR OR NON AC ROOMS TO HAVE M.R. BOARDS OR STUCCO FINISH WITH NON-ABSORBENT PAINT FINISH.
7.	PAPERLESS M.R. GYPSUM WALL BOARD PAINTED WITH NON-ABSORBENT PAINT FOR EXTERIOR RESTROOMS AND LOCKERS.
8.	PAINT ALL EXPOSED CONCRETE CEILINGS WITH NON-ABSORBENT PAINT, COLOR TO MATCH EXPOSED CONCRETE.
9.	10. MILLWORK FINISH TO BE DEKTON LUNAR, SATIN SMOOTH, MITERED/ROUNDED CORNERS.
11.	CEMENTITIOUS BACKER BOARD SHALL BE USED FOR ALL TILE WALLS. LOCKERS MANUFACTURED BY PRENCO, COLOR REFLEX BLUE.
12.	3/4" AC GRADE PLYWOOD PAINTED FRONT, BACK AND ALL SIDES WITH FIRE RETARDANT PAINT. PLYWOOD SHALL BE MOUNTED ON ALL WALLS OF THE ROOM, 8" FROM THE FLOOR EXTENDING TO THE CEILING.
13.	REFER FLOOR PATTERN LAYOUT 8
14.	15. STAIR SHALL BE TILE FINISH. STEPS SHALL BE LAMBOO DESERT SAND.

   

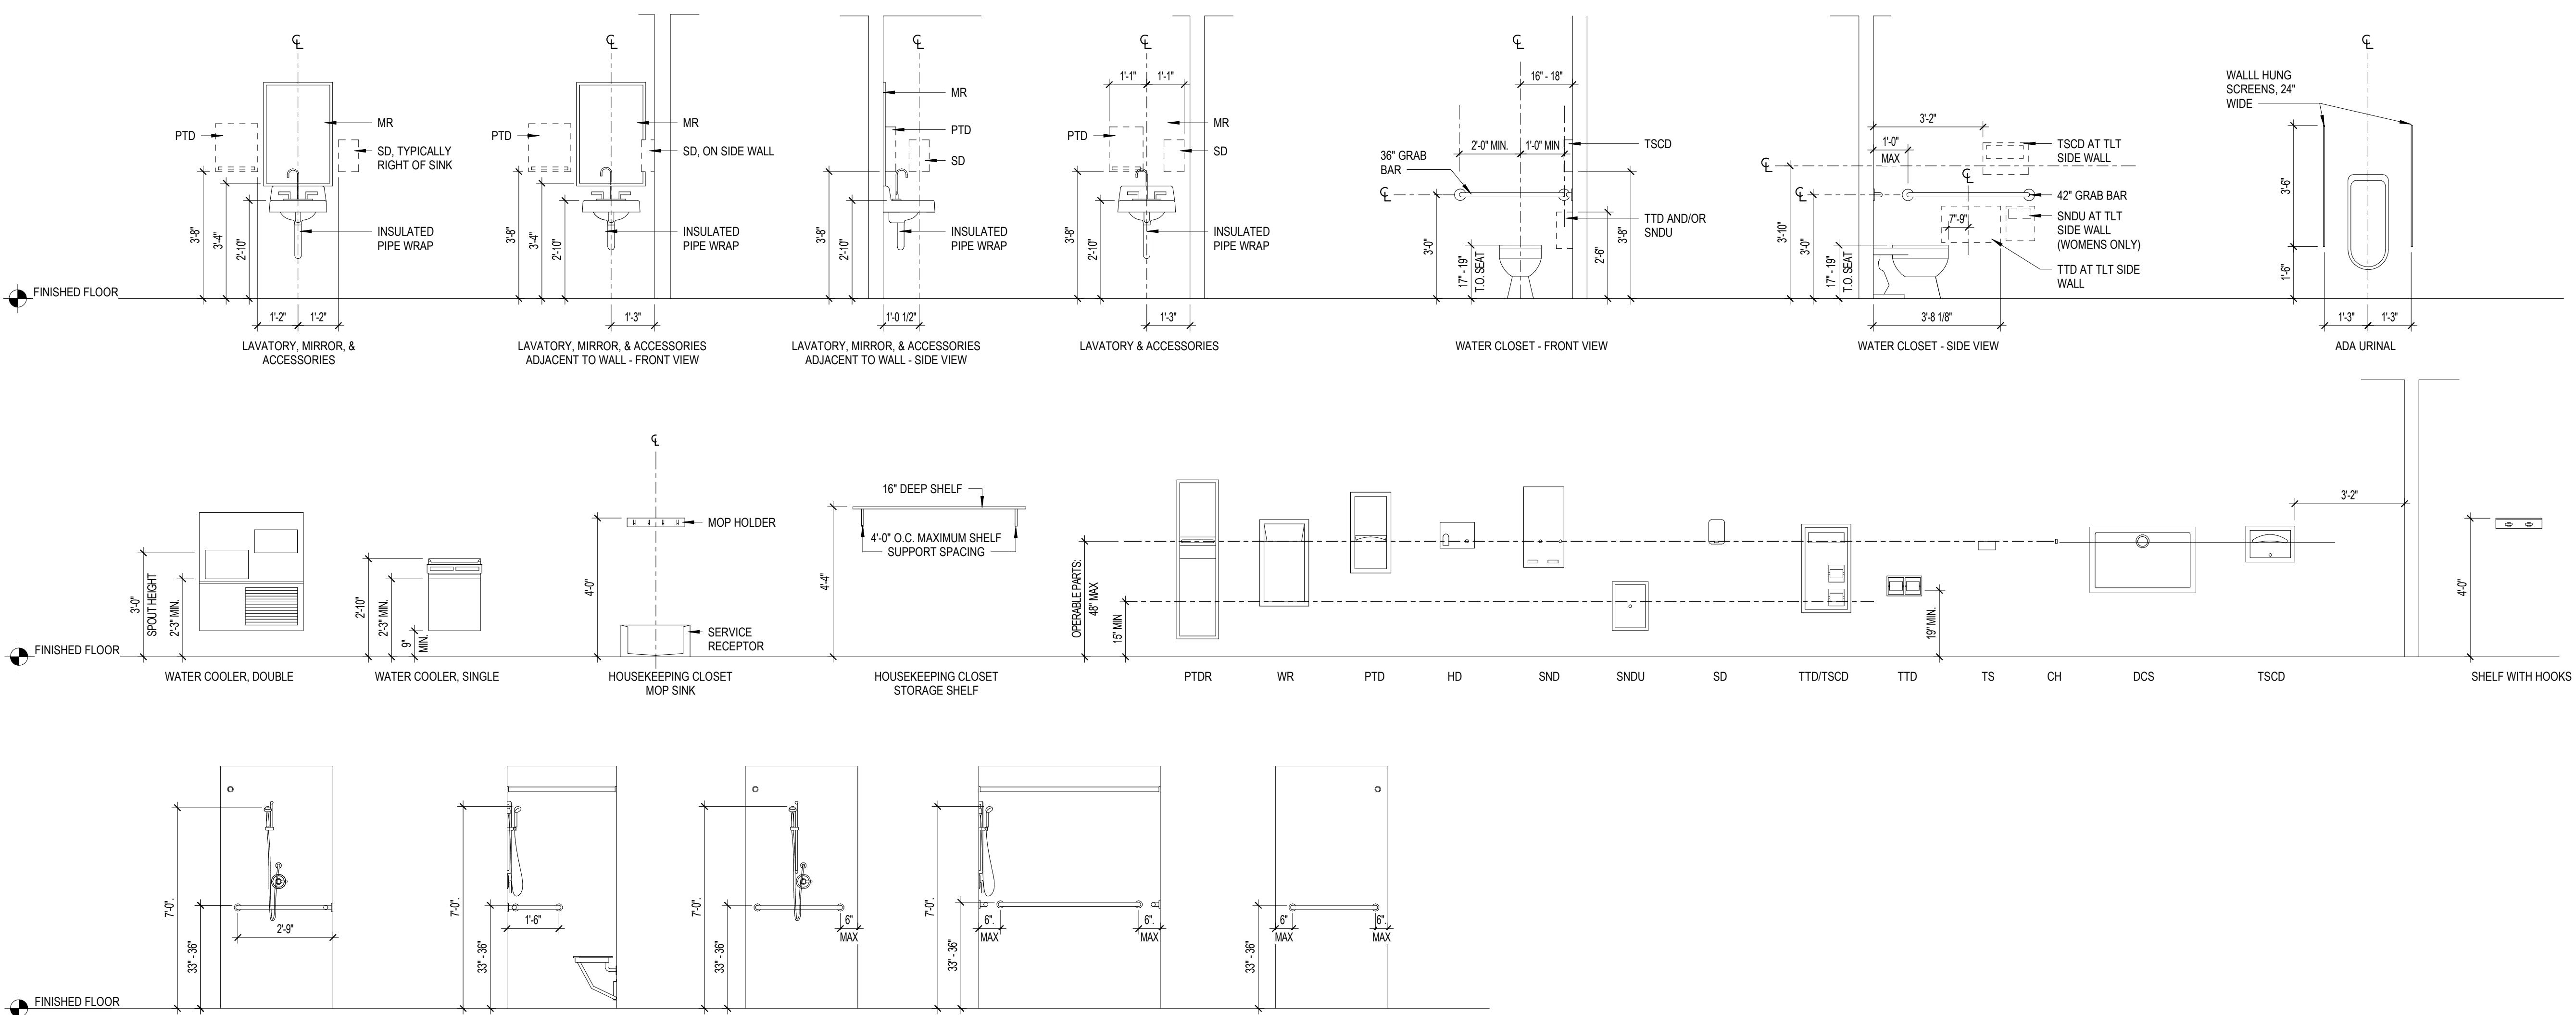


SANITARY ACCESSORIES LIST

<u>ABBREVIATIONS</u>	<u>DESCRIPTIONS</u>
S	COAT HOOK
D	DIAPER CHANGING STATION
H	HAND DRYER
P	PAPER TOWEL DISPENSER
W	PAPER TOWEL DISPENSER / WASTE
R	RECEPACLE
S	SOAP DISPENSER
N	SANITARY NAPKIN DISPENSER
DU	SANITARY NAPKIN DISPOSAL UNIT
SH	SHOWER SEAT
T	TOILETRY SHELF
T	TOILET TISSUE DISPENSER
SC	TOILET SEAT COVER DISPENSER
WR	WASTE RECEPTACLE
M	MIRROR

TE:

FIXTURES AND ACCESSORIES ARE TO BE MOUNTED TO COMPLY
WITH FLORIDA PLUMBING, ELECTRICAL, MECHANICAL, AND
ACCESSIBILITY CODE.

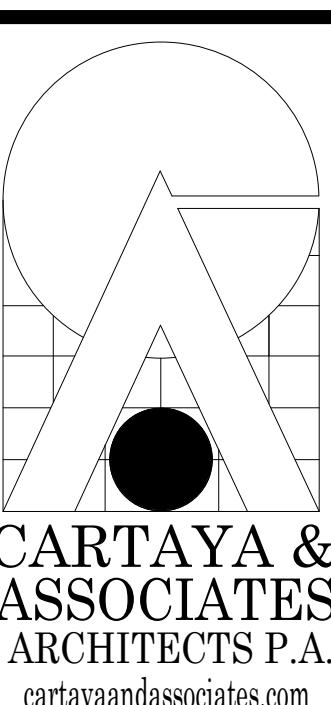


**CARTAYA &
ASSOCIATES
ARCHITECTS P.A.**
cartayaandassociates.com


2400 E. COMMERCIAL BLVD. SUITE 201
FT. LAUDERDALE, FLORIDA 33308
954-771-2724

AA C001388

PLUMBING AND ACCESSORIES

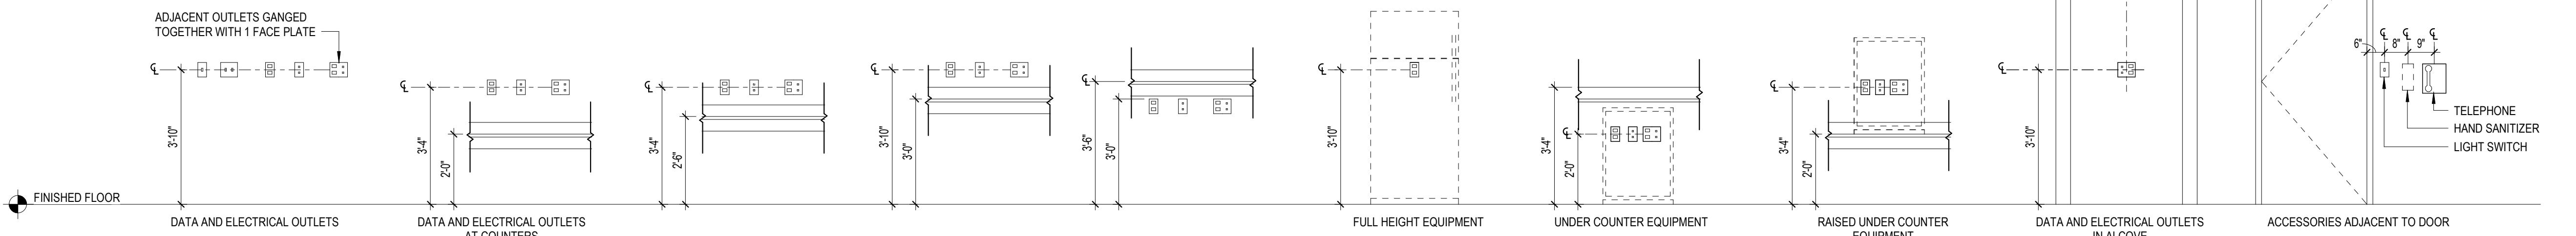

MECHANICAL, ELECTRICAL, COMMUNICATIONS, AND FIRE PROTECTION

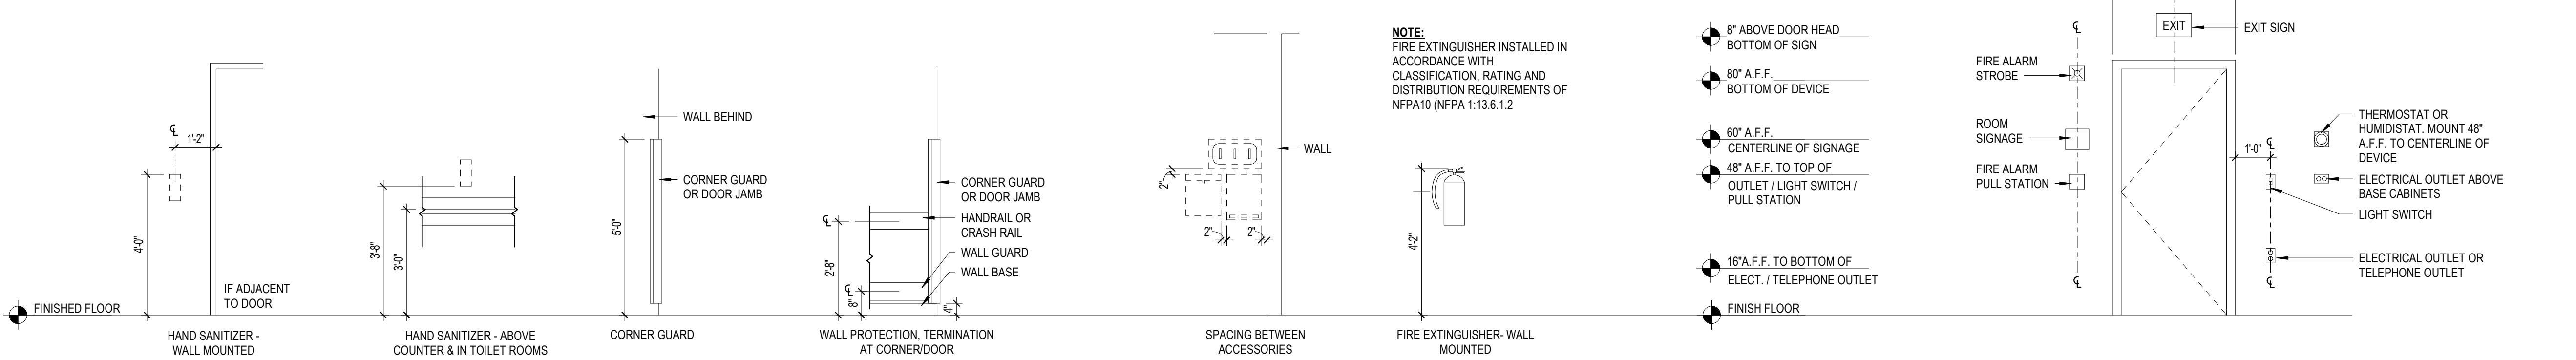

ACCESSORIES

WALL PROTECTION

TYPICAL DEVICE PLACEMENT


CONFIRMED SET 09/22/2025

1

AI410


AI410

NOTE: ATTACH GRAB BARS WITH FASTENERS (AS APPROVED BY MANUFACTURER) THAT WILL ALLOW FOR A 250 POUND VERTICAL LOADING OF THE GRAB BAR. COMPLY WITH STRUCTURAL LOADING REQUIREMENTS AS INDICATED IN NOTE 1. ALL PENETRATIONS BEHIND GRAB BAR SUPPORTS SHALL BE SEALED TO MAINTAIN INTEGRITY OF WALLS/PARTITIONS/BARRIERS.

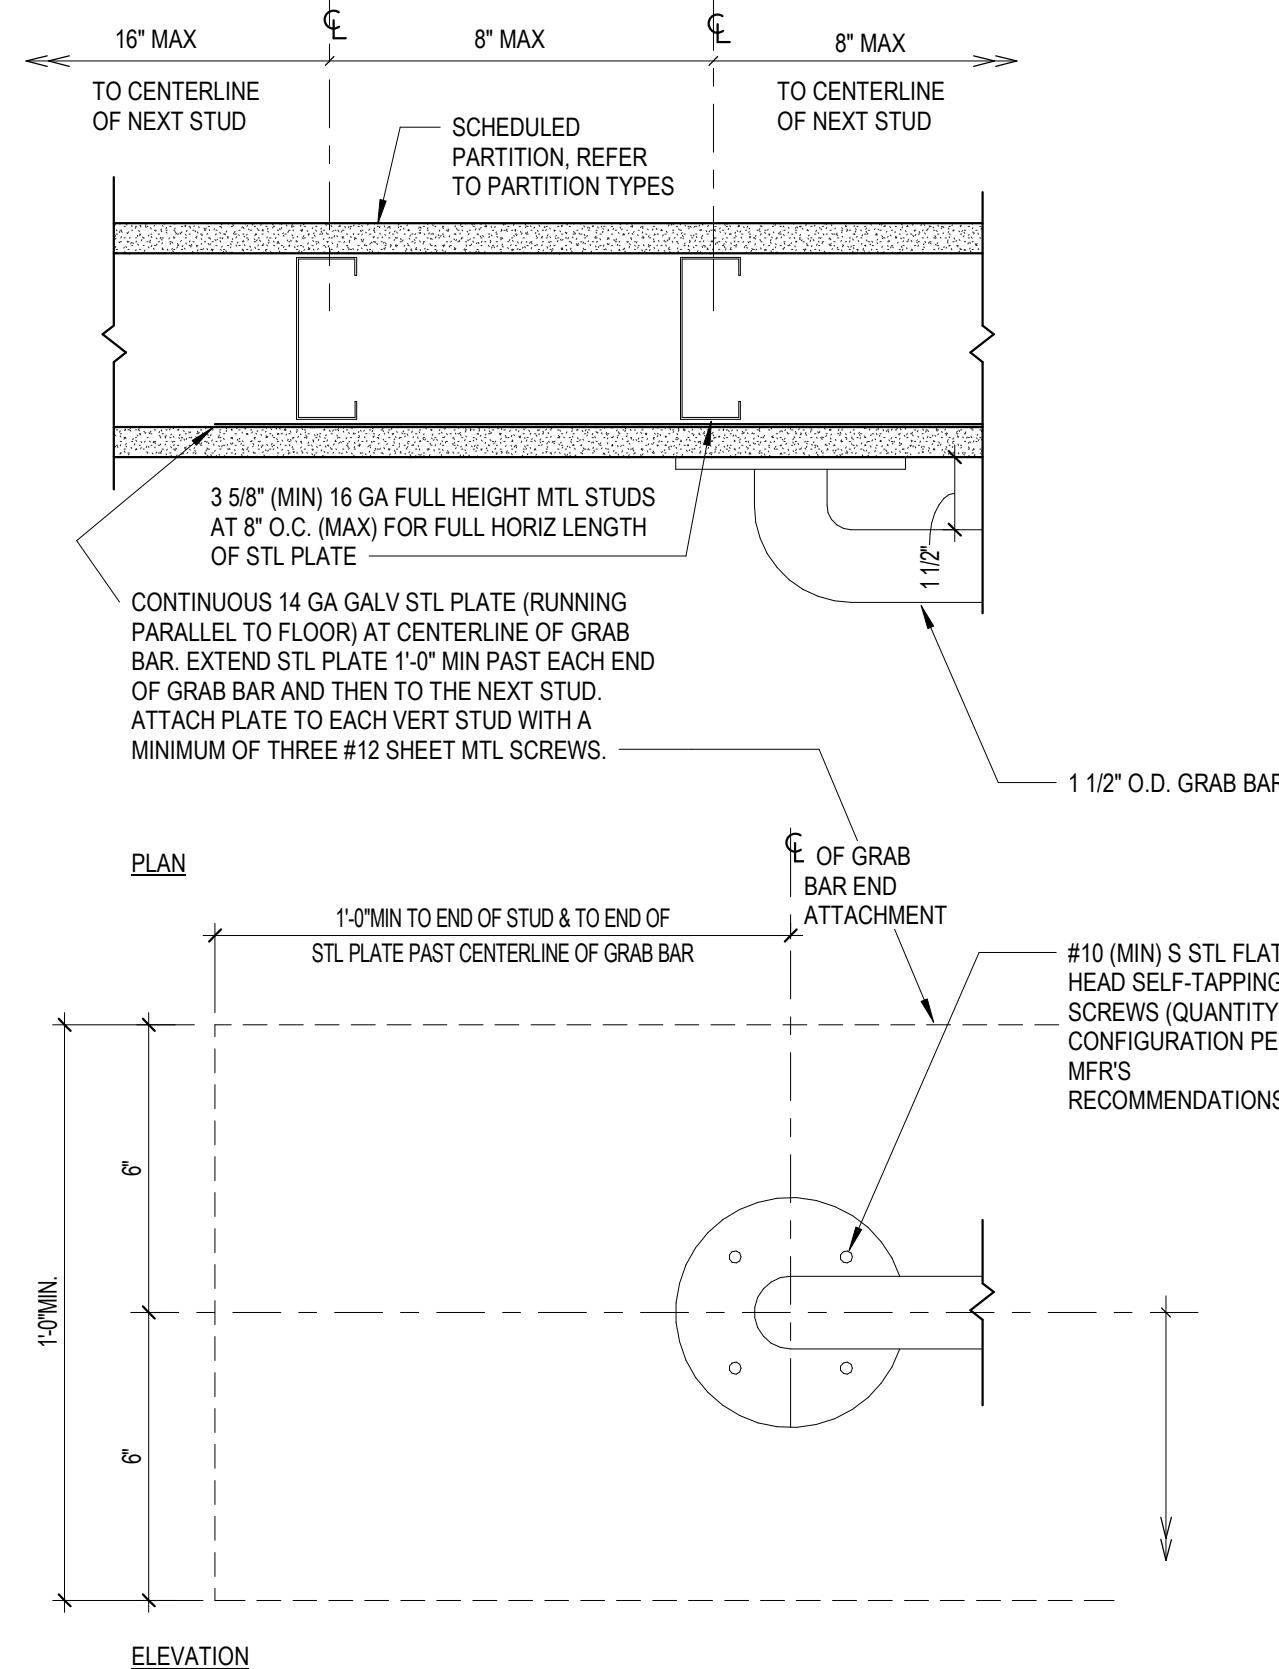


GRAB BAR ATTACHMENT AT WALLS/PARTITIONS

Scale: N.T.S.

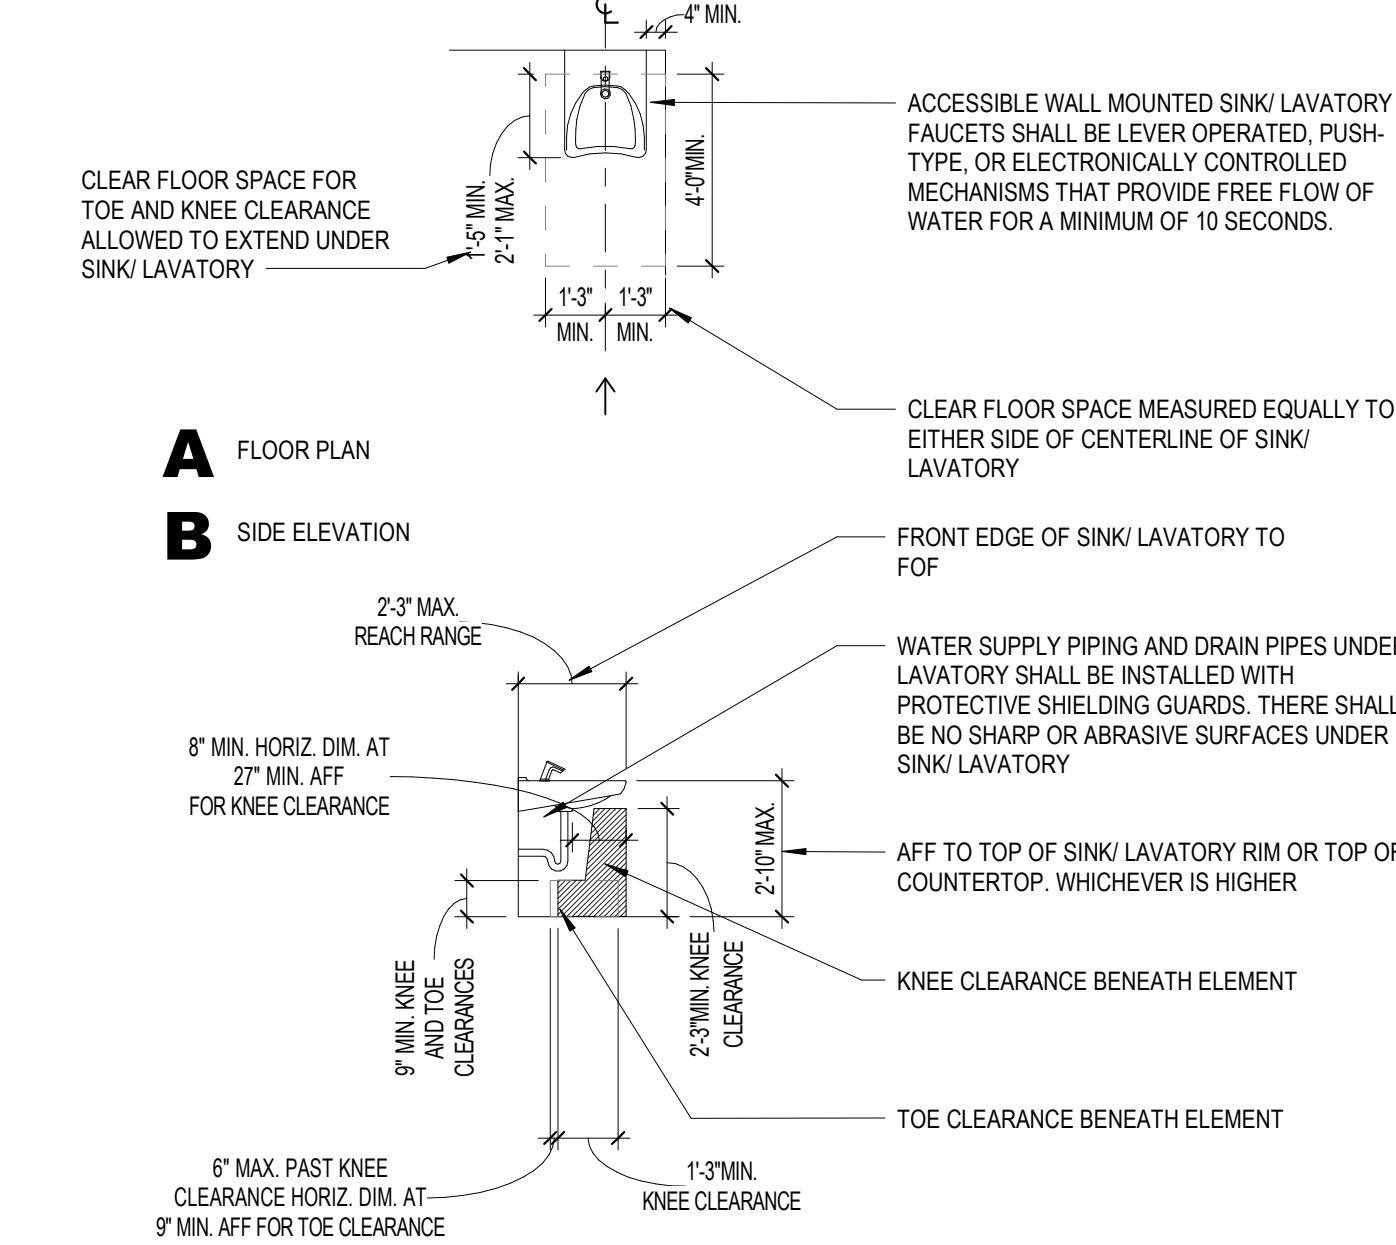


TYP. ACCESSIBLE WALL MOUNT SINKS & LAVATORIES

Scale: N.T.S.

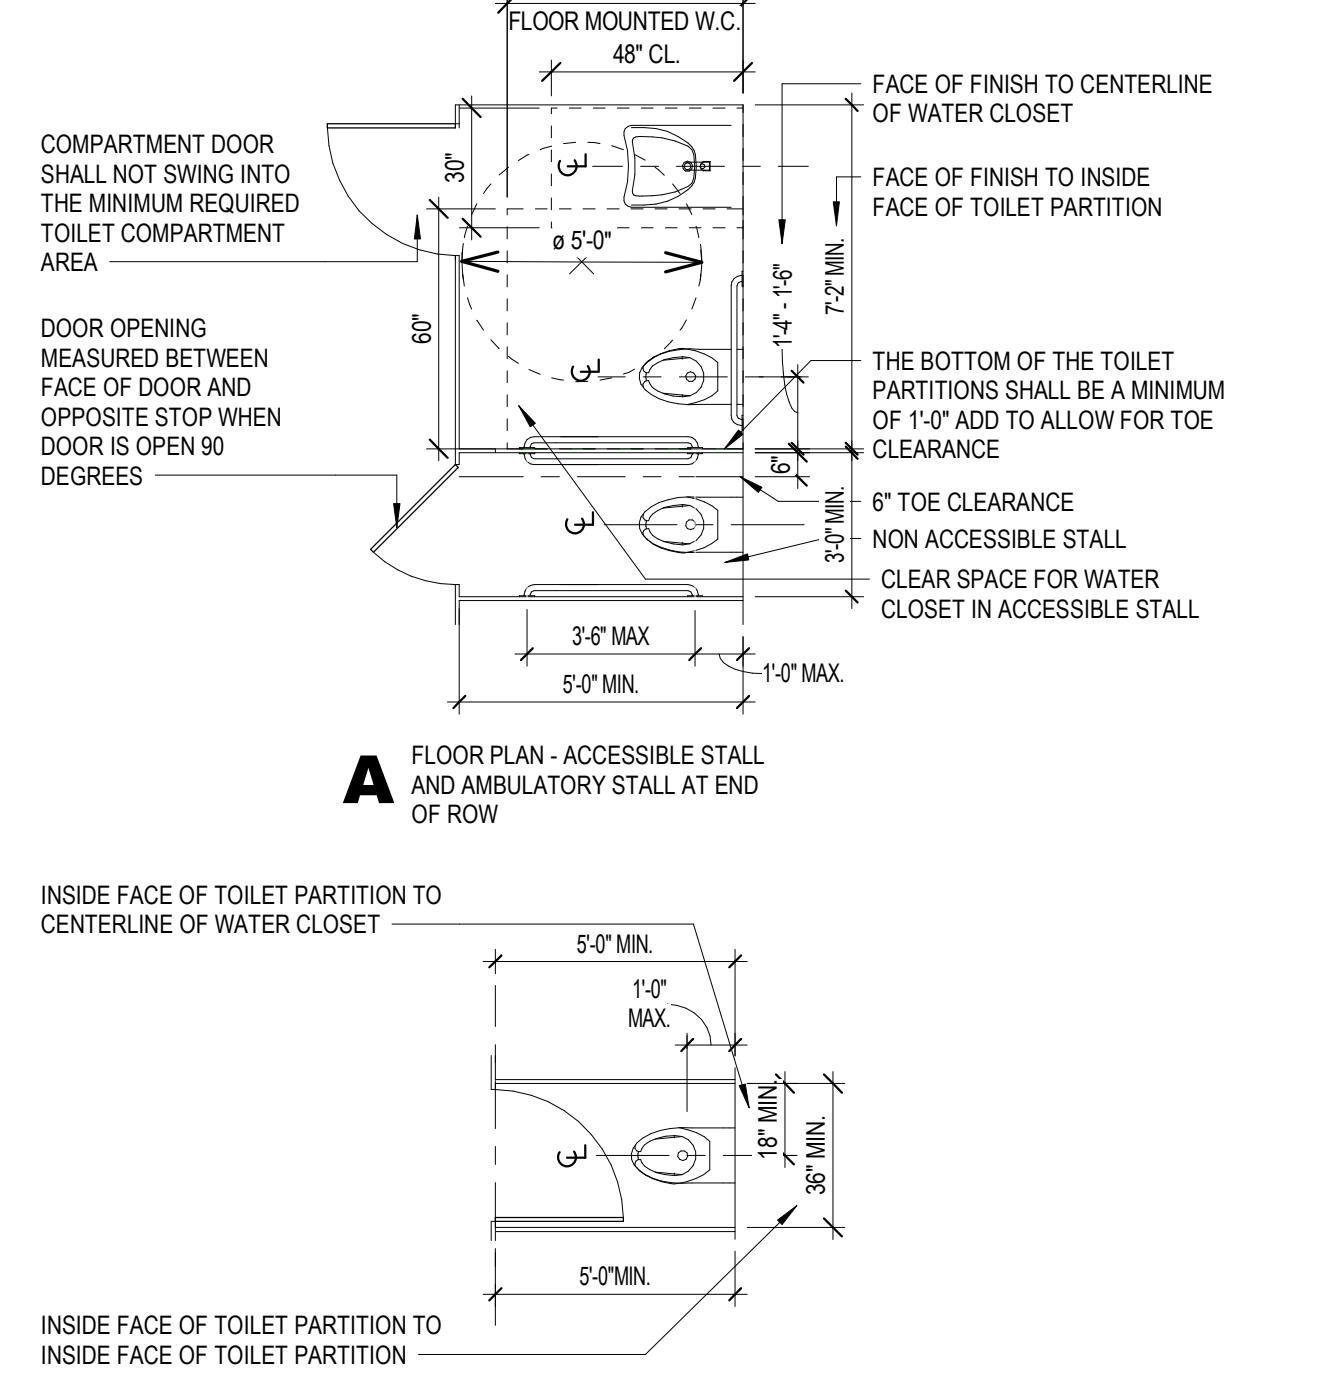

TYP. ACCESSIBLE TOILET STALLS

Scale: N.T.S.

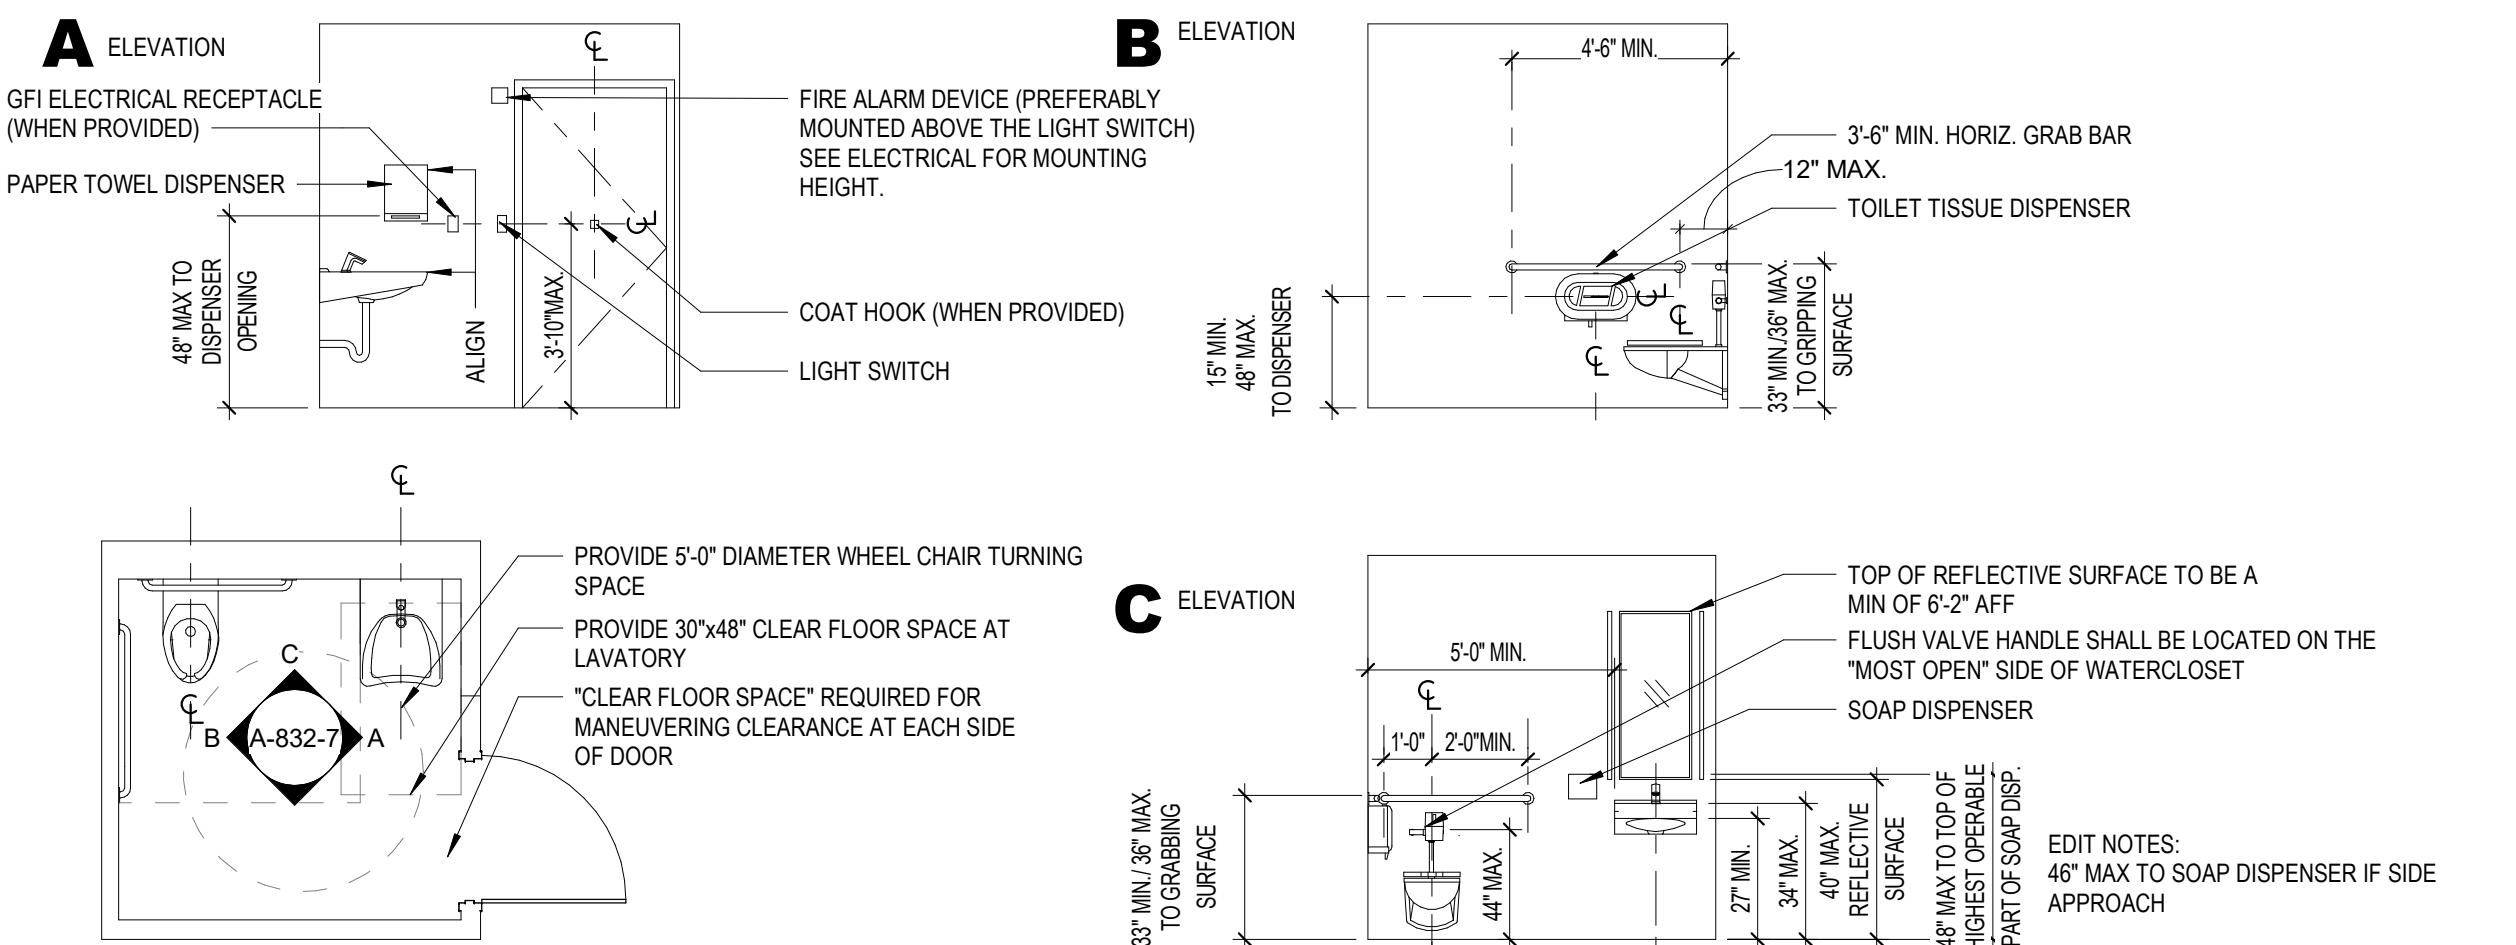

TYP. ACCESSIBLE TOILET ROOM FLOOR PLAN AND ELEVATIONS

Scale: N.T.S.

TYP. RESTROOM NOTES	
TYPICAL TOILET PARTITION NOTES:	TYPICAL RESTROOM INTERIOR FINISH WALL NOTES:
1. SOLID PLASTIC TEXTURED (HDPE) PANELS 2. FLOOR MTD. OVERHEAD BRACED 3. 72" HIGH, MODULAR PANELS 4. NFPA 286, CLASS "A" 5. S.S. HARDWARE NO PLASTICS 6. 7" CONTINUOUS HINGES 7. SPRING LOADED HINGES 8. REFERENCE COLOR SCHEDULE AND ELEVATIONS 9. CONTINUOUS BRACKETS 10. CONTINUOUS HEAD RAIL ABOVE 11. MANUFACTURER: SCRANTON PRODUCTS. HINY HIDERS PARTITIONS. HIGH PRIVACY OPTION.	1. APPLY BLOCK FILLER TO ALL INTERIOR WALLS 2. APPLY MIN. 1 PRIMER: PRIMER COAT WITH MIN. 2 FINISH COATS, FOLLOW MANUFACTURER RECOMMENDATION
TYPICAL WATER CLOSET NOTES:	TYPICAL WATER CLOSET NOTES:
1. WATER CLOSET AND URINAL STANDARD FLUSH MECHANISM, NO SENSORS 2. WALL HUNG TOILET ON CARRIERS 3. ALL ADA COMPLIANT	1. WATER CLOSET AND URINAL STANDARD FLUSH MECHANISM, NO SENSORS 2. WALL HUNG TOILET ON CARRIERS 3. ALL ADA COMPLIANT
GENERAL RESTROOM COMPLIANCE NOTES:	GENERAL RESTROOM COMPLIANCE NOTES:
1. REFERENCE LIFE SAFETY PLAN FOR FIRE EXTINGUISHER LOCATIONS 2. ALL DEVICES ARE TO BE ADA COMPLIANT 3. FOR ALL DEVICES AND INSTALLATION, FOLLOW IBC LATEST EDITION, ADA & ALLAPPLICABLE CODES AND REGULATIONS 4. ALL ADA COMPLIANT	1. REFERENCE LIFE SAFETY PLAN FOR FIRE EXTINGUISHER LOCATIONS 2. ALL DEVICES ARE TO BE ADA COMPLIANT 3. FOR ALL DEVICES AND INSTALLATION, FOLLOW IBC LATEST EDITION, ADA & ALLAPPLICABLE CODES AND REGULATIONS 4. LEVEL FLUSH TRANSITION AT ALL FLOORS AND ENTRANCES
TYPICAL LAVATORY NOTES:	TYPICAL LAVATORY NOTES:
1. VITREOUS CHINA BOWL MATERIAL 2. FAUCETS MANUAL, NO SENSOR 3. WALL HUNG LAVATORIES 4. FLOOR MOUNTED CONCEALED ARM CARRIERS WILL BE PROVIDED FOR WALL HUNG LAVATORIES 5. ALL ADA COMPLIANT	1. VITREOUS CHINA BOWL MATERIAL 2. FAUCETS MANUAL, NO SENSOR 3. WALL HUNG LAVATORIES 4. FLOOR MOUNTED CONCEALED ARM CARRIERS WILL BE PROVIDED FOR WALL HUNG LAVATORIES 5. ALL ADA COMPLIANT
TYPICAL RESTROOM VESTIBULE WALL FINISH:	TYPICAL RESTROOM VESTIBULE WALL FINISH:
1. SMOOTH STUCCO FINISH 2. COLOR, REFERENCE COLOR CHART	1. SMOOTH STUCCO FINISH 2. COLOR, REFERENCE COLOR CHART


PUBLIC RESTROOM FIXTURE SCHEDULE		
#	TOILET ACCESSORIES DESCRIPTION	MANUFACTURER / MODEL #
A	GRAB BAR 36" LONG HEAVY DUTY STAINLESS STEEL	BRADLEY 812 SERIES #812D-001136
B	GRAB BAR 42" LONG HEAVY DUTY STAINLESS STEEL	BRADLEY 812 SERIES #812D-00142
C	SURFACE MOUNTED SOAP DISPENSER	BRADLEY 6542
D	TOILET TISSUE DISPENSER SURFACE MOUNTED (SINGLE JUMBO 9" ROLL)	GLOBAL PLASTIC JUMBO 9" ROLL
E	SURFACE MOUNTED NAPKIN DISPOSAL, STAINLESS STEEL	BRADLEY 4722 SERIES #4722-15
F	PARTITION MOUNTED NAPKIN DISPOSAL STAINLESS STEEL	BRADLEY 4721 SERIES #4721-15
G	NOT USED	-
H	BABY CHANGING STATION, LIGHT GREY MOLDED (HIGH DENSITY POLYETHYLENE)	BABY CHANGING STATION BRADLEY 9631
J	FLOOR MOUNTED OVERHEAD BRACED SOLID PLASTIC RESTROOM PARTITIONS	SCRANTON PRODUCTS - HINY HIDERS SERIES
K	URINAL SCREEN	SCRANTON PRODUCTS - HINY HIDERS SERIES
L	STAINLESS STEEL UTILITY SHELF	BRADLEY 9933 4 HOOKS 3 HOLDERS
M	VERGE LAVATORY SYSTEM	BRADLEY LVL SERIES WSOAP DISPENSER
N	ADJUSTABLE MOTOR SENSORED HANDS DRYER	DYSON AIRBLADE V AB12-HUD
O	STAINLESS STEEL FRAMED MIRROR 24"X36"	BRADLEY MODEL 781-243
P	GARBAGE CAN	BY GENERAL CONTRACTOR (SHOWN FOR REFERENCE LOCATION)
Q	LAVATORY IN HANDICAP STALL (WALL-HUNG)	SEE PLUMBING SCHEDULE
R	RESTROOM MIRROR	BRADLEY 781
S	RESTROOM MIRROR	BRADLEY 781
T	HEAVY DUTY COMMERCIAL PLASTIC TOILET SEAT	BEMIS COMMERCIAL MODEL 1655 SSCT
U	WATER CLOSET FLUSHOMETER (NO AUTO SENSORS)	SEE PLUMBING SCHEDULE
V	URINAL FLUSHMETERS (NO AUTO SENSORS)	SEE PLUMBING SCHEDULE
W	WATER CLOSET (WALL-MOUNTED)	SEE PLUMBING SCHEDULE
X	URINAL	SEE PLUMBING SCHEDULE
Y	FAUCET	GALILEO 650/ 680 SERIES
Z	PAPER TOWEL DISPENSER WITH WASTE BASKET COMBINATION	BOBRICK B-38049
D.F.	BI-LEVEL VANDAL RESISTANT WATER COOLER (DRINKING FOUNTAIN)	ELKAY MODEL LZSTL8WSK3 WITH BOTTLE FILLING STATION AND FILTERS

NOTE:

1. ALL NOTES PROVIDED UNDER CONTRACT.
2. ONLY ITEMS NOTED BY OWNER ARE TO BE EXCLUDED. ALL OTHER FIXTURES ARE INCLUDED TO BE PROVIDED UNDER CONTRACT.


PROJECT: CITY OF DELRAY BEACH POMPEY PARK REC CENTER	
1101 NW 2ND ST. DELRAY BEACH FL 33444	
CONFORMED SET 09/22/2025	REVISIONS: 5 02-09-2024 REVISION 5 19-22-2025 CONFORMED SET
TITLE: ENLARGED RESTROOM PLANS AND ELEVATIONS	
DRAWN BY: SV, CC, FE, LS	
CHECKED BY: J.J., LS, JS	
DATE: Dec 27, 2022	
JOB NO: 2122	
SHEET: AI411	
NOTE: GYPSUM BOARD NOT SHOWN FOR CLARITY	
CONT. 6x54 UNPUNCHED BACKING TRACK, NOTCH TIGHT TO STUD	
(3) #10 SHEET METAL SCREWS AT EACH STUD	
DO NOT CUT FLANGES OF SUPPORT STUDS	

ALL DESIGN AND DATA IS PROVIDED BY THIS DRAWING AND IS CONFINED TO THE SPECIFIED PROJECT. THIS IS THE PROPERTY OF THE OWNER AND IS FOR THE USE ONLY AND CONFIDENTIALITY. THE CONTRACTOR SHALL NOT REPRODUCE, COPY, OR DISTRIBUTE THIS DRAWING OR ANY PORTION THEREOF, IN WHOLE OR IN PART, WITHOUT THE WRITTEN CONSENT OF THE OWNER. THE CONTRACTOR AGREES TO HOLD IN CONFIDENTIALITY ALL INFORMATION CONTAINED IN THIS DRAWING AND NOT TO DISCLOSE IT TO ANY OTHER PERSON, FIRM, OR COMPANY.

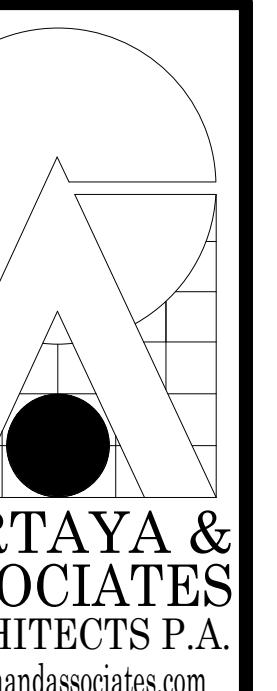


2400 E. COMMERCIAL BLVD. SUITE 201
FT. LAUDERDALE, FLORIDA 33308
954-771-2724

AA C001388
SEAL:

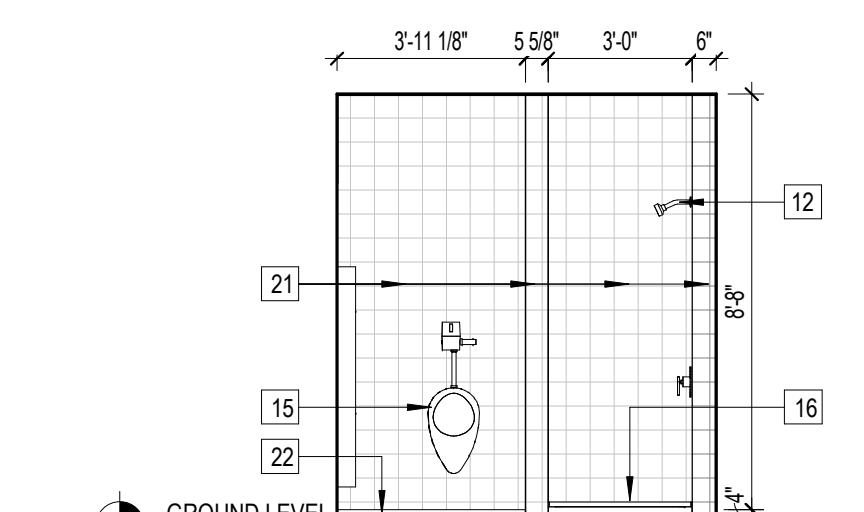


6 RESTROOM ELEVATION
Scale: 1/4" = 1'-0"

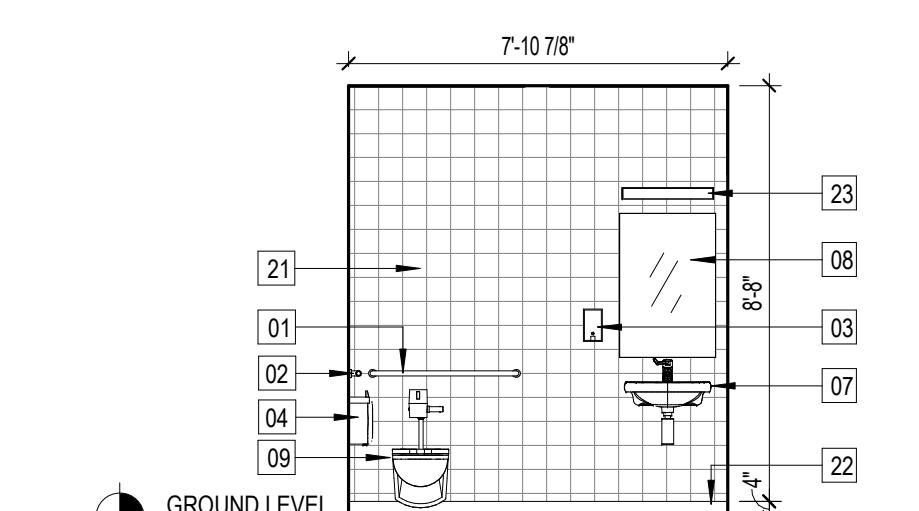


5 RESTROOM ELEVATION
Scale: 1/4" = 1'-0"




4 RESTROOM ELEVATION
Scale: 1/4" = 1'-0"

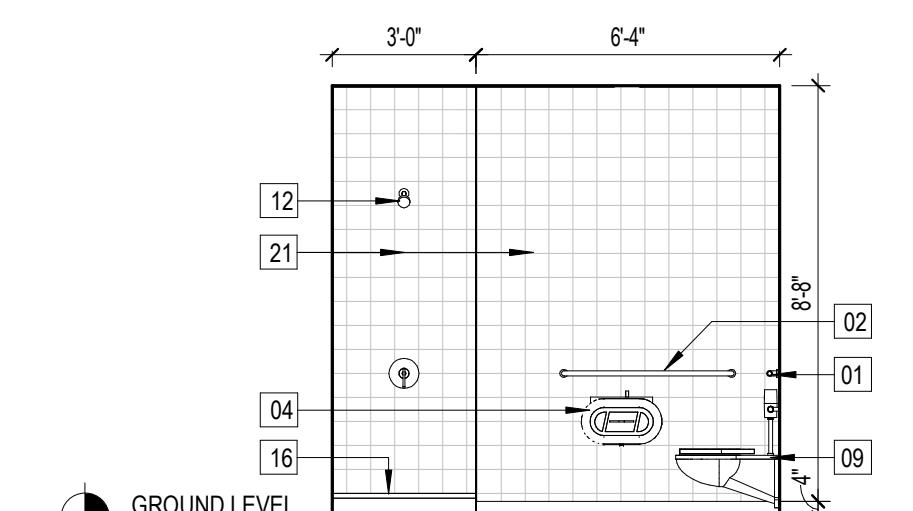

3 RESTROOM ELEVATION
Scale: 1/4" = 1'-0"

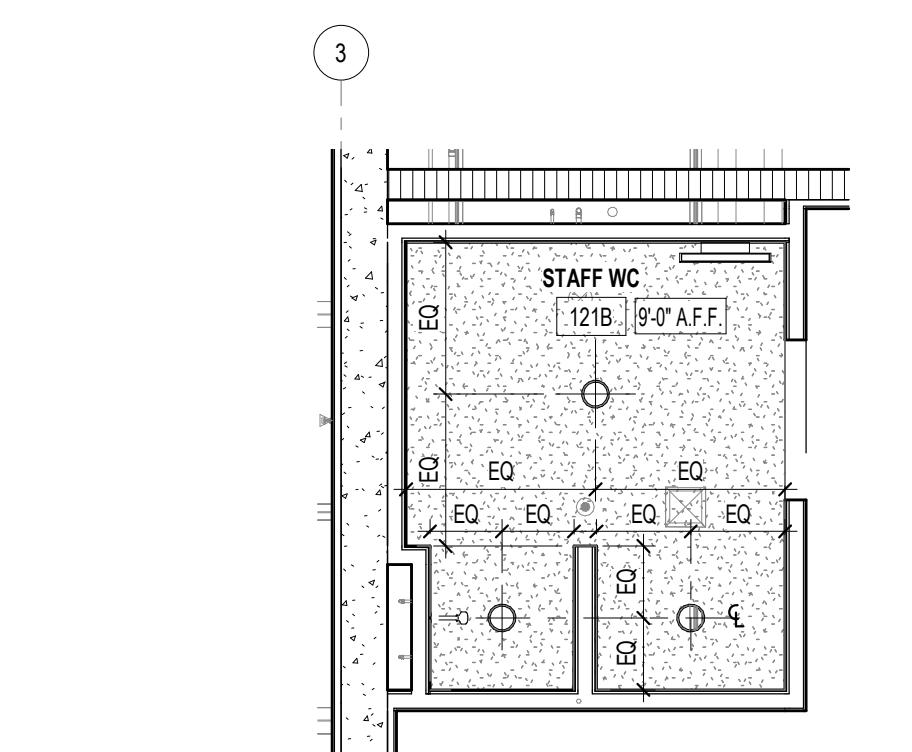

2 RCP AT RESTROOM
Scale: 1/4" = 1'-0"

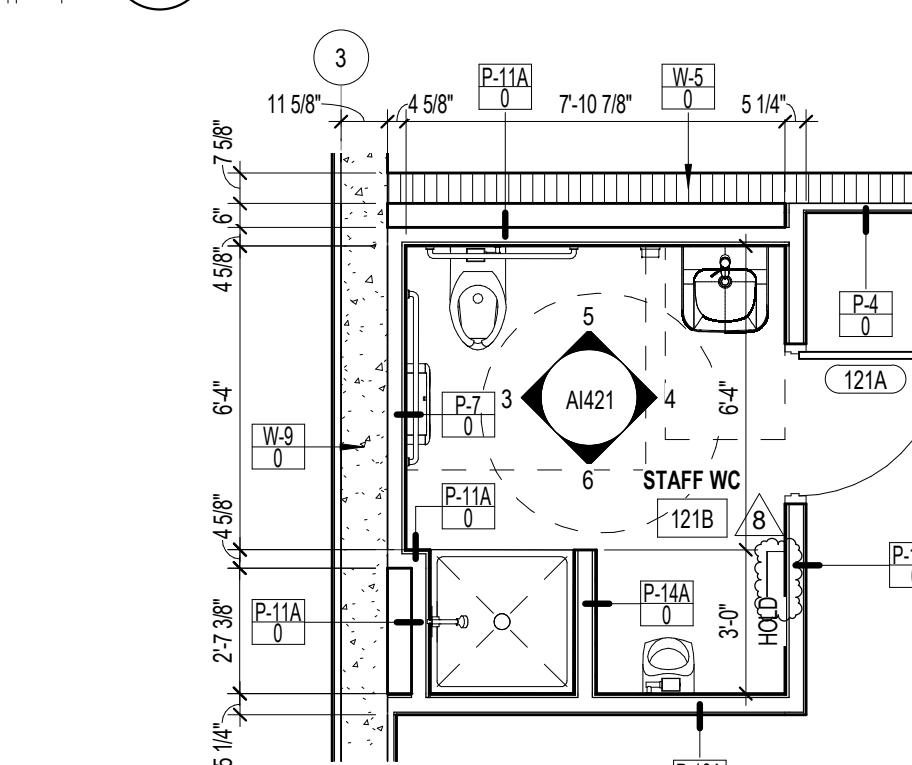


1 STAFF RESTROOM PLAN
Scale: 1/4" = 1'-0"

RESTROOM FIXTURE NOTES	
1.	OBJECTS PROTRUDING MORE THAN 4" INTO PATH OF EGRESS MUST BE MOUNTED AT NO MORE THAN 27" AFF OR BE PROTECTED BY A BARRIER PER FBC 2020, 7TH EDITION (ACCESSIBILITY), 307.2.
2.	ALL FIXTURES WITHIN THE ADA BATHROOM SHALL BE ADA COMPLIANT AND INSTALLED PER ADA REQUIREMENTS.
3.	ATTACH GRAB BARS WITH FASTENERS (AS APPROVED BY MANUFACTURER) THAT WILL ALLOW FOR A 250 LB. VERTICAL LOADING OF THE GRAB BAR. COMPLY WITH STRUCTURAL LOADING REQUIREMENTS, INDICATED IN NOTE 1; ALL PENETRATIONS BEHIND GRAB BAR SUPPORTS SHALL BE SEALED TO MAINTAIN INTEGRITY OF WALLS/PARTITIONS/BARRIERS.

REFLECTED CEILING PLAN LEGEND	
	HARD CEILING
	2' x 2' ARMSTRONG TECHZONE ACOUSTIC CEILING TILE
	CERTAINEED SOLO BAFFLE SYSTEM
	2' x 3' CEILING ACCESS PANEL
	EXIT LIGHT FIXTURE - CEILING MOUNTED. ARROW INDICATES DIRECTION
	EXIT LIGHT FIXTURE - CEILING MOUNTED. ARROW INDICATES DIRECTION
	LED STRIP LIGHT FIXTURE SURFACE MOUNTED (SEE ELECTRICAL DRAWINGS FOR TYPE)
	RECESSED LED STRIP LIGHT FIXTURE
	2' x 2' RECESSED LIGHT FIXTURE
	EXTERIOR CIRCULAR LIGHT FIXTURE
	RETURN OR EXHAUST GRILLE
	SUPPLY GRILLE
	RECESSED LIGHT FIXTURE
	PENDANT GYMNASIUM LIGHT FIXTURE
	BOH LED FIXTURE - WALL OR PENDANT MOUNTED
	FIRE SPRINKLER (SEE FIRE PROTECTION PLANS)
	RETRACTING ELECTRONIC BASKETBALL HOOP
	SPEAKER
	X-XX" CEILING HEIGHT TAG
	EXPOSED STRUCTURE
	FIRE ALARM HORN AND STROBE
	STAGE LIGHT

RESTROOM FIXTURE LEGEND	
01.	GRAB BAR 36" LONG HEAVY DUTY STAINLESS STEEL
02.	GRAB BAR 42" LONG HEAVY DUTY STAINLESS STEEL
03.	SURFACE MOUNTED SOAP DISPENSER
04.	TOILET TISSUE DISPENSER SURFACE MOUNTED
05.	SURFACE MOUNTED SANITARY NAPKIN DISPOSAL
06.	PAPER TOWEL DISPENSER WITH WASTE BASKET COMBINATION
07.	HANDICAP LAVATORY, WALL HUNG WITH PROTECTIVE SHROUD
08.	STAINLESS STEEL FRAMED MIRROR 24"X36"
09.	HANDICAP ACCESSIBLE WALL MOUNTED WATER CLOSET WITH SEAT AND COVER
10.	PLASTIC SOLID PANEL
11.	FLOOR MOUNTED OVERHEAD BRACED SOLID PLASTIC TOILET
12.	SHOWER HEAD
13.	BILEVEL ADA WATER COOLER (DRINKING FOUNTAIN WITH WATER FILTER)
14.	BRADLEY VERGE LVL BASIN (SERIES 2/SERIES 3)
15.	WALL MOUNTED ADA URINAL
16.	SHOWER PAN
17.	CUSTODIAL SINK
18.	HANDICAP SHOWER COMPARTMENT SEAT
19.	HANDICAP ACCESSIBLE WALL MOUNTED BABY CHANGING STATION
20.	CURTAIN ROD
21.	PORCELAIN TILE
22.	COVE BASE SEE FINISH SCHEDULE
23.	VANITY LIGHT
24.	TOILET PLATE
25.	GRAB BAR 12" LONG HEAVY DUTY STAINLESS STEEL
26.	12" x 36" DOUBLE-TIER METAL LOCKER
27.	12" x 12" SIX-TIER METAL LOCKER
28.	PAINTED GWB SEE FINISH SCHEDULE
29.	ADJUSTABLE MOTOR SENSORED HANDS DRYER

PROJECT:	CITY OF DELRAY BEACH POMPEY PARK REC CENTER
REVISIONS:	8 09-22-2025 CONFORMED SET
SEAL:	AA C001388

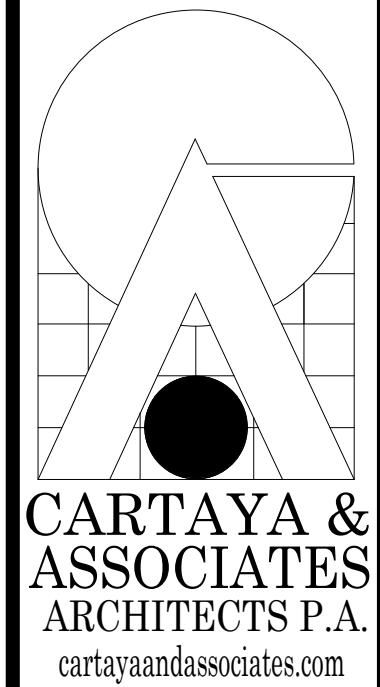


2400 E. COMMERCIAL BLVD. SUITE 201
FT. LAUDERDALE, FLORIDA 33308
954-771-2724

AA C001388

ALL DESIGN AND DATA IS PROVIDED BY THIS DRAWING AND IS THE PROPERTY OF THE CONTRACTOR. THIS IS THE CONTRACTOR'S DRAWING AND IS FOR THE CONTRACTOR'S USE ONLY. THE CONTRACTOR SHALL VERIFY ALL EXISTING CONDITIONS AND DIMENSIONS AND MAKE ADJUSTMENTS AS NECESSARY. THE CONTRACTOR SHALL NOT REPRODUCE THIS DRAWING WITHOUT THE WRITTEN CONSENT OF THE CONTRACTOR. THE CONTRACTOR SHALL NOT DISCLOSE THIS DRAWING TO ANYONE WITHOUT THE WRITTEN CONSENT OF THE CONTRACTOR.



CONFORMED SET 09/22/2025	TITLE: ENLARGED RESTROOM PLANS AND ELEVATIONS
DATE: Dec 27, 2022	DRAWN BY: SV, CC, FE, LS
REVISIONS:	CHECKED BY: JBL, LS, JS
JOB NO: 2122	SHEET: AI421

 

REFLECTED CEILING PLAN - POOL AREA

2

 

Scale: 1/4" = 1'-0"

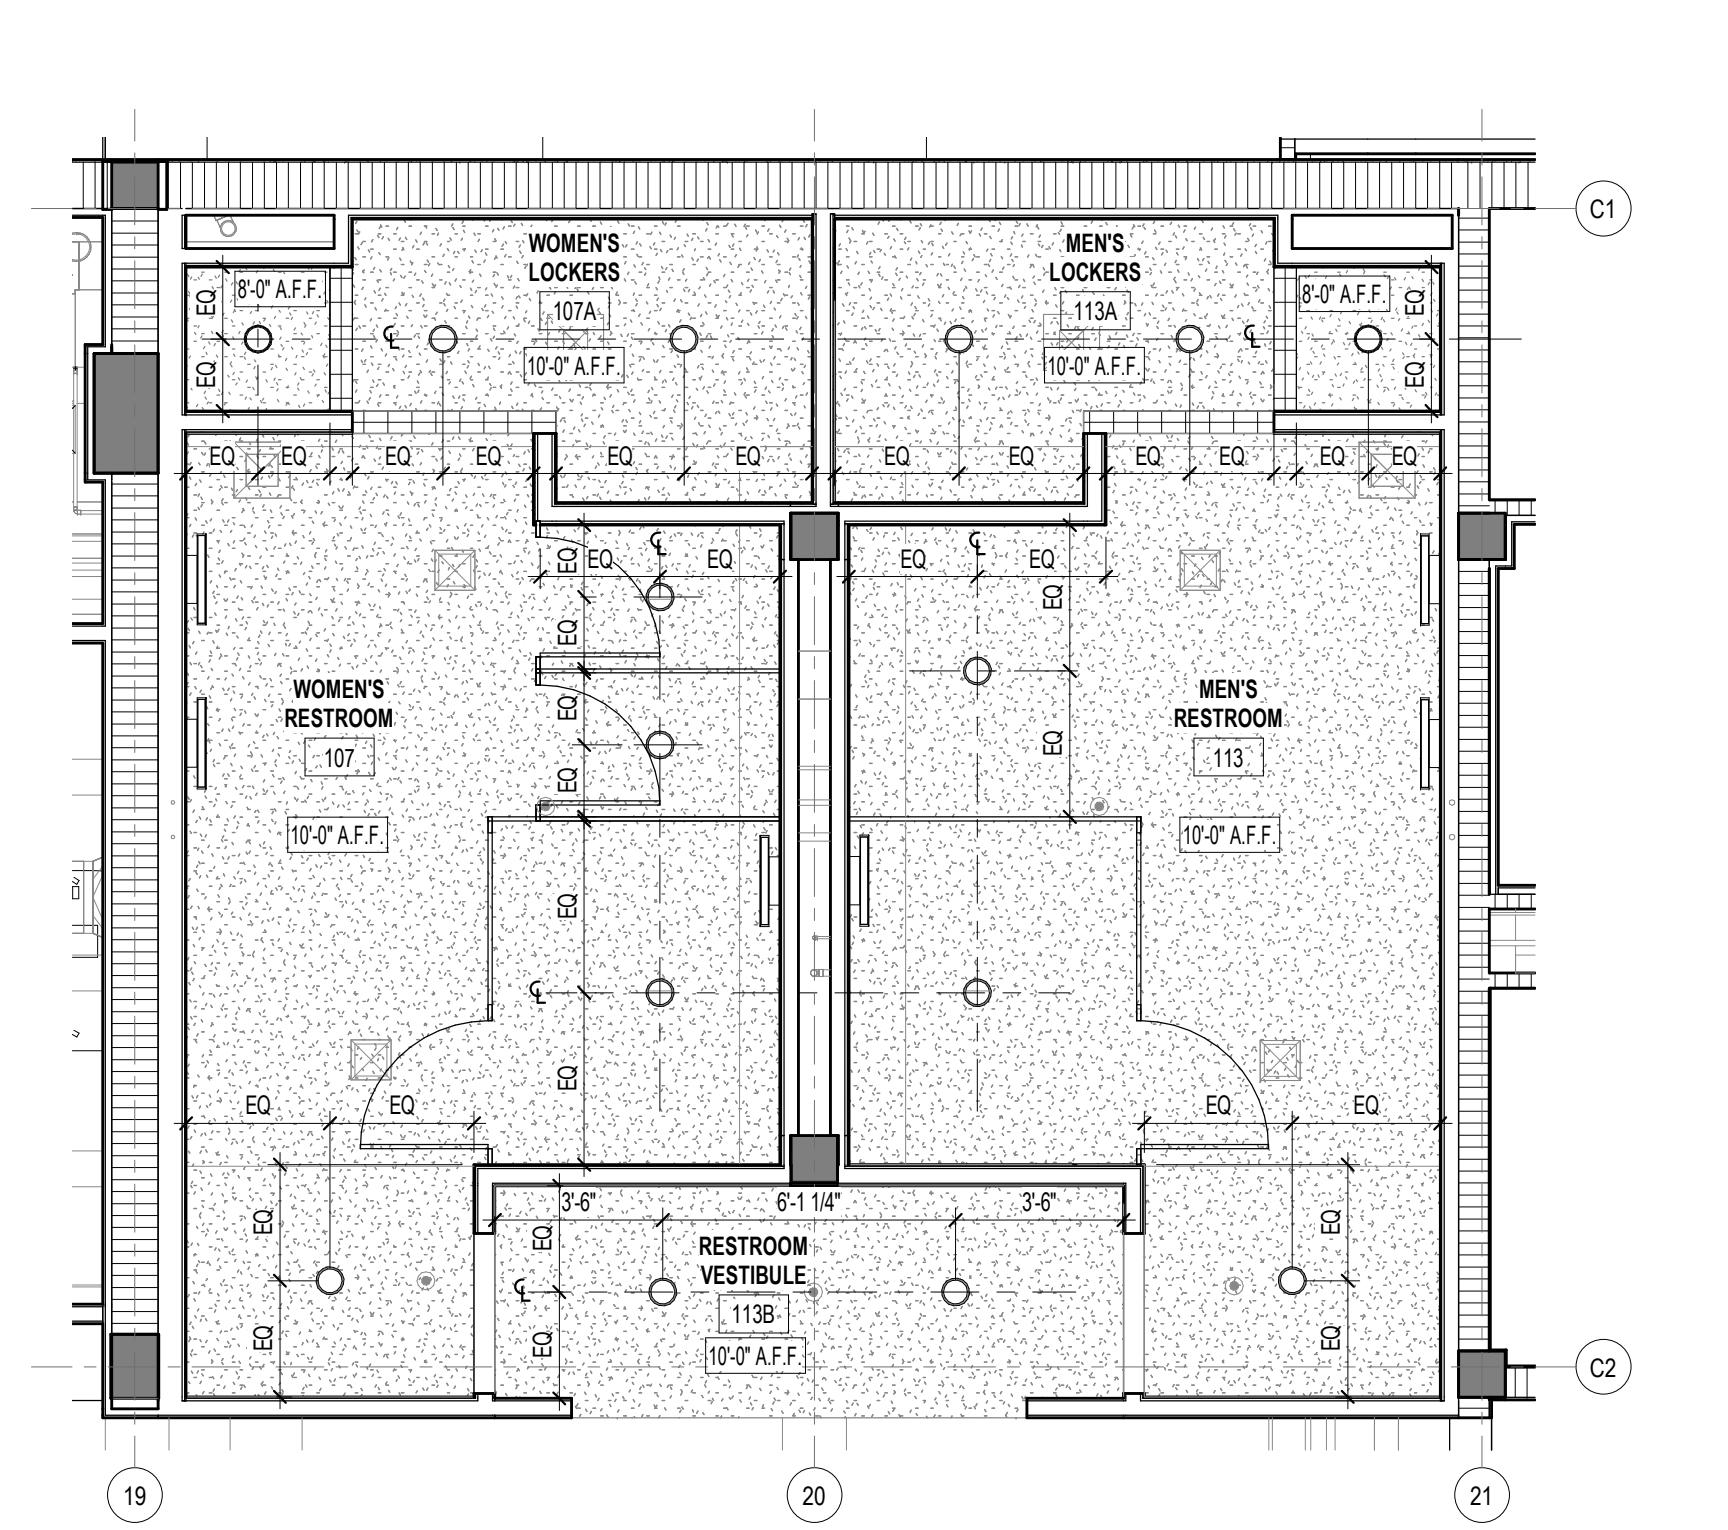

RESTROOM PLAN - POOL AREA

1

Scale: 1/4" = 1'-0"

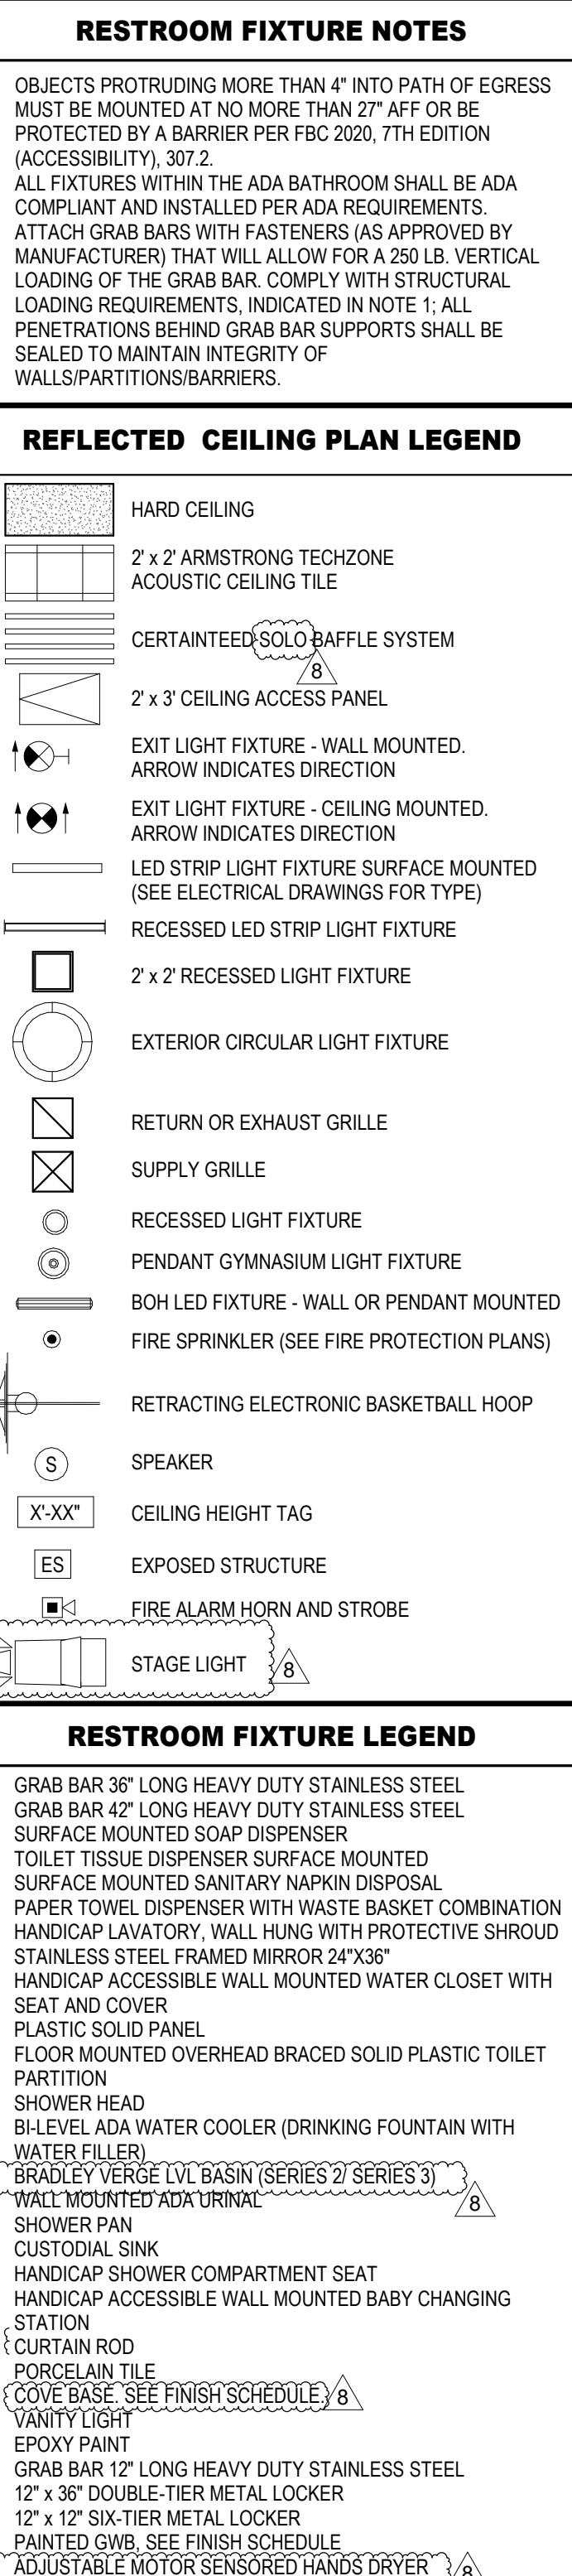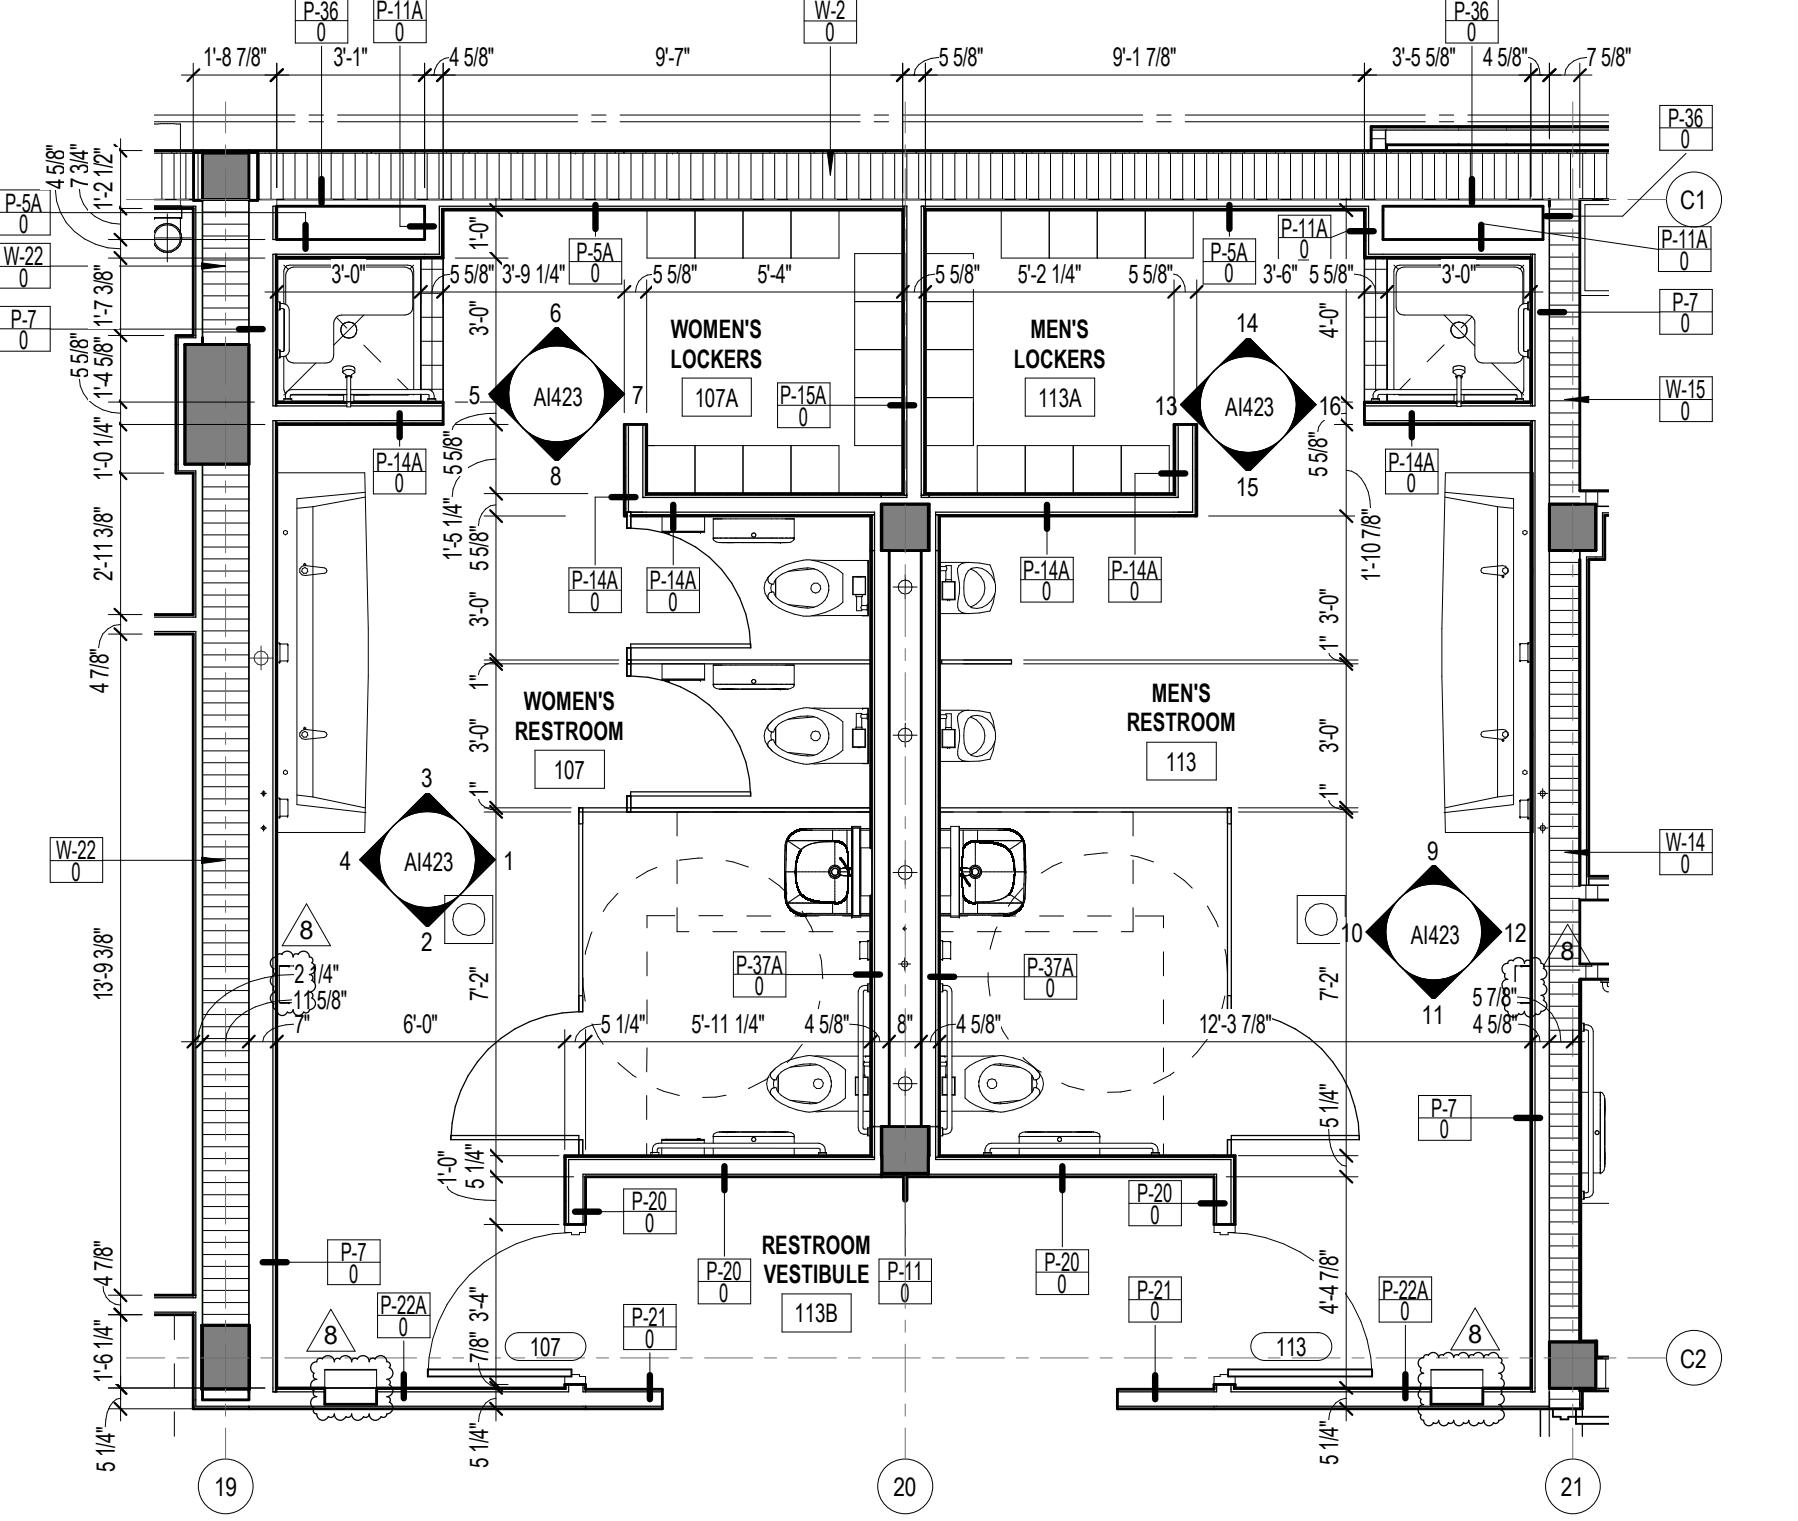

CONFORMED SET 09/22/2025

TITLE: ENLARGED RESTROOM PLANS AND ELEVATIONS

DRAWN BY: SV, CC, FEE, LS

CHECKED BY: JJJ, LS, JS

JOB NO: 2122

SHEET:

AI422

PROJECT: CITY OF DELRAY BEACH
POMPEY PARK REC CENTER
1101 NW 2ND ST. DELRAY BEACH
FL 33444

2400 E. COMMERCIAL BLVD. SUITE 201
FT. LAUDERDALE, FLORIDA 33308
954-771-2724















SEAL:

AA C001388

REVISIONS:

8 09-22-2025 CONFORMED SET

ALL DESIGN AND DATA IS PROVIDED BY THIS DRAWING AND IS THE PROPERTY OF THE CONTRACTOR. THIS IS THE CONTRACTOR'S DRAWING AND IS FOR THE CONTRACTOR'S USE ONLY. THE CONTRACTOR SHALL VERIFY ALL EXISTING CONDITIONS AND DIMENSIONS AND MAKE NO CHANGES WITHOUT THE WRITTEN CONSENT OF THE OWNER. THE CONTRACTOR AGREES TO FOLLOW THE SPECIFICATIONS, DRAWINGS, AND CONDITIONS OF CONTRACT.

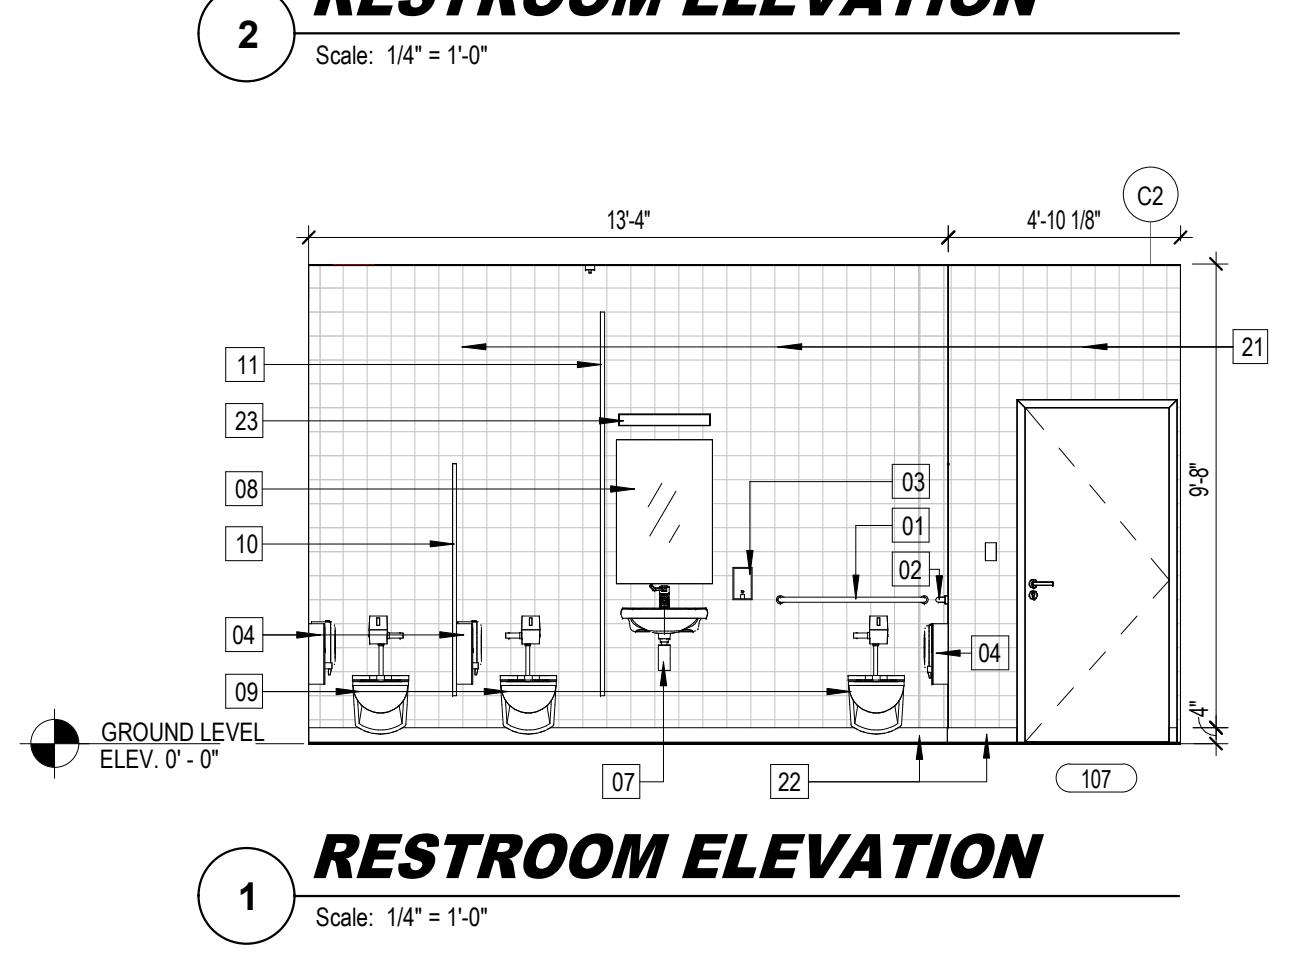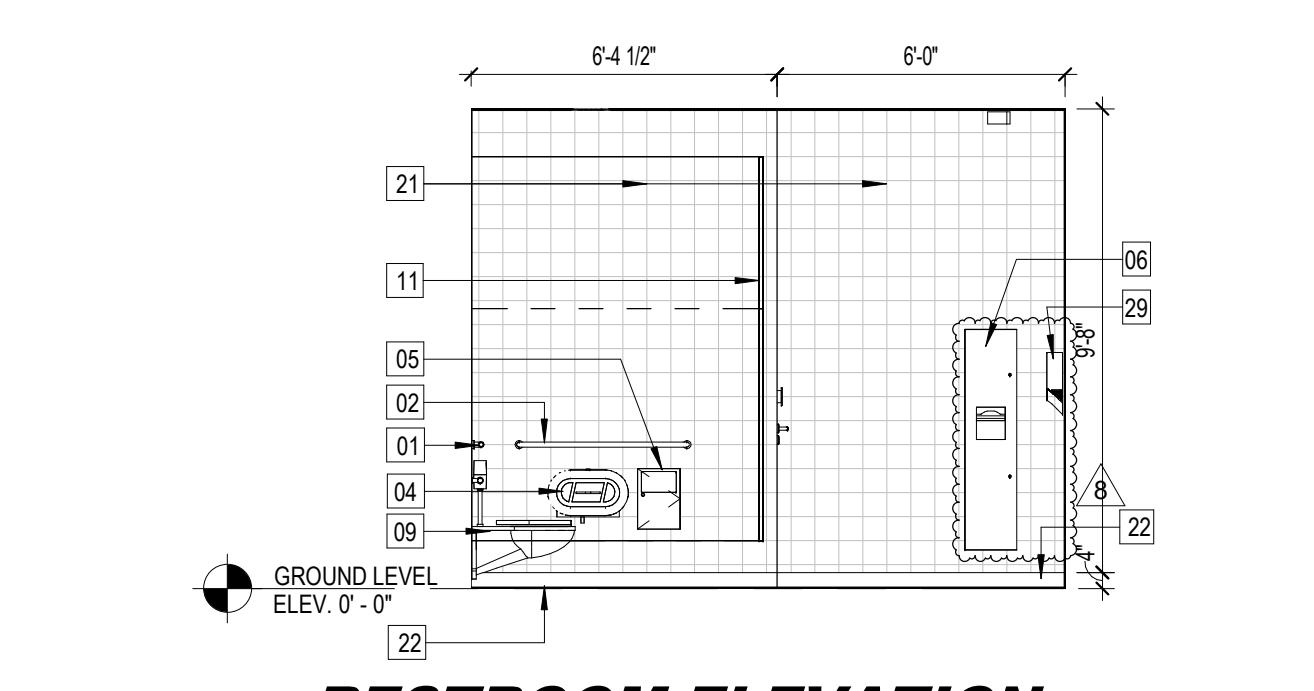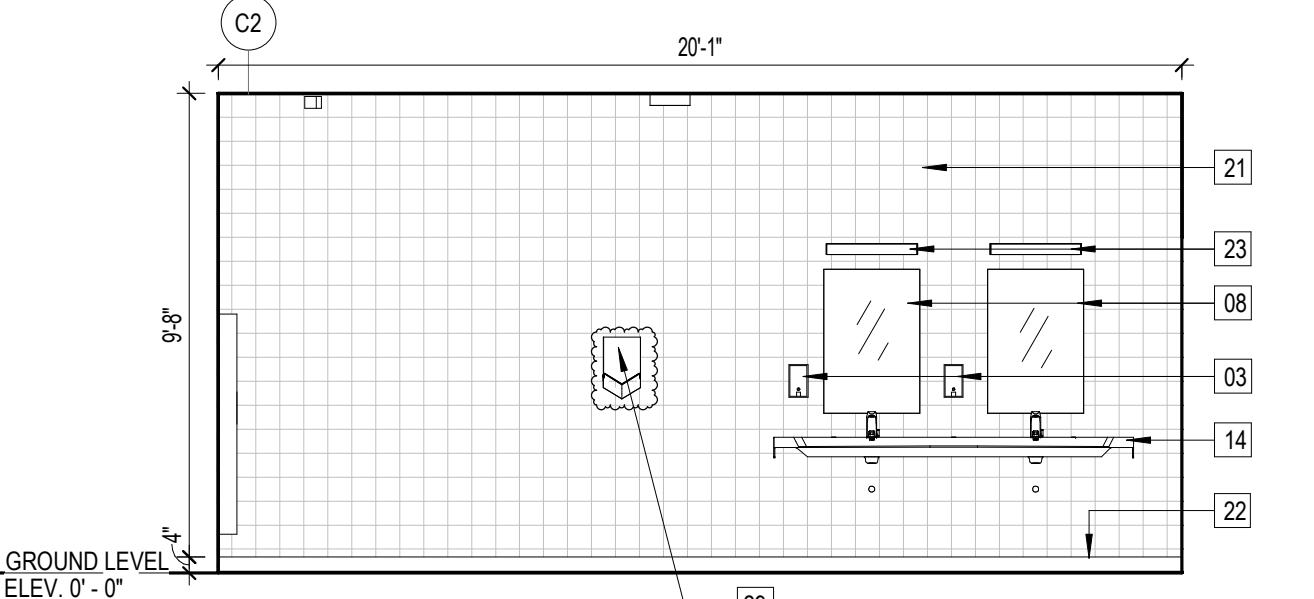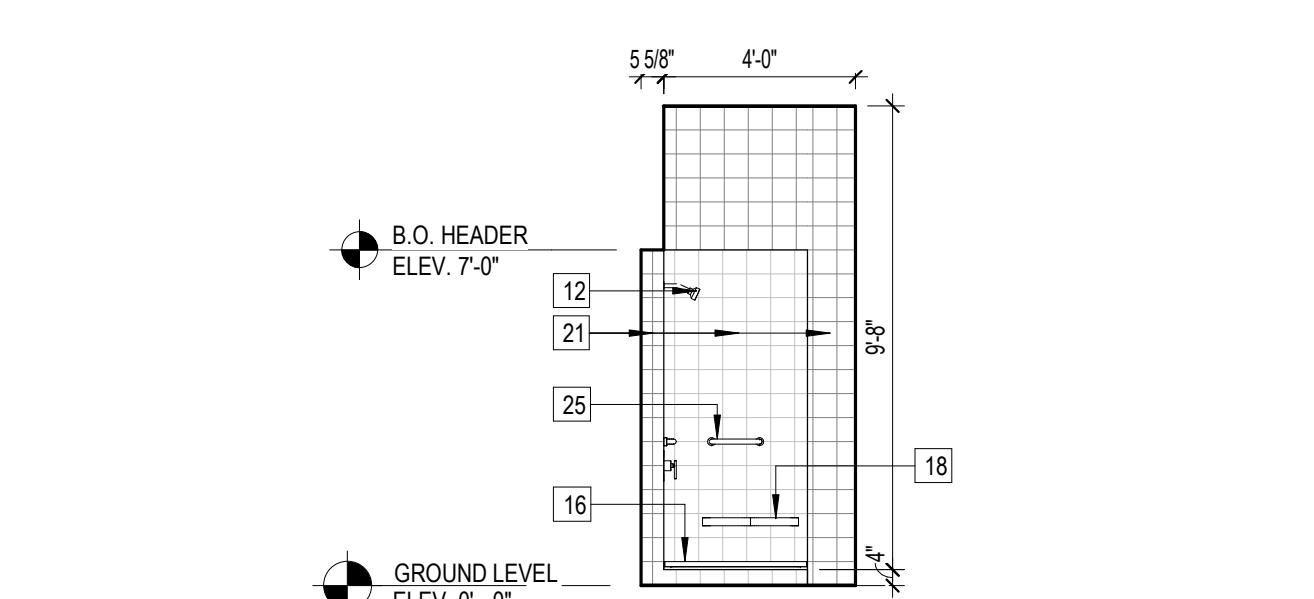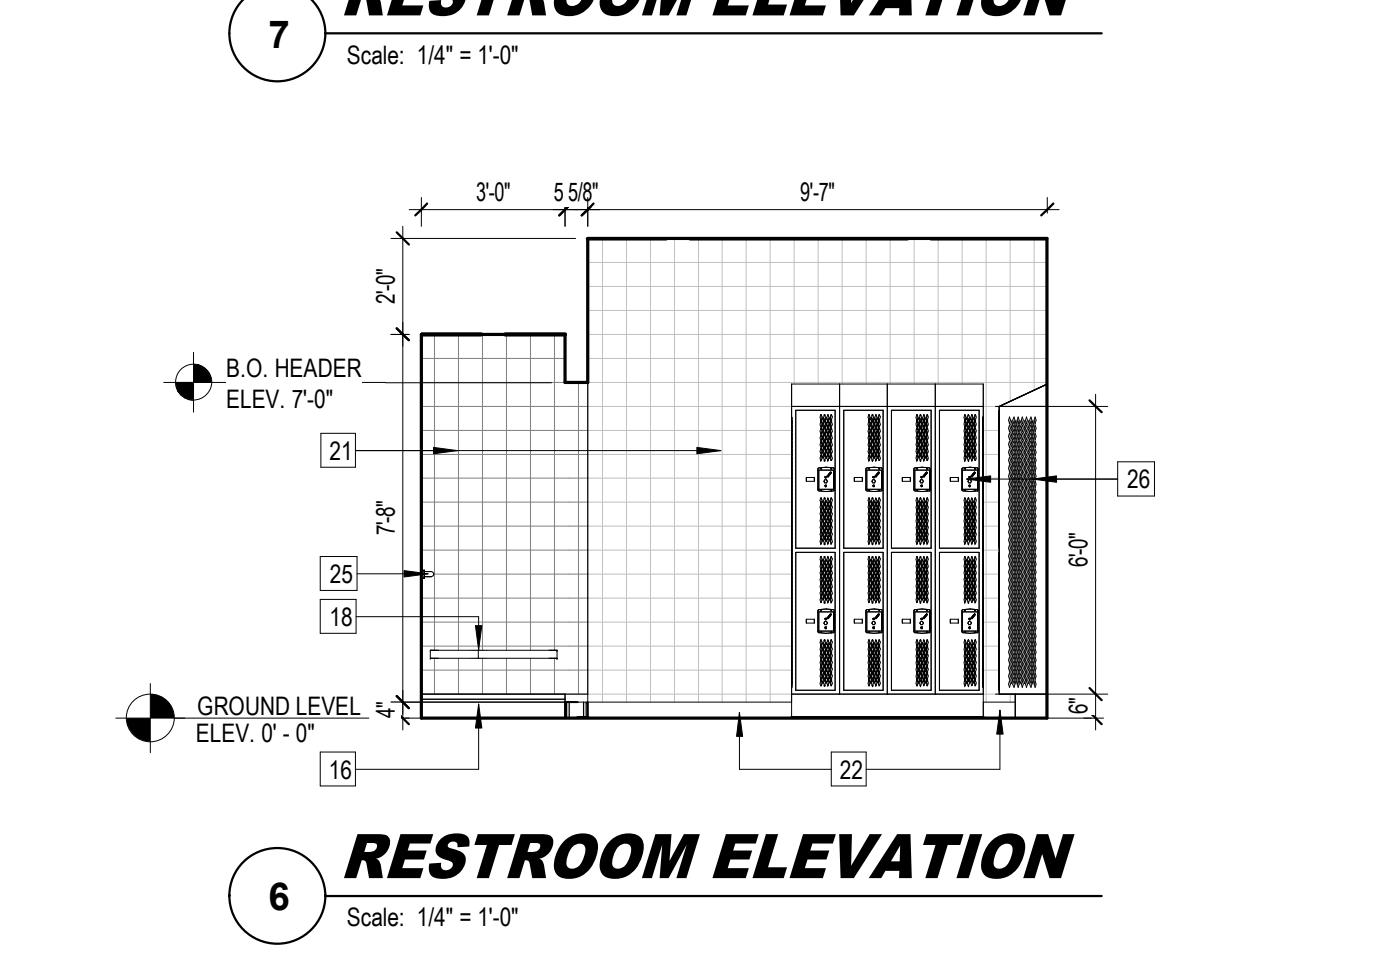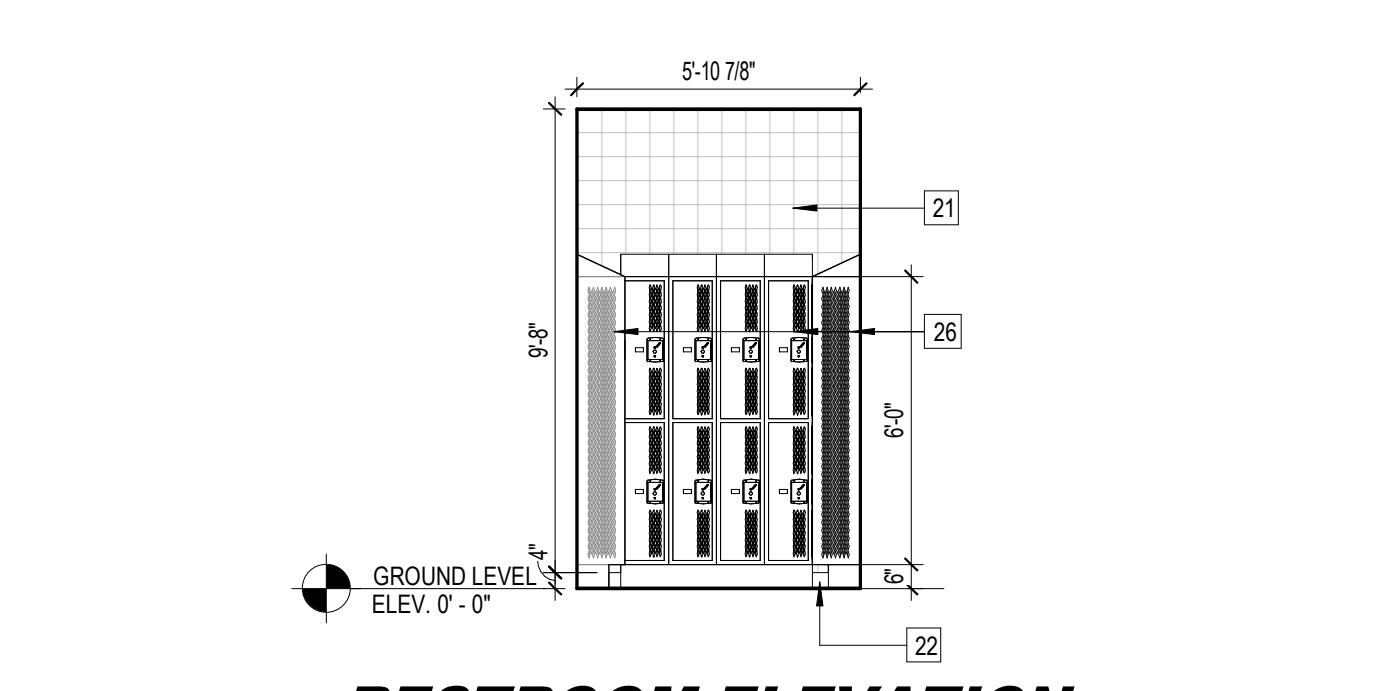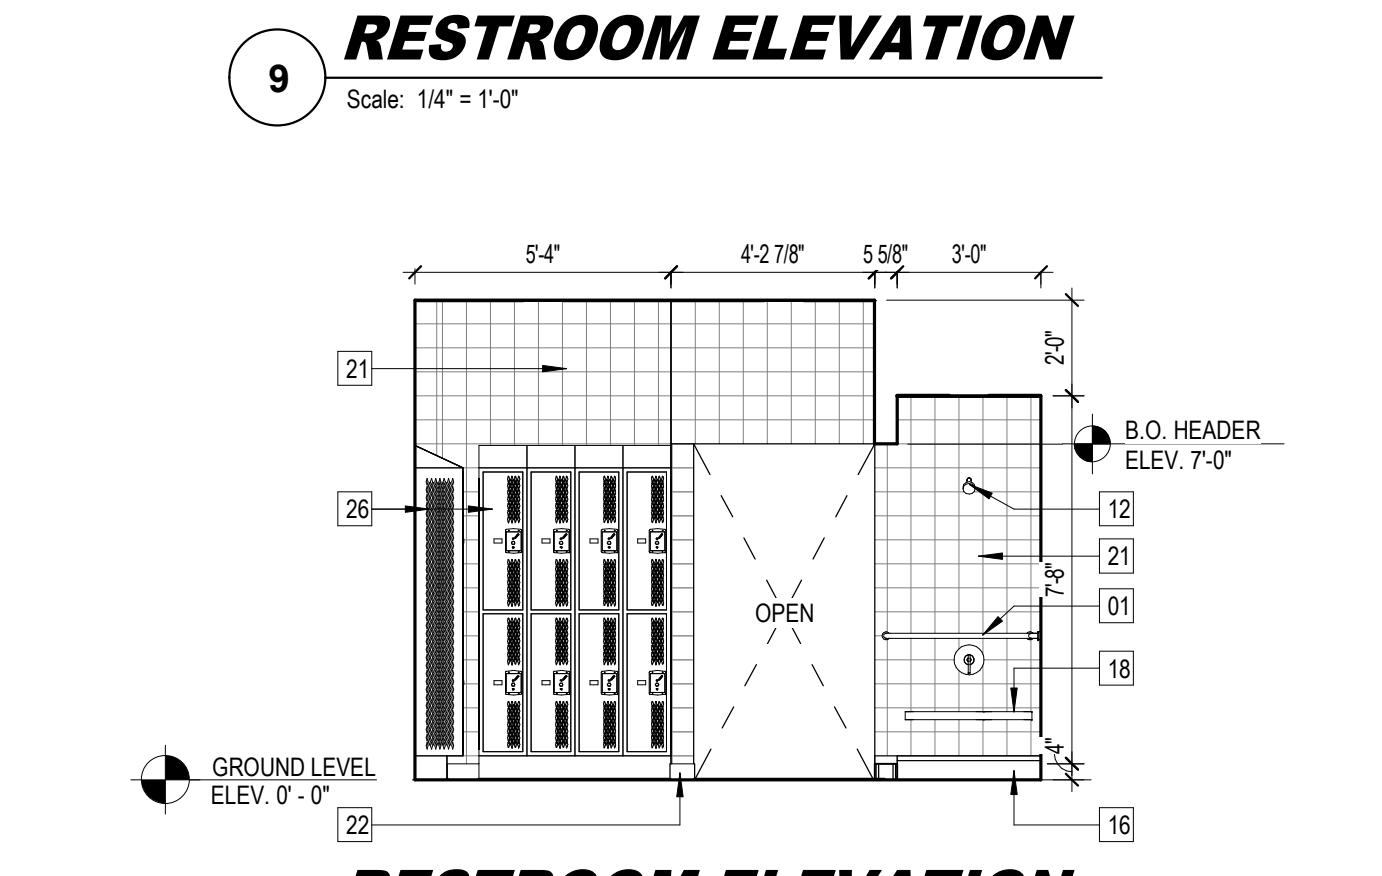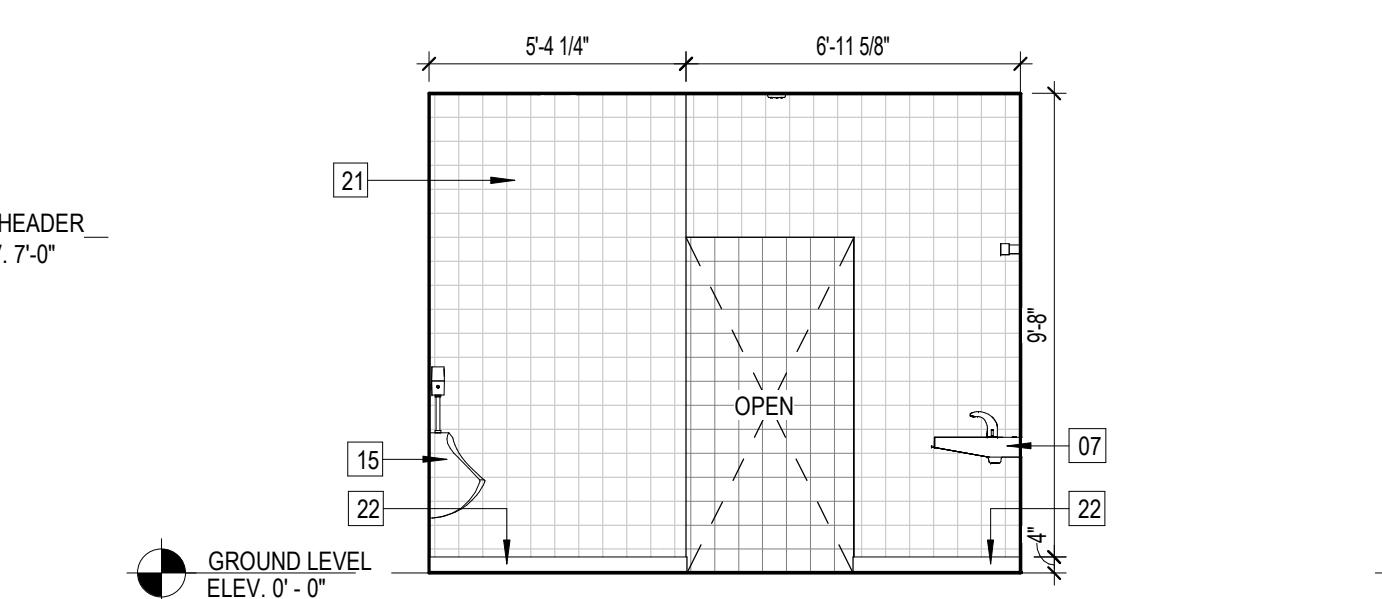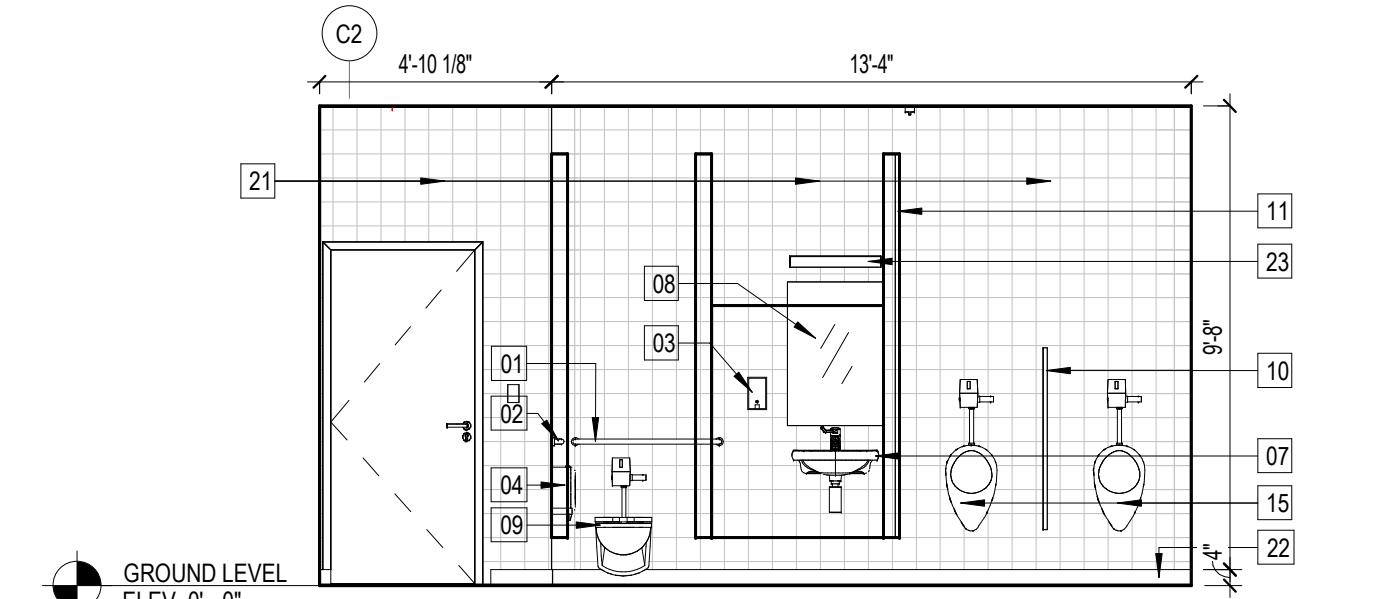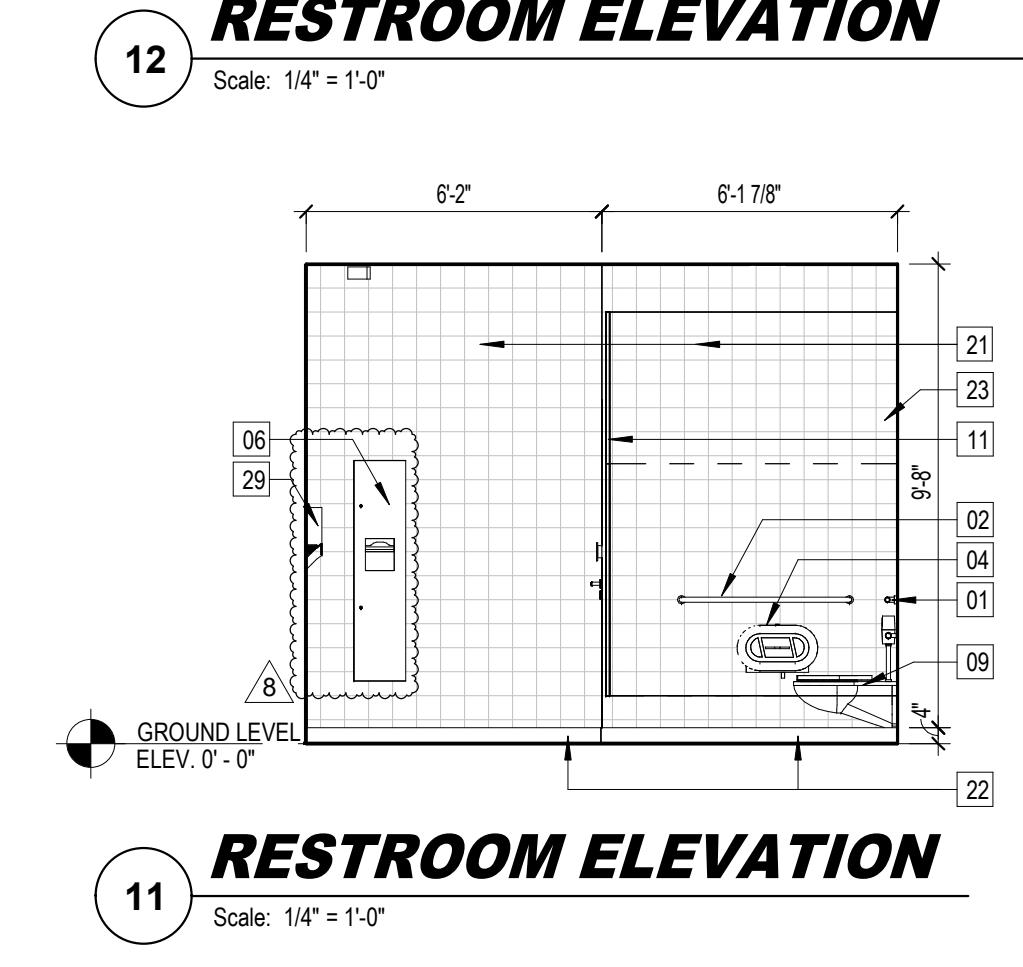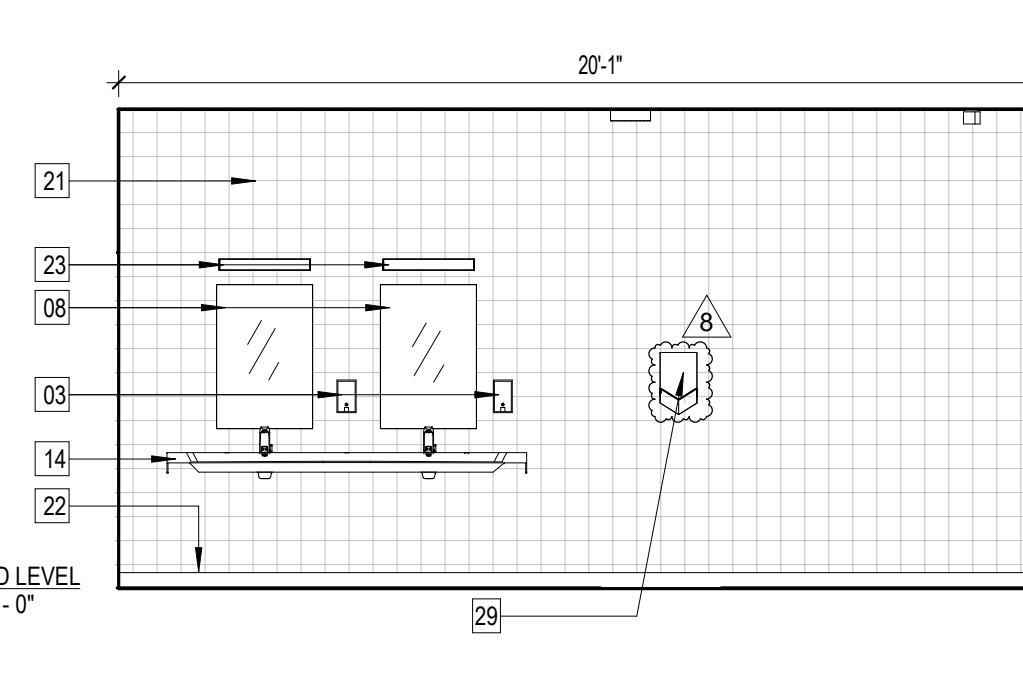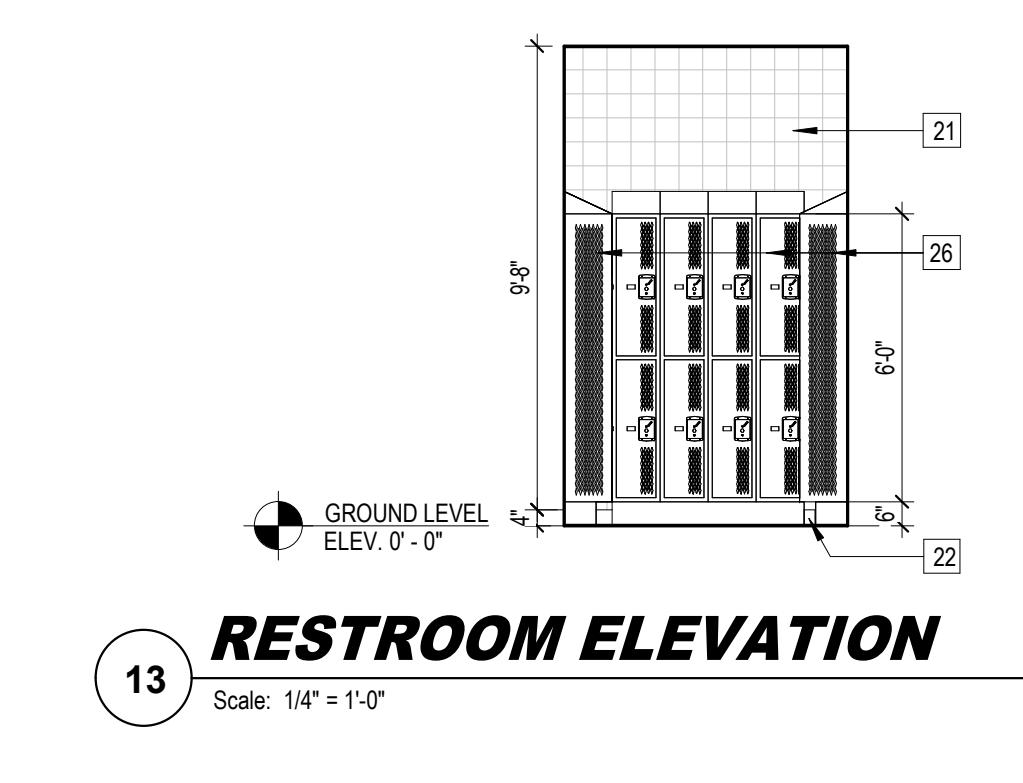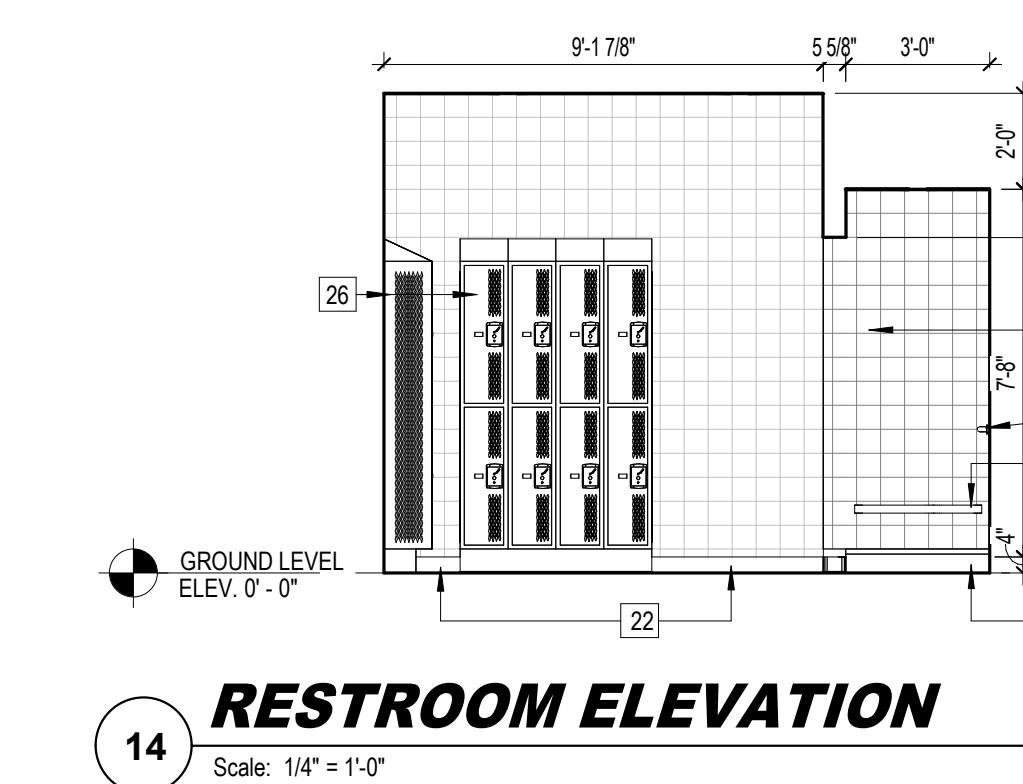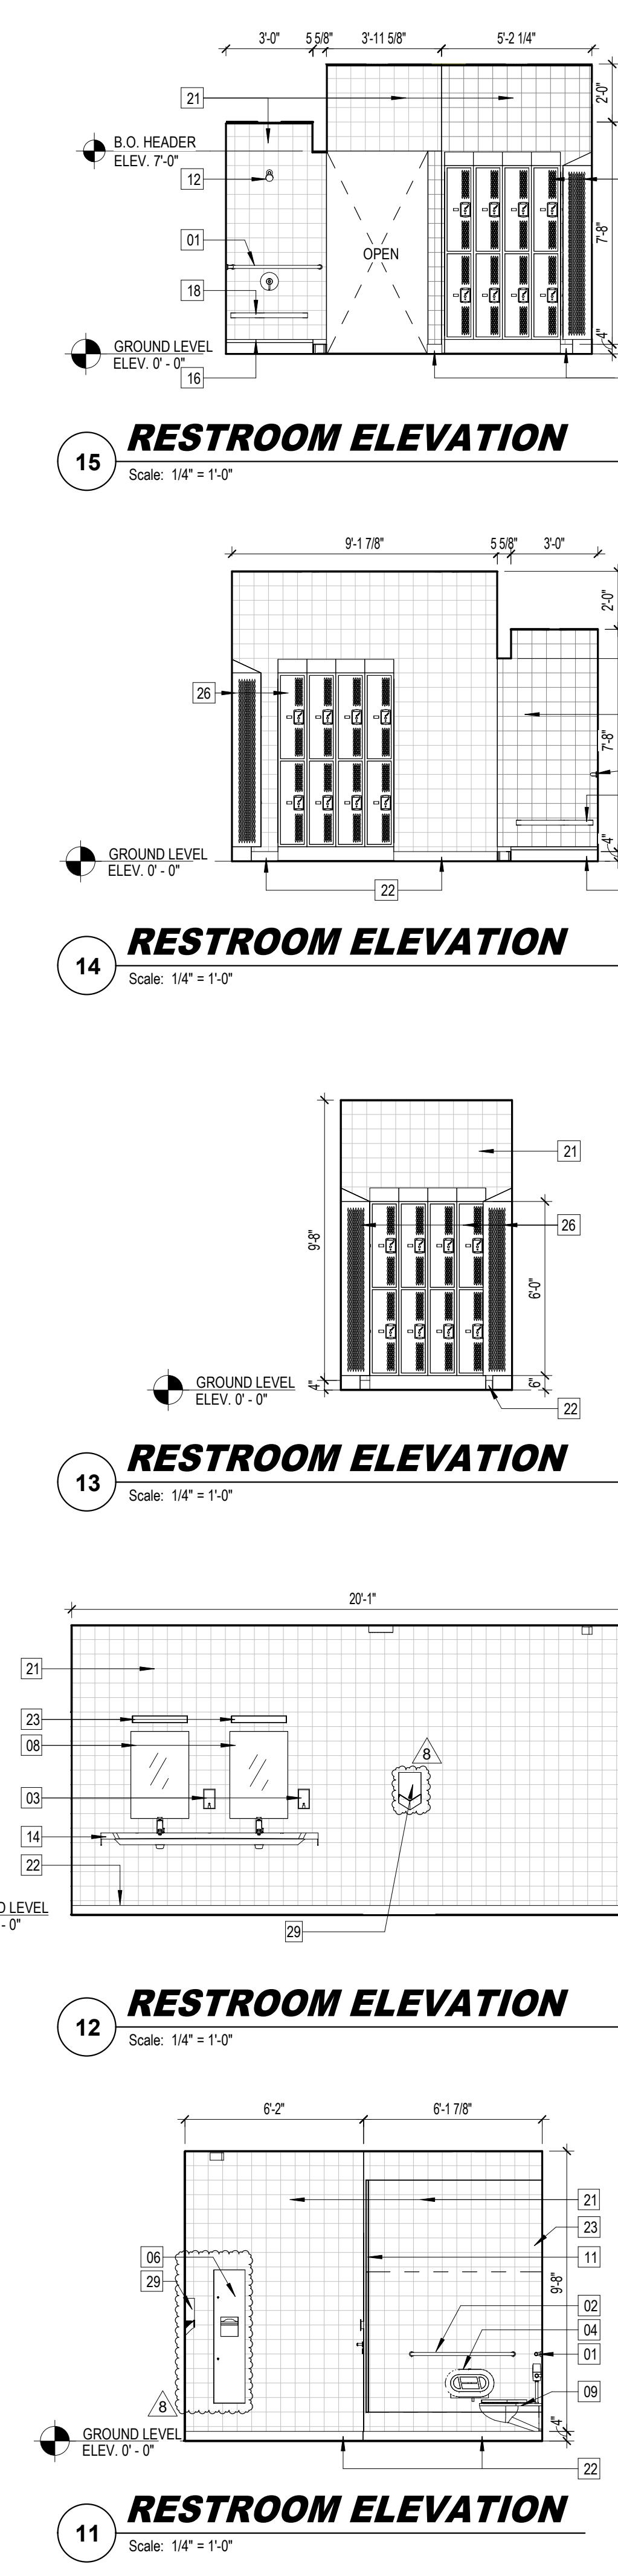

RESTROOM FIXTURE NOTES

1. OBJECTS PROTRUDING MORE THAN 4" INTO PATH OF EGRESS MUST BE MOUNTED AT NO MORE THAN 27" AFF OR BE PROTECTED BY A BARRIER PER FBC 2020, 7TH EDITION (ACCESSIBILITY) 307.2
2. ALL FIXTURES WITHIN THE ADA BATHROOM SHALL BE ADA COMPLIANT AND INSTALLED PER ADA REQUIREMENTS.
3. ATTACH GRAB BARS WITH FASTENERS (AS APPROVED BY MANUFACTURER) THAT WILL ALLOW FOR A 250 LB. VERTICAL LOADING OF THE GRAB BAR. COMPLY WITH STRUCTURAL LOADING REQUIREMENTS, INDICATED IN NOTE 1. ALL PENETRATIONS BEHIND GRAB BAR SUPPORTS SHALL BE SEALED TO MAINTAIN INTEGRITY OF WALLS/PARTITIONS/BARRIERS.

REFLECTED CEILING PLAN LEGEND

	HARD CEILING
	2' x 2' ARMSTRONG TECHZONE ACOUSTIC CEILING TILE
	CERTAINTEED SOLO BAFFLE SYSTEM
	2' x 3' CEILING ACCESS PANEL
	EXIT LIGHT FIXTURE - WALL MOUNTED. ARROW INDICATES DIRECTION
	EXIT LIGHT FIXTURE - CEILING MOUNTED. ARROW INDICATES DIRECTION
	LED STRIP LIGHT FIXTURE SURFACE MOUNTED (SEE ELECTRICAL DRAWINGS FOR TYPE)
	RECESSED LED STRIP LIGHT FIXTURE
	2' x 2' RECESSED LIGHT FIXTURE
	EXTERIOR CIRCULAR LIGHT FIXTURE
	RETURN OR EXHAUST GRILLE
	SUPPLY GRILLE
	RECESSED LIGHT FIXTURE
	PENDANT GYMNASIUM LIGHT FIXTURE
	BOH LED FIXTURE - WALL OR PENDANT MOUNTED
	FIRE SPRINKLER (SEE FIRE PROTECTION PLANS)
	RETRACTING ELECTRONIC BASKETBALL HOOP
	SPEAKER
	X-XX CEILING HEIGHT TAG
	EXPOSED STRUCTURE
	FIRE ALARM HORN AND STROBE
	STAGE LIGHT

RESTROOM FIXTURE LEGEND

ALL DESIGN AND DATA IS PROVIDED BY THIS DRAWING AND IS FOR INFORMATION AND COMMENT ONLY. THIS IS THE PROPERTY OF THE CITY OF DELRAY BEACH. IT IS THE CONTRACTOR'S RESPONSIBILITY TO CONFIRM ALL EXISTING CONDITIONS AND DIMENSIONS AND TO MAKE ADJUSTMENTS AS NECESSARY. THE CONTRACTOR SHALL VERIFY ALL EXISTING CONDITIONS AND DIMENSIONS AND MAKE ADJUSTMENTS AS NECESSARY. THE CONTRACTOR SHALL NOT RELY ON THIS DRAWING FOR DESIGN OR CONSTRUCTION.

01. GRAB BAR 30" LONG HEAVY DUTY STAINLESS STEEL

02. GRAB BAR 42" LONG HEAVY DUTY STAINLESS STEEL

03. SURFACE MOUNTED SOAP DISPENSER

04. TOILET TISSUE DISPENSER SURFACE MOUNTED

05. SURFACE MOUNTED SANITARY NAPKIN DISPOSAL

06. PAPER TOWEL DISPENSER WITH WASTE BASKET COMBINATION

07. HANDICAP LAVATORY, WALL HUNG WITH PROTECTIVE SHROUD

08. STAINLESS STEEL FRAMED MIRROR 24"X36"

09. HANDICAP ACCESSIBLE WALL MOUNTED WATER CLOSET WITH SEAT AND COVER

10. PLASTIC MOUNTED OVERHEAD BRACED SOLID PLASTIC TOILET PARTITION

11. SHOWER HEAD

12. WATER COOLER (DRINKING FOUNTAIN WITH WATER FILTER)

13. BRADLEY VERSA VLN BASIN (SERIES 2) SERIES 3

14. 18"X42" MOUNTED ADA URINAL

15. SHOWER PAN

16. CUSTODIAL SINK

17. HANDICAP SHOWER COMPARTMENT SEAT

18. HANDICAP ACCESSIBLE WALL MOUNTED BABY CHANGING STATION

19. CURTAIN ROD

20. PORCELAIN TILE

21. COVE BASE SEE FINISH SCHEDULE

22. VANITY LIGHT

23. EPOXY PAINT


24. GRAB BAR 12" LONG HEAVY DUTY STAINLESS STEEL

25. 36" X 36" DOUBLE-TIER METAL LOCKER

26. 12" X 12" SIX-TIER METAL LOCKER

27. PAINTED GVB, SEE FINISH SCHEDULE

28. ADJUSTABLE MOTOR SENSORED HANDS DRYER

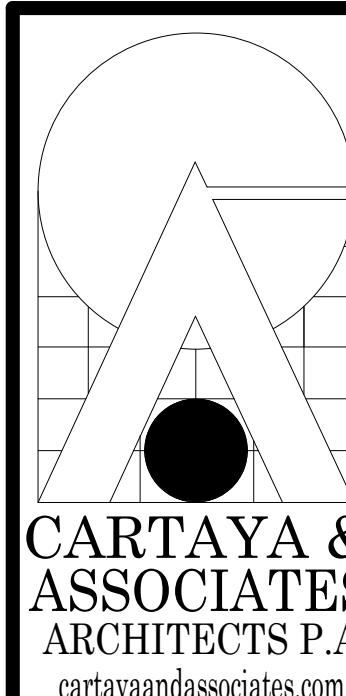

2400 E. COMMERCIAL BLVD. SUITE 201
FT. LAUDERDALE, FLORIDA 33308
954-771-2724



AA C001388
SEAL:


PROJECT: CITY OF DELRAY BEACH
POMPEY PARK REC CENTER
1101 NW 2ND ST. DELRAY BEACH
FL 33444

REVISIONS: 8 09-22-2025 CONFORMED SET


CONFORMED SET 09/22/2025
TITLE: ENLARGED RESTROOM PLANS AND ELEVATIONS
DRAWN BY: SV, CC, FE, LS
CHECKED BY: JJJ, LS, JS
JOB NO: 2122
SHEET: AI423

DATE: Dec 27, 2022
10/22/2025 3:16:39 PM

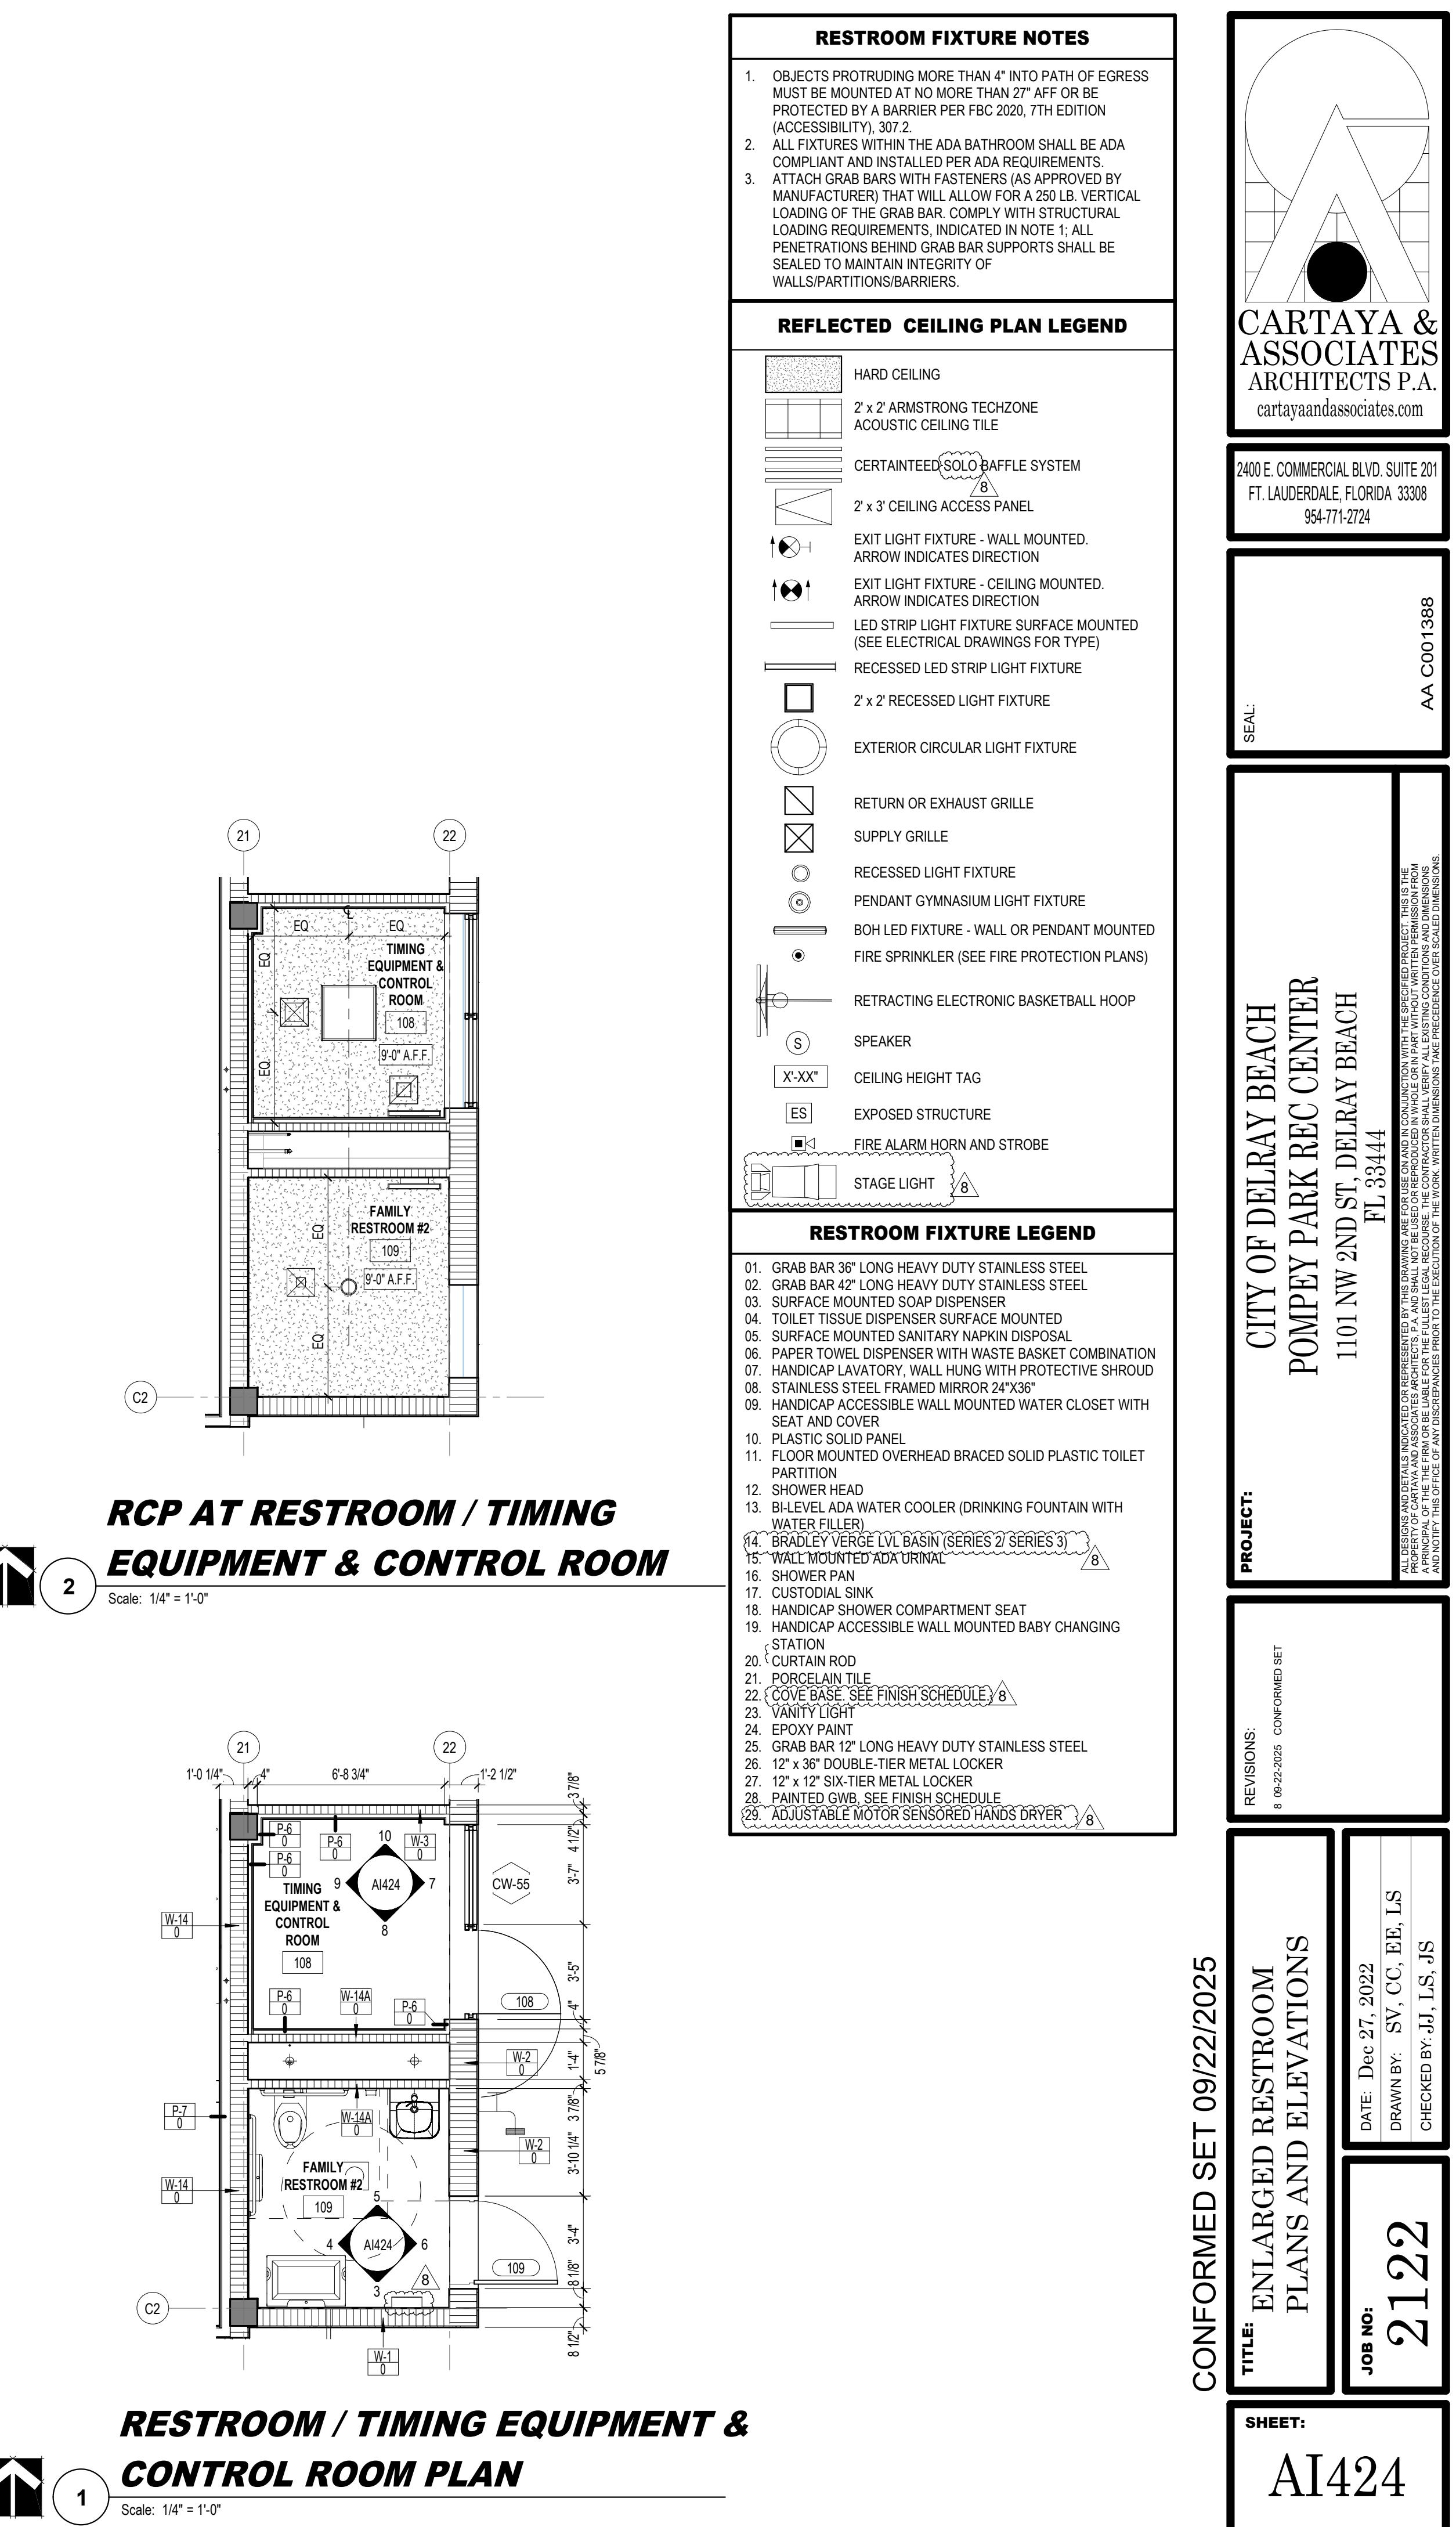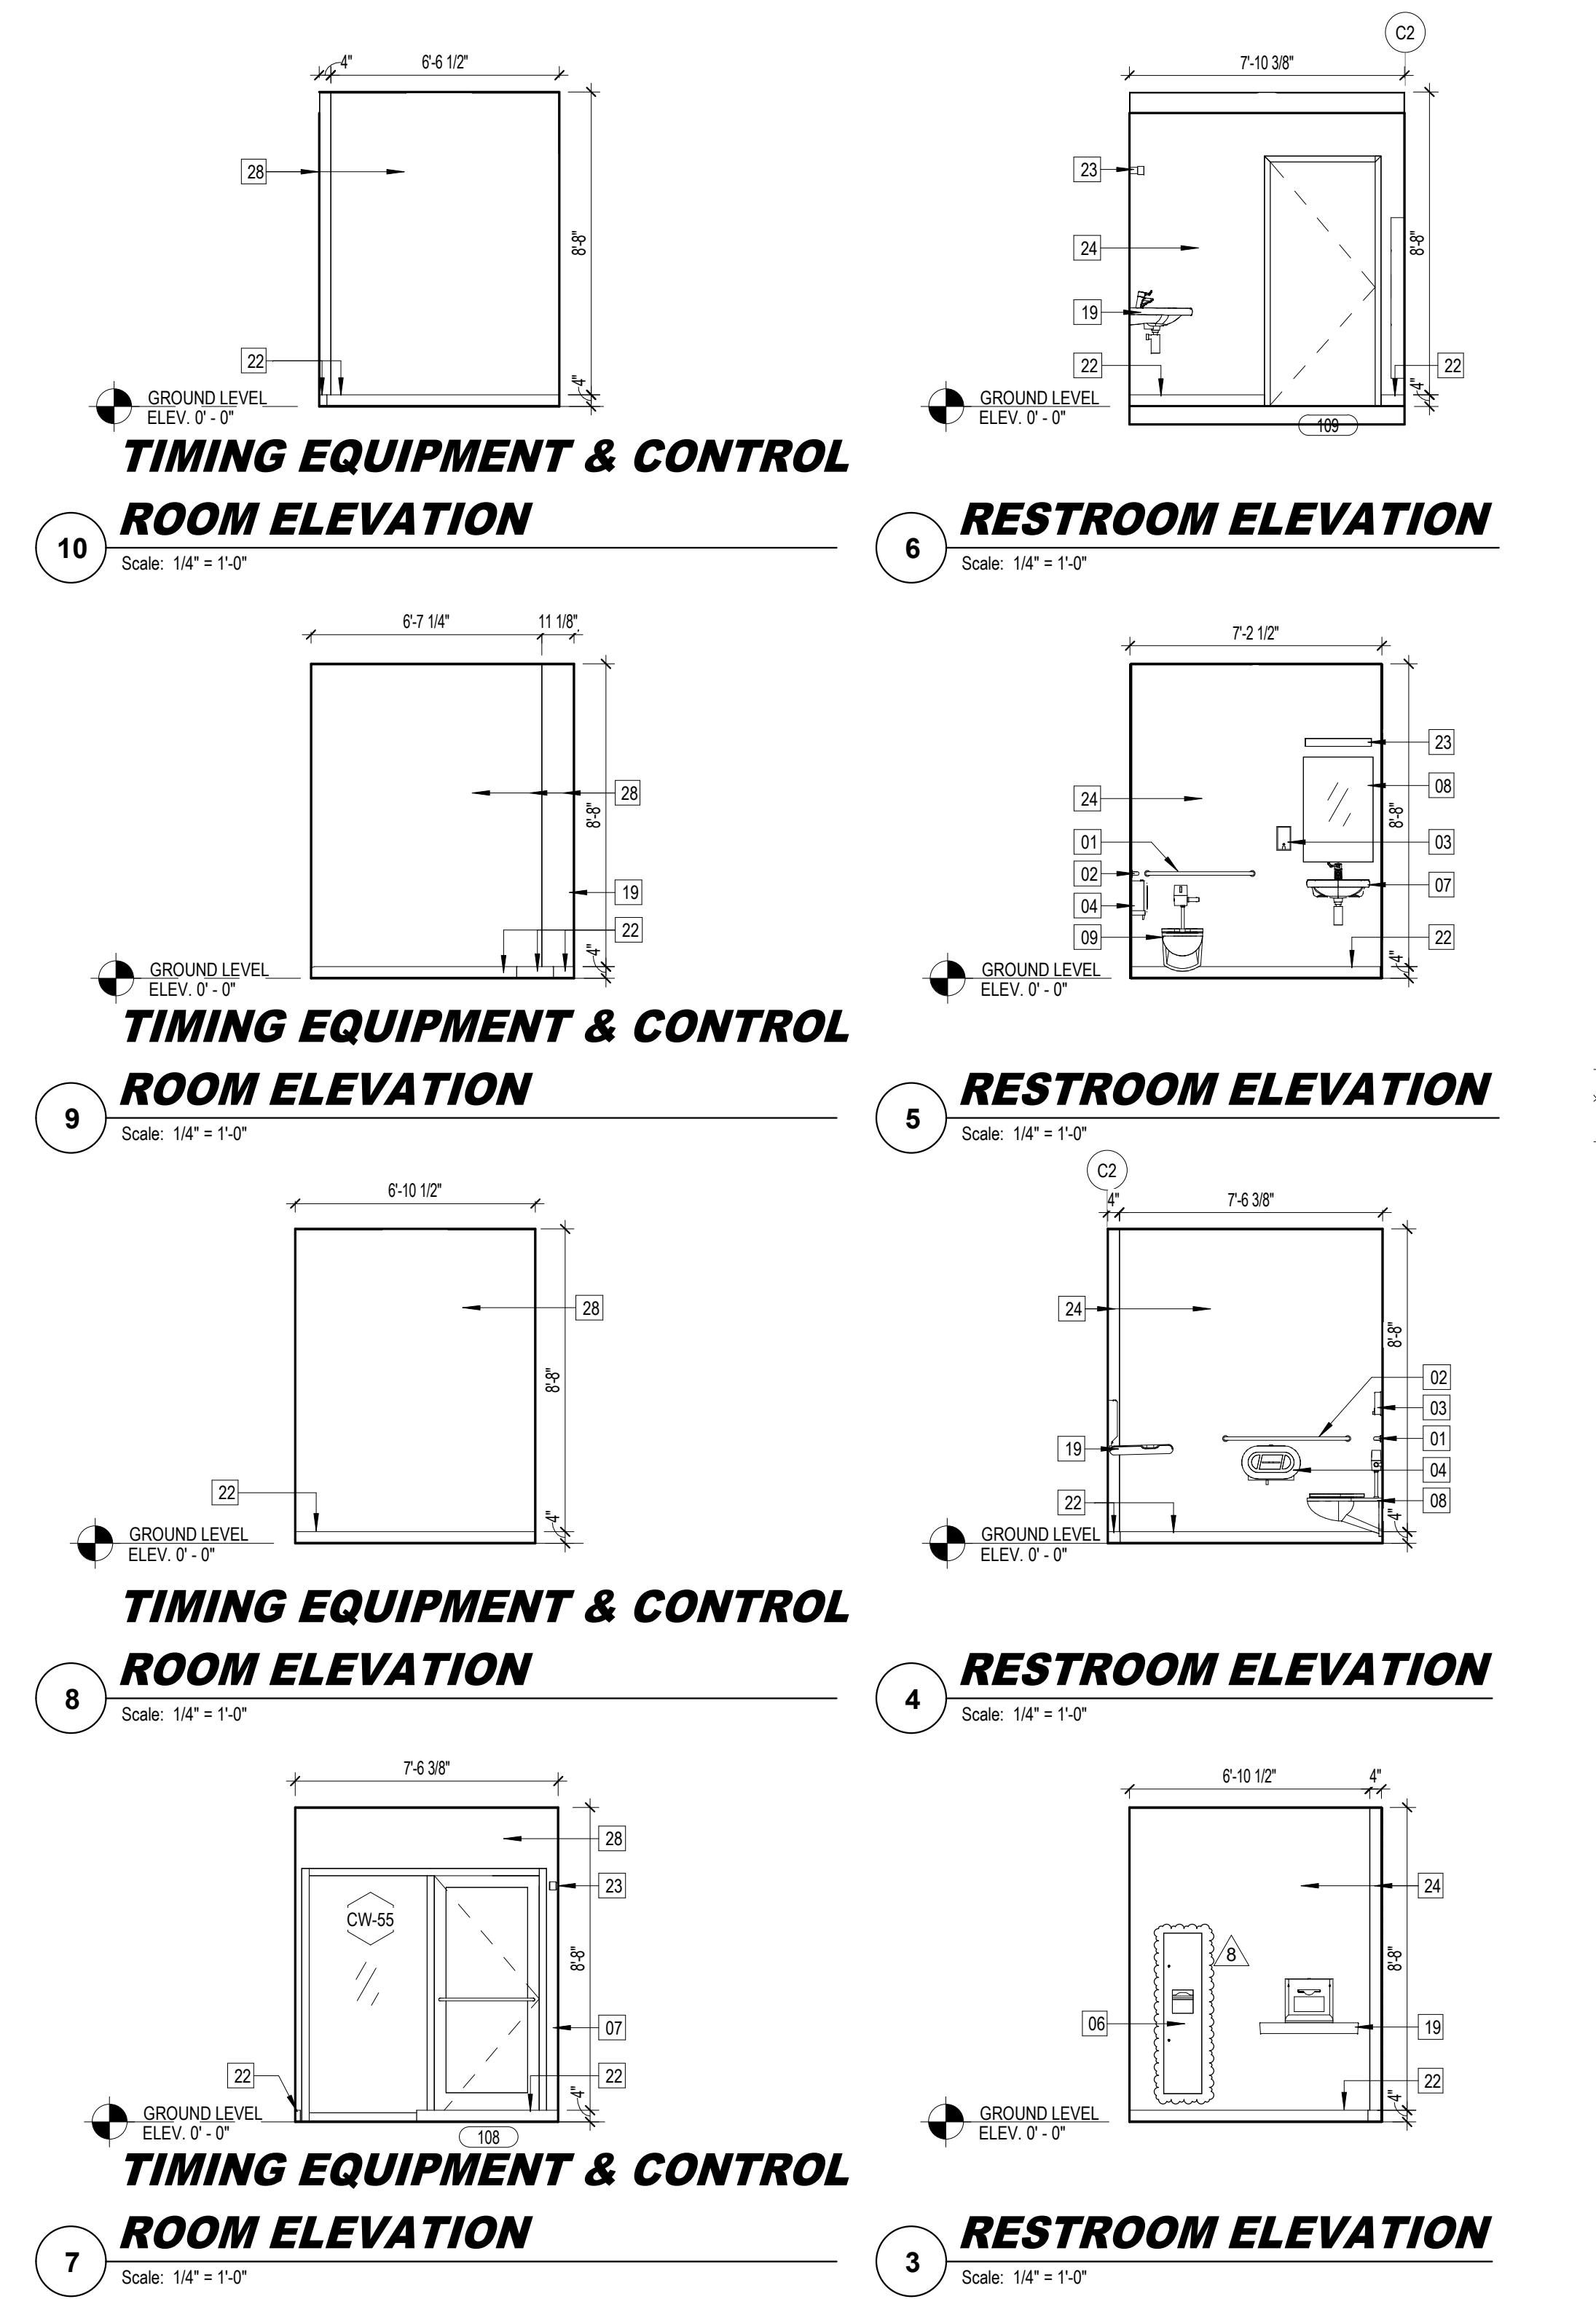


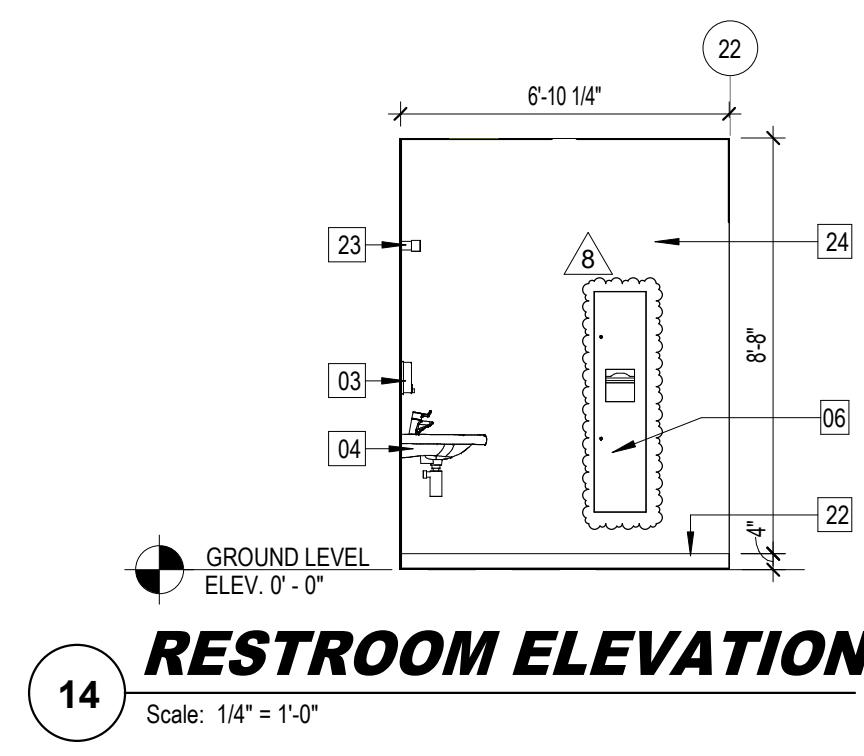


RESTROOM ELEVATION
14
Scale: 1/4" = 1'-0"

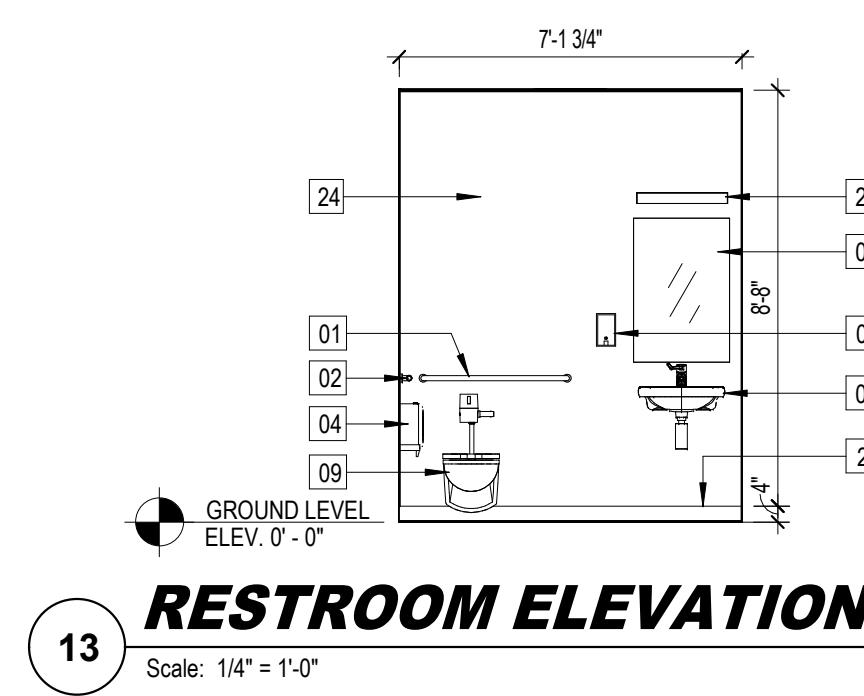


RESTROOM ELEVATION
13
Scale: 1/4" = 1'-0"

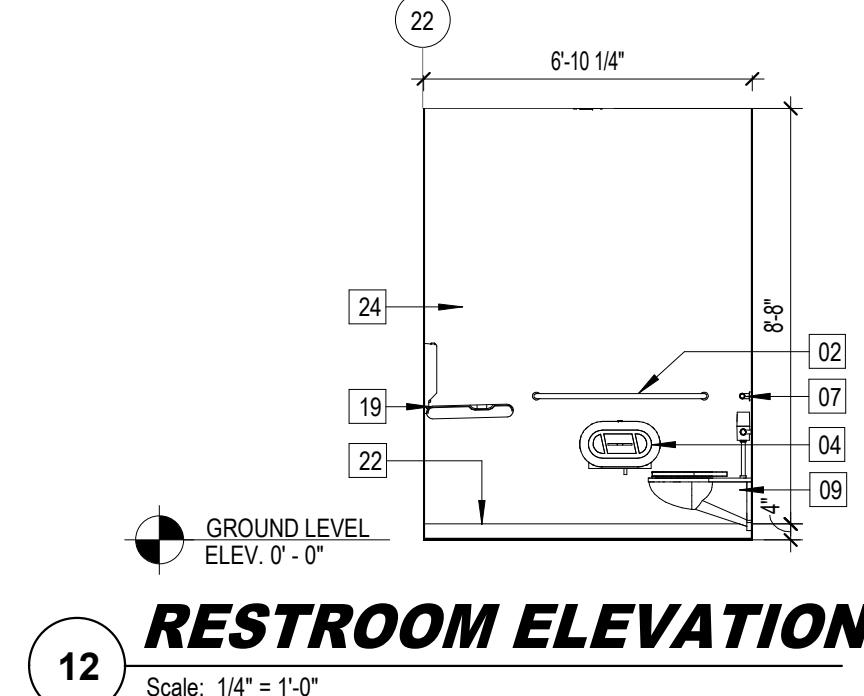


RESTROOM ELEVATION
12
Scale: 1/4" = 1'-0"

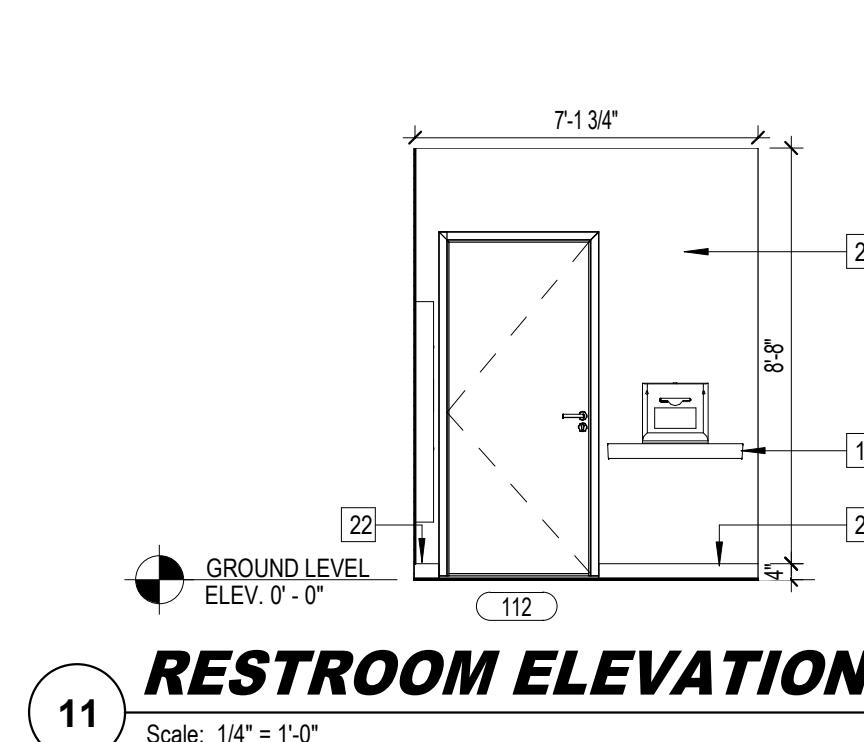


RESTROOM ELEVATION
11
Scale: 1/4" = 1'-0"

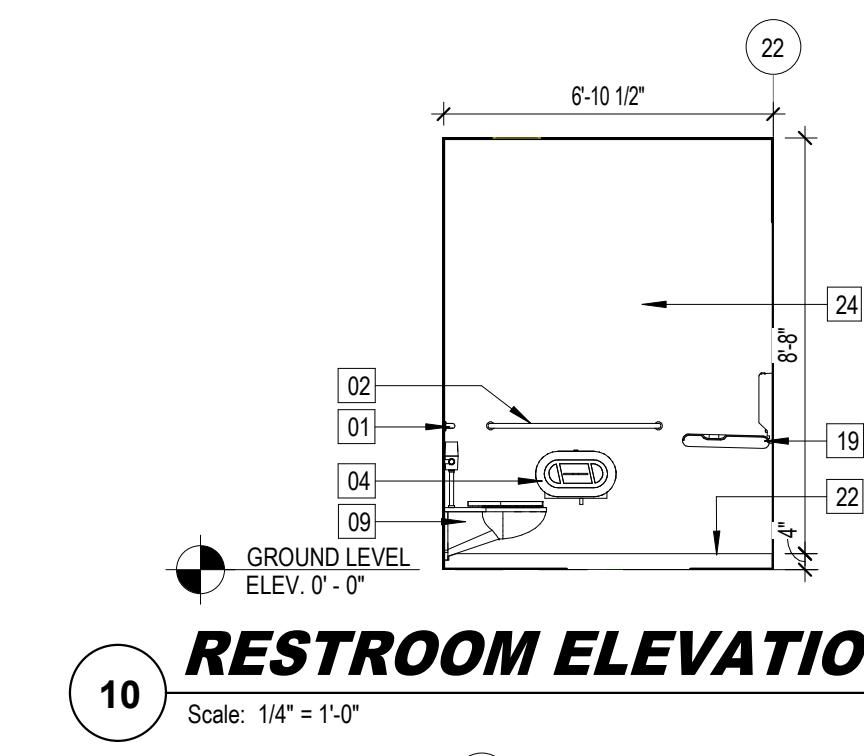


RESTROOM ELEVATION
10
Scale: 1/4" = 1'-0"

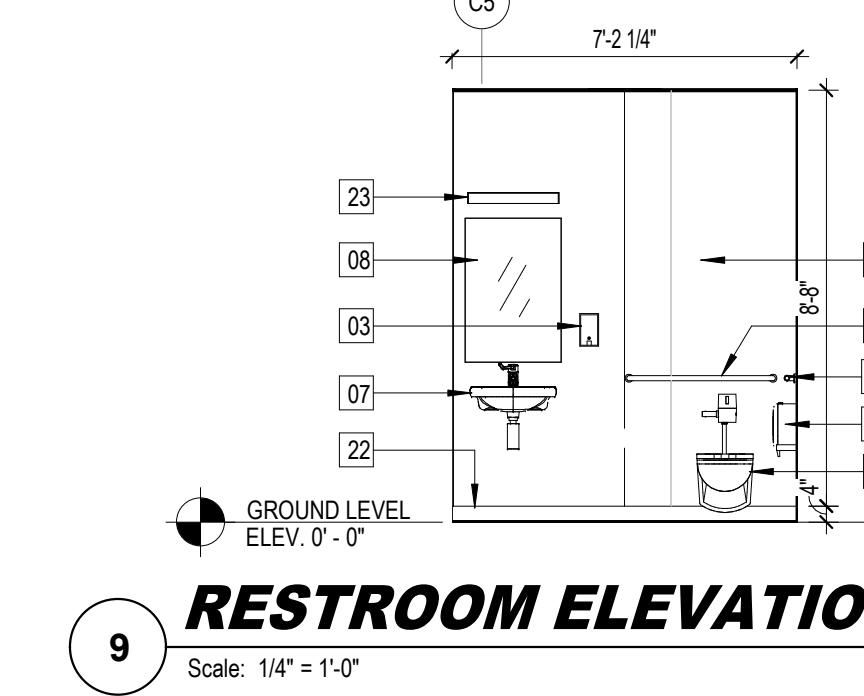


RESTROOM ELEVATION
9
Scale: 1/4" = 1'-0"

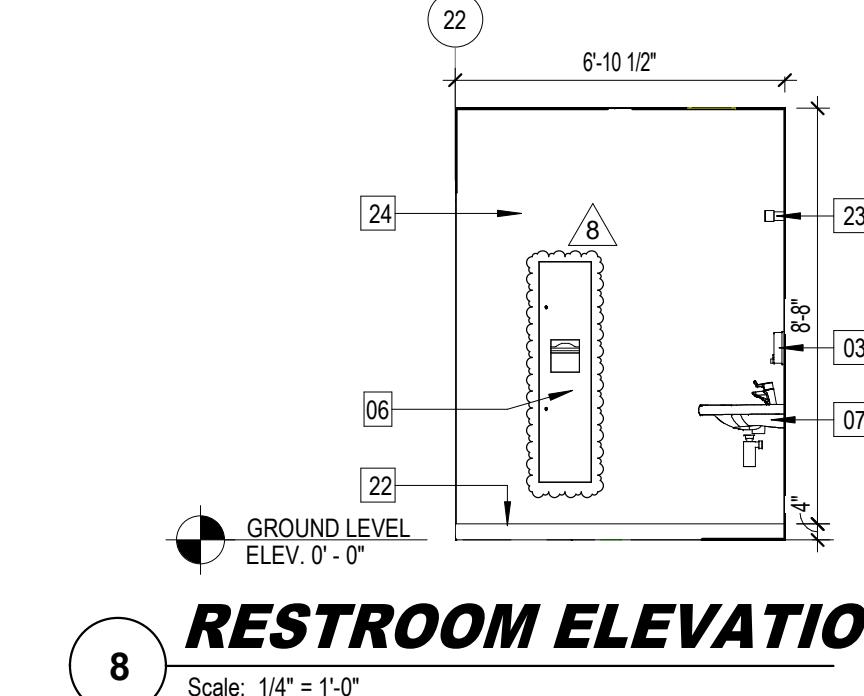


RESTROOM ELEVATION
8
Scale: 1/4" = 1'-0"

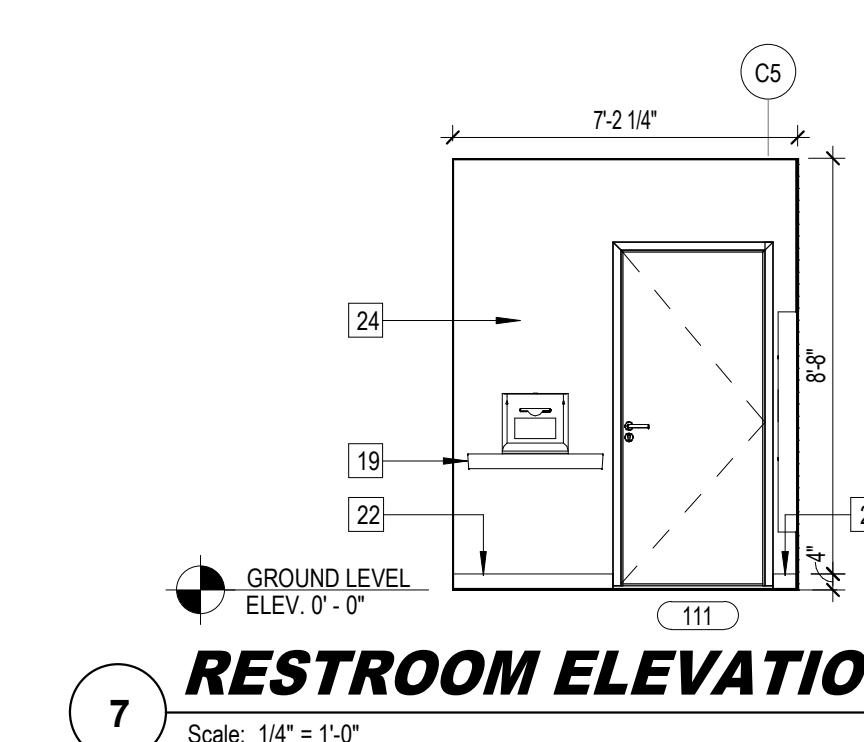


RESTROOM ELEVATION
7
Scale: 1/4" = 1'-0"

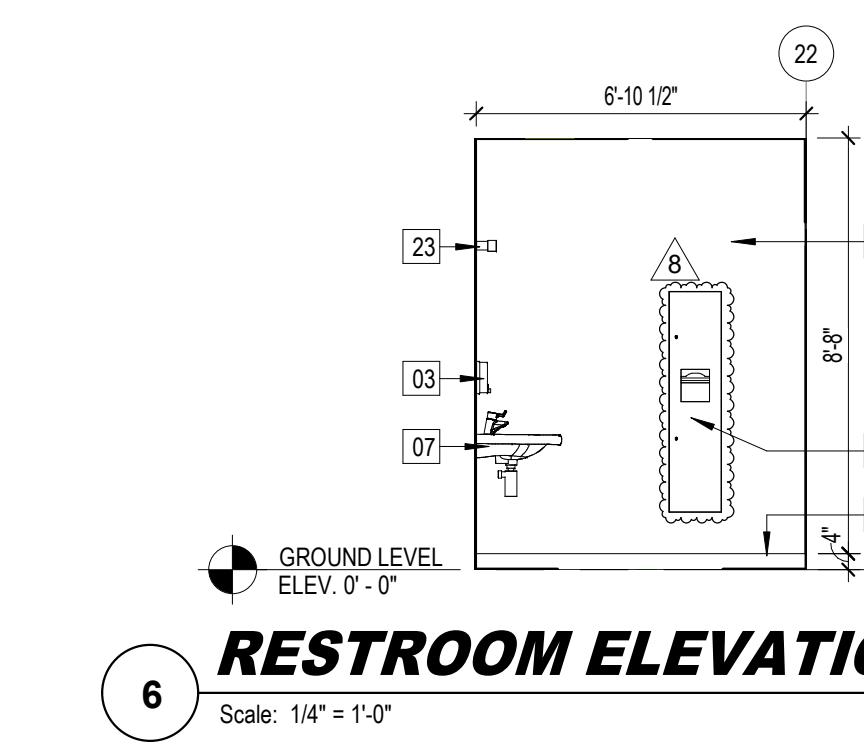


RESTROOM ELEVATION
6
Scale: 1/4" = 1'-0"

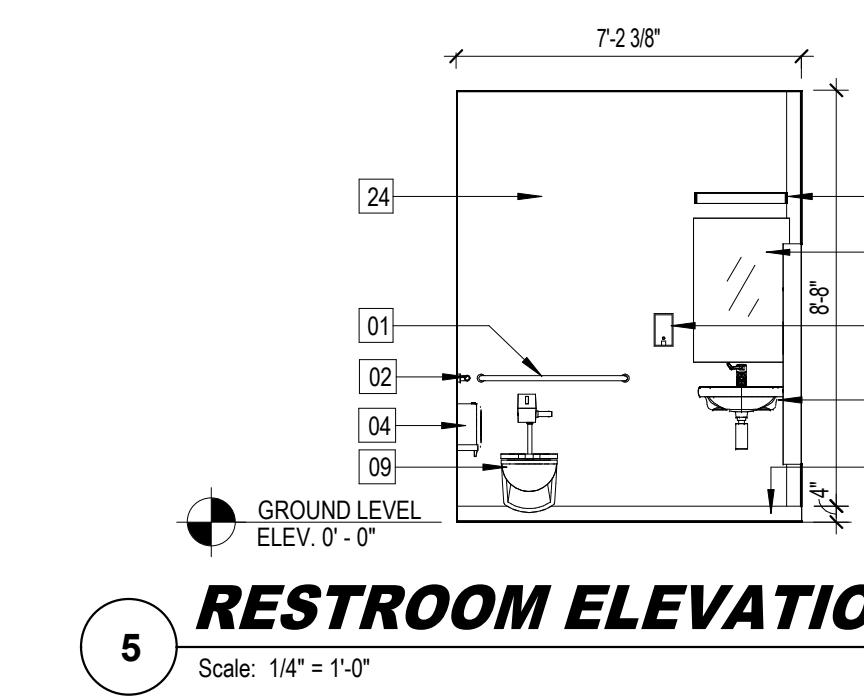



RESTROOM ELEVATION
5
Scale: 1/4" = 1'-0"

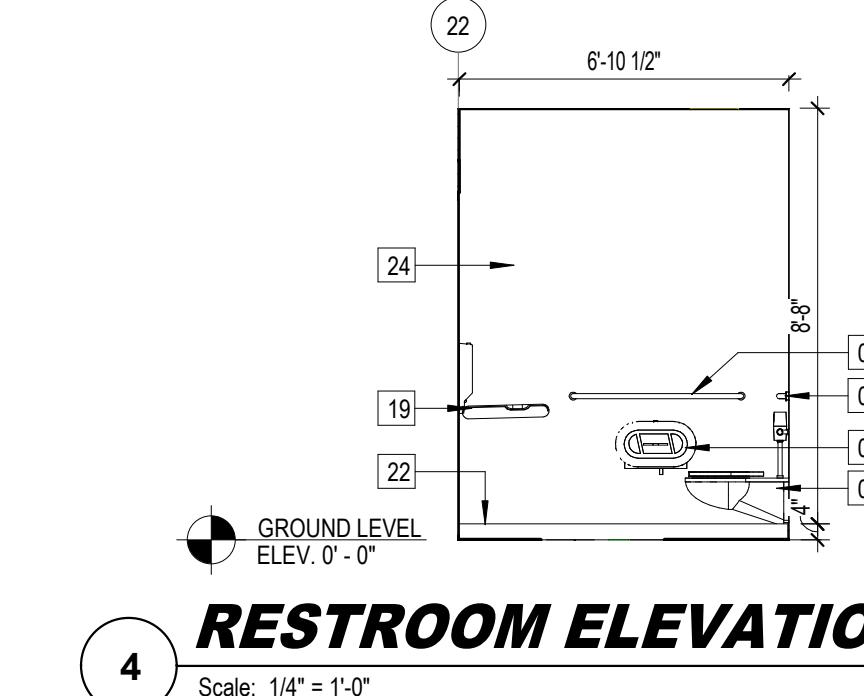

RESTROOM ELEVATION
4
Scale: 1/4" = 1'-0"


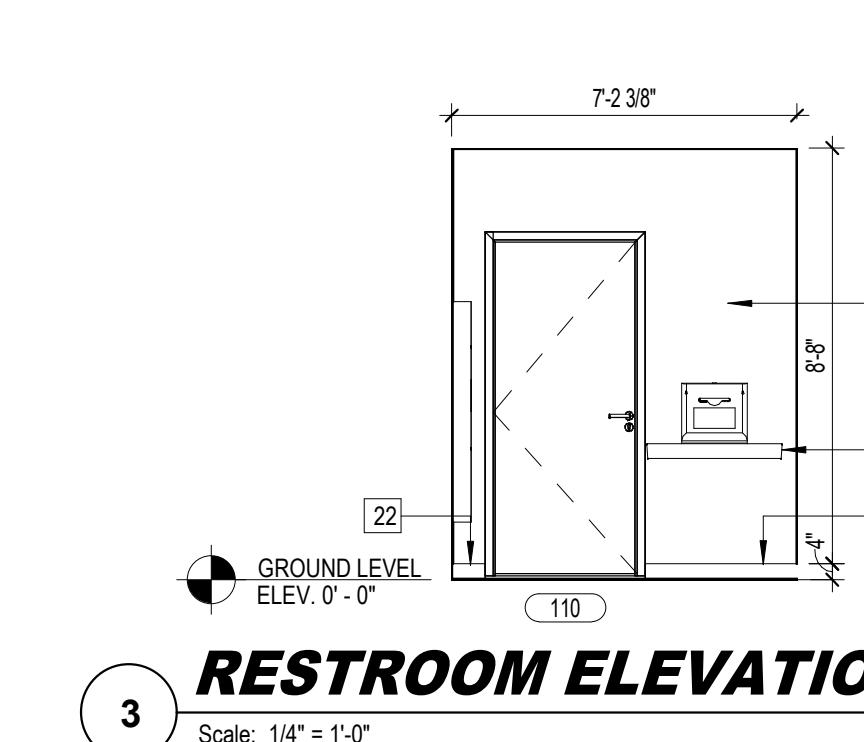


RESTROOM ELEVATION
3
Scale: 1/4" = 1'-0"

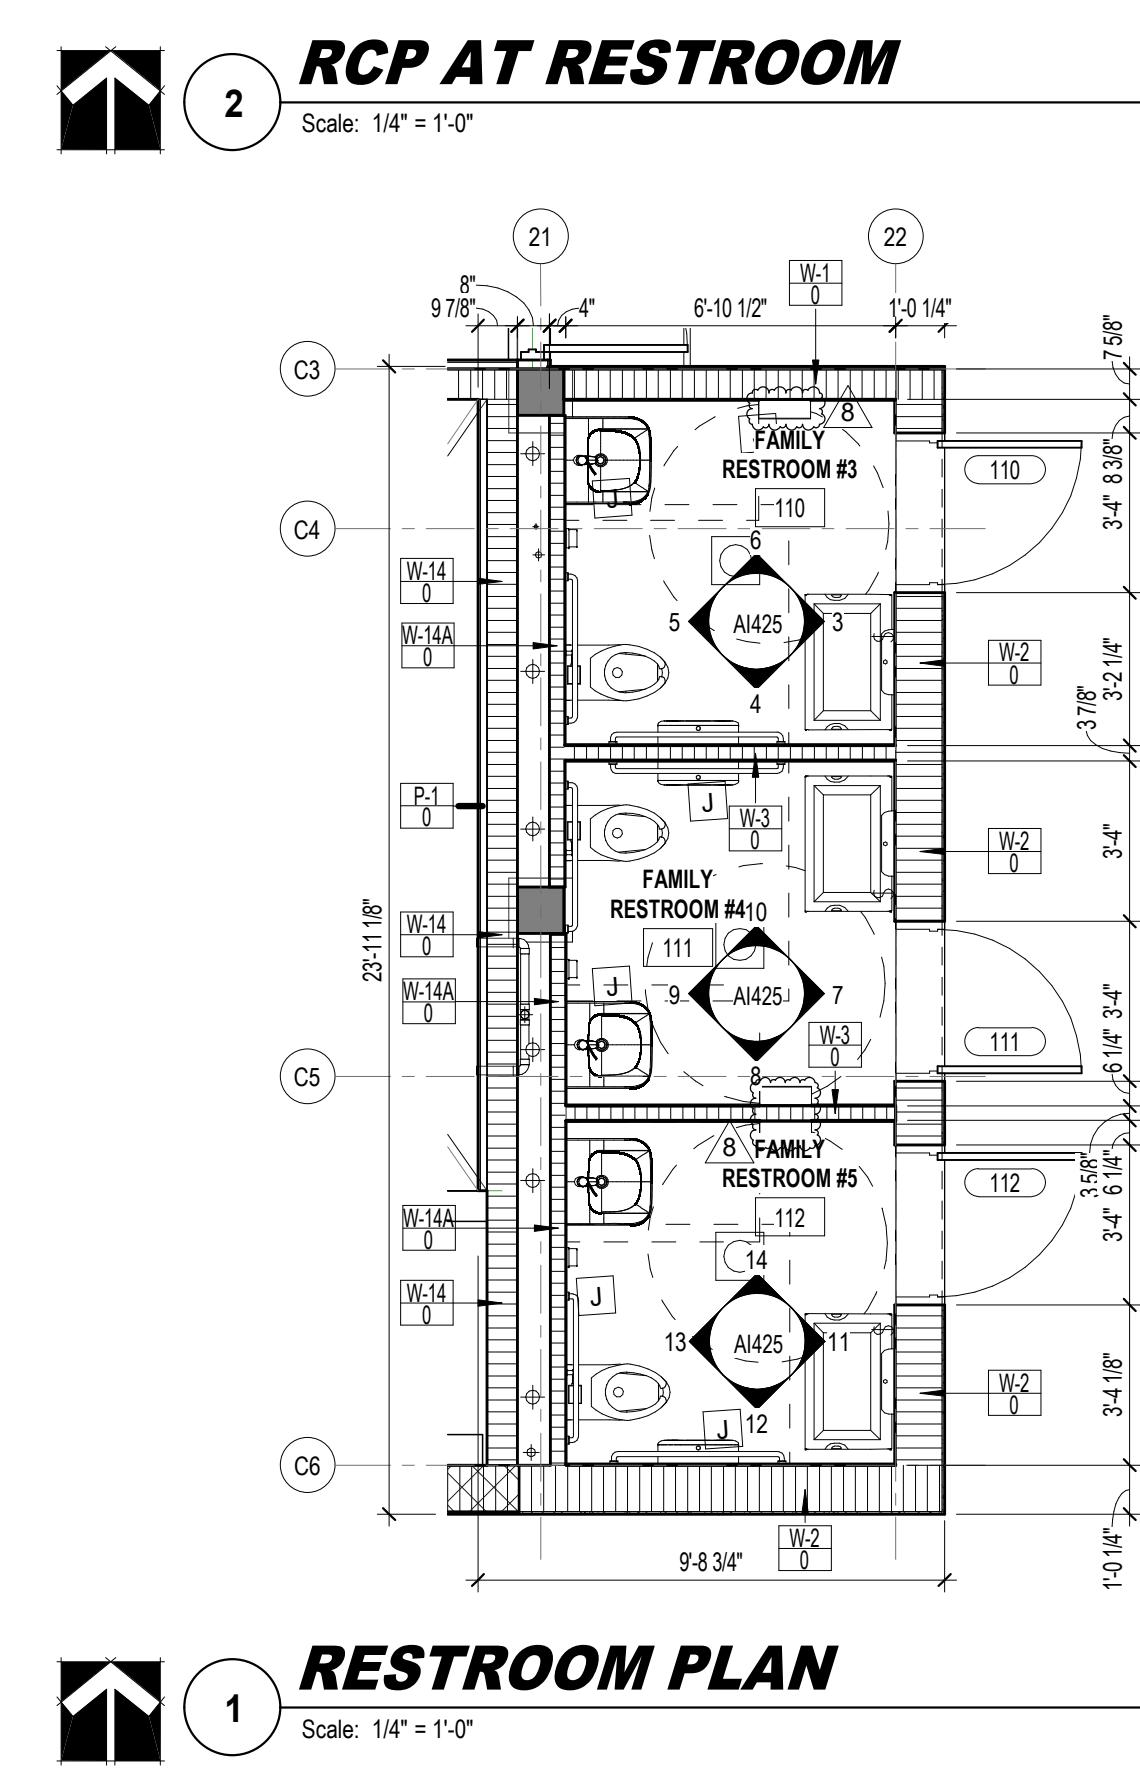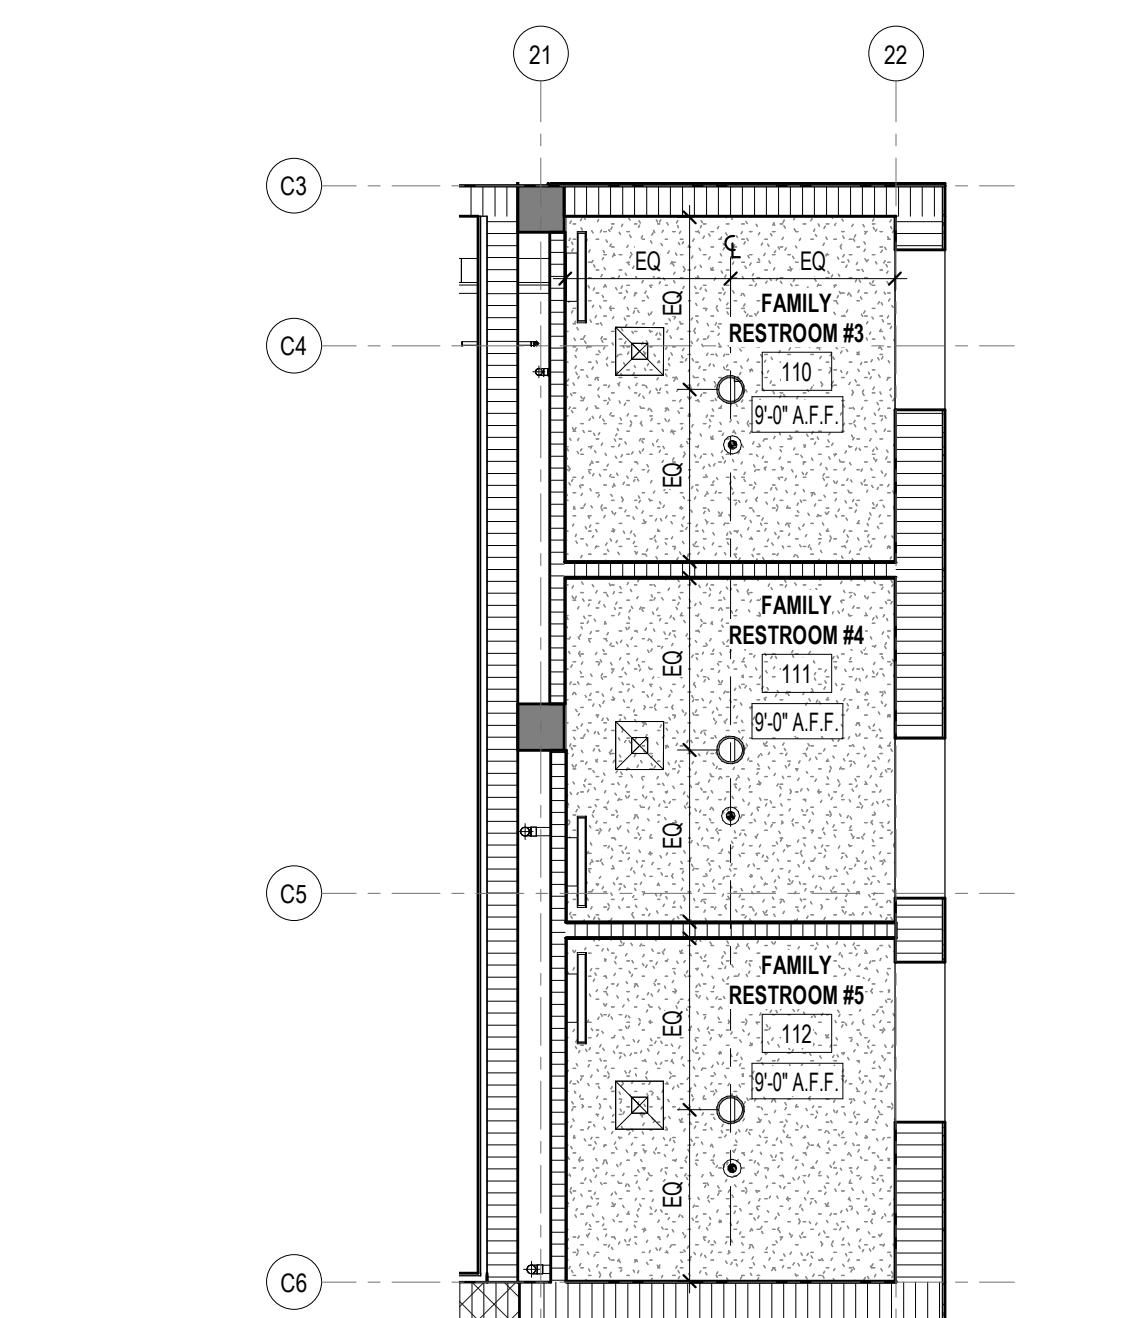

RESTROOM FIXTURE NOTES	
1.	OBJECTS PROTRUDING MORE THAN 4" INTO PATH OF EGRESS MUST BE MOUNTED AT NO MORE THAN 27" AFF OR BE PROTECTED BY A BARRIER PER FBC 2020, 7TH EDITION (ACCESSIBILITY, 307.2)
2.	ALL FIXTURES WITHIN THE ADA BATHROOM SHALL BE ADA COMPLIANT AND INSTALLED PER ADA REQUIREMENTS.
3.	ATTACH GRAB BARS WITH FASTENERS (AS APPROVED BY MANUFACTURER) THAT WILL ALLOW FOR A 250 LB. VERTICAL LOADING OF THE GRAB BAR. COMPLY WITH STRUCTURAL LOADING REQUIREMENTS, INDICATED IN NOTE 1; ALL PENETRATIONS BEHIND GRAB BAR SUPPORTS SHALL BE SEALED TO MAINTAIN INTEGRITY OF WALLS/PARTITIONS/BARRIERS.

REFLECTED CEILING PLAN LEGEND	
HARD CEILING	2' x 2' ARMSTRONG TECHZONE ACOUSTIC CEILING TILE
CEILING ACCESS PANEL	CERTAINTEED SOLO BAFFLE SYSTEM
EXIT LIGHT FIXTURE - WALL MOUNTED	2' x 3' CEILING ACCESS PANEL
EXIT LIGHT FIXTURE - CEILING MOUNTED	EXIT LIGHT FIXTURE - WALL MOUNTED
LED STRIP LIGHT FIXTURE SURFACE MOUNTED (SEE ELECTRICAL DRAWINGS FOR TYPE)	LED STRIP LIGHT FIXTURE SURFACE MOUNTED (SEE ELECTRICAL DRAWINGS FOR TYPE)
RECESSED LED STRIP LIGHT FIXTURE	RECESSED LED STRIP LIGHT FIXTURE
2' x 2' RECESSED LIGHT FIXTURE	2' x 2' RECESSED LIGHT FIXTURE
EXTERIOR CIRCULAR LIGHT FIXTURE	EXTERIOR CIRCULAR LIGHT FIXTURE
RETURN OR EXHAUST GRILLE	RETURN OR EXHAUST GRILLE
SUPPLY GRILLE	SUPPLY GRILLE
RECESSED LIGHT FIXTURE	RECESSED LIGHT FIXTURE
PENDANT GYMNASIUM LIGHT FIXTURE	PENDANT GYMNASIUM LIGHT FIXTURE
BOH LED FIXTURE - WALL OR PENDANT MOUNTED	BOH LED FIXTURE - WALL OR PENDANT MOUNTED
FIRE SPRINKLER (SEE FIRE PROTECTION PLANS)	FIRE SPRINKLER (SEE FIRE PROTECTION PLANS)
RETRACTING ELECTRONIC BASKETBALL HOOP	RETRACTING ELECTRONIC BASKETBALL HOOP
SPEAKER	SPEAKER
X-XX	CEILING HEIGHT TAG
ES	EXPOSED STRUCTURE
STAGE LIGHT	STAGE LIGHT

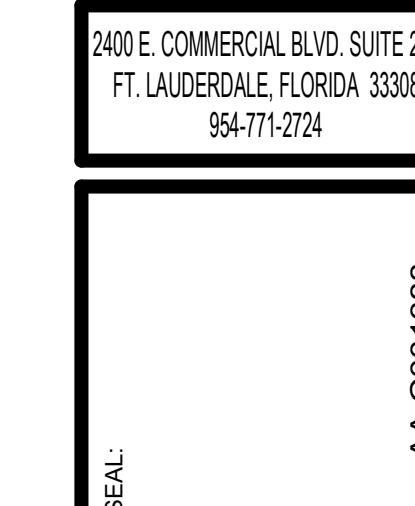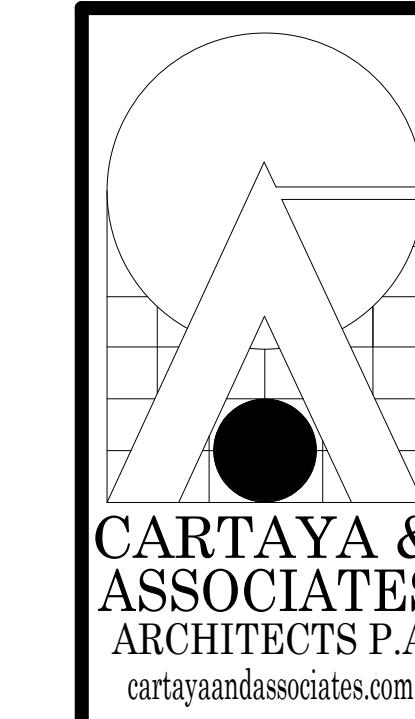

ALL DESIGN AND DATA IS PROVIDED, UNLESS OTHERWISE SPECIFIED, ON AN AS IS, WHERE IS BASIS. THE CONTRACTOR AND DESIGNER MAKE NO WARRANTIES, EXPRESSED OR IMPLIED, AS TO THE MERCHANTABILITY OR FITNESS FOR A PARTICULAR PURPOSE. THE CONTRACTOR AND DESIGNER SHALL NOT BE LIABLE FOR ANY DAMAGES, DIRECT OR INDIRECT, WHICH MAY RESULT FROM THE USE OF THIS DRAWING. THE CONTRACTOR AND DESIGNER SHALL NOT BE LIABLE FOR ANY DAMAGES, DIRECT OR INDIRECT, WHICH MAY RESULT FROM THE USE OF THIS DRAWING. THE CONTRACTOR AND DESIGNER SHALL NOT BE LIABLE FOR ANY DAMAGES, DIRECT OR INDIRECT, WHICH MAY RESULT FROM THE USE OF THIS DRAWING.

