Note:
Hardscape plans and details are intended to convey design intent and may not include all information required for full and complete construction. Please refer to Architectural, Structural, Civil, and Mechanical/Electrical/Plumbing Plans for additional information.

SCHENKELSHULTZ

200 E. ROBINSON STREET SUITE 300 ORLANDO, FL 32801 voice 407-872-3322 tax 407-872-3303 schenkelshultz.com SS Lic. No. -AA-C000937

SEE WWW.SCHENKELSHULTZ.COM/COPYRIGHT FOR POLICY AND INFORMATION



REVISIONS DESCRIPTION DATE

CONFIDENTIAL COPYRIGHT 2020 SCHENKEL & SHULTZ INC.
SEE WWW.SCHENKELSHULTZ.COM/COPYRIGHT FOR POLICY AND

PURSUANT TO SECTION 102 OF THE COPYRIGHT ACT, 17 U.S.C., ALL CONCEPTS, IDEAS, DESIGNS,
ARRANGEMENTS, DRAWINGS, AND PLANS INDICATED OR REPRESENTED BY THIS DOCUMENT ARE COPYRIGHTED
BY SCHENKEL & SHULTZ INC. AS SUCH ALL CONCEPTS, IDEAS, DESIGNS, ARRANGEMENTS, DRAWINGS, AND PLANS
INDICATED OR REPRESENTED BY THIS DOCUMENT ARE OWNED BY AND THE PROPERTY OF SCHENKELSHULTZ
AND WERE CREATED, EVOLVED AND DEVELOPED FOR IT: "S OWN USE. NONE OF THE IDEAS, DESIGNS,
ARRANGEMENTS, OR PLANS SHALL BE USED BY OR DISCLOSED TO ANY PERSON ACHITECTURAL OR
ENCHIEFERING EIRM, CONSTRUCTION FIRM, SUPPONTRACTION, CIRCLE SIZEM SURPLIES, OR CONSTRUCTION FOR ANY ENGINEERING FIRM, CONSTRUCTION FIRM, SUBCONTRACTING FIRM, SUPPLIER, OR CORPORATION FOR ANY PURPOSE WHATSOEVER WITHOUT THE WRITTEN PERMISSION OF SCHENKEL & SHULTZINC. PURSUANT TO WORK MADE FOR HIRE ON OR AFTER DECEMBER 1, 1990, LASTS FOR 95 YEARS FROM THE DATE OF PUBLICATION OF THE WORK OR FOR 120 YEARS FROM THE DATE OF CREATION OF THE UNPUBLISHED PLANS, WHICHEVER TERM WARNING: REPRODUCTION HEREOF IS A CRIMINAL OFFENSE UNDER SECTION 102 OF THE COPYRIGHT ACT, 17 U.S.C.; 18 U.S.C. SEC. 506. UNAUTHORIZED DISCLOSURE MAY CONSTITUTE TRADE SECRET MISAPPROPRIATION IN VIOLATION OF I.C.24-2-31-1 ET. SEQ. AND OTHER LAWS. THE CONCEPTS, IDEAS, DESIGNS, ARRANGEMENTS, DRAWINGS, AND PLANS DISCLOSED ARE COPYRIGHTED AND HEREIN MAY BE PATENTED OR BE THE SUBJECT OF PENDING PATENT APPLICATION. ANYONE VIOLATING THE INTENT OF THIS COPYRIGHT PROTECTION WILL BE WRITTEN DIMENSIONS ON THESE DOCUMENTS SHALL HAVE PRECEDENCE OVER SCALE DIMENSIONS.

CONTRACTORS SHALL VERIFY AND BE RESPONSIBLE FOR ALL DIMENSIONS AND CONDITIONS ON THE JOB AND THIS OFFICE MUST BE NOTIFIED OF ANY VARIATION FROM THE DIMENSIONS AND CONDITIONS SHOWN BY THESE DRAWINGS. SHOP DRAWINGS AND OR DETAILS MUST BE SUBMITTED TO THIS OFFICE FOR REVIEW BEFORE

FORT PIERCE WESTWOOD ACADEMY HS

1801 Panther Lane, Ft Pierce, FL 34947




St. Lucie Public Schools 9461 Brandywine Ln Port St. Lucie, FL 34986

ISSUE DATE: 10/31/2023 COMM. NO.: 2022108

CHECKED BY: KT


HARDSCAPE KEY SHEET

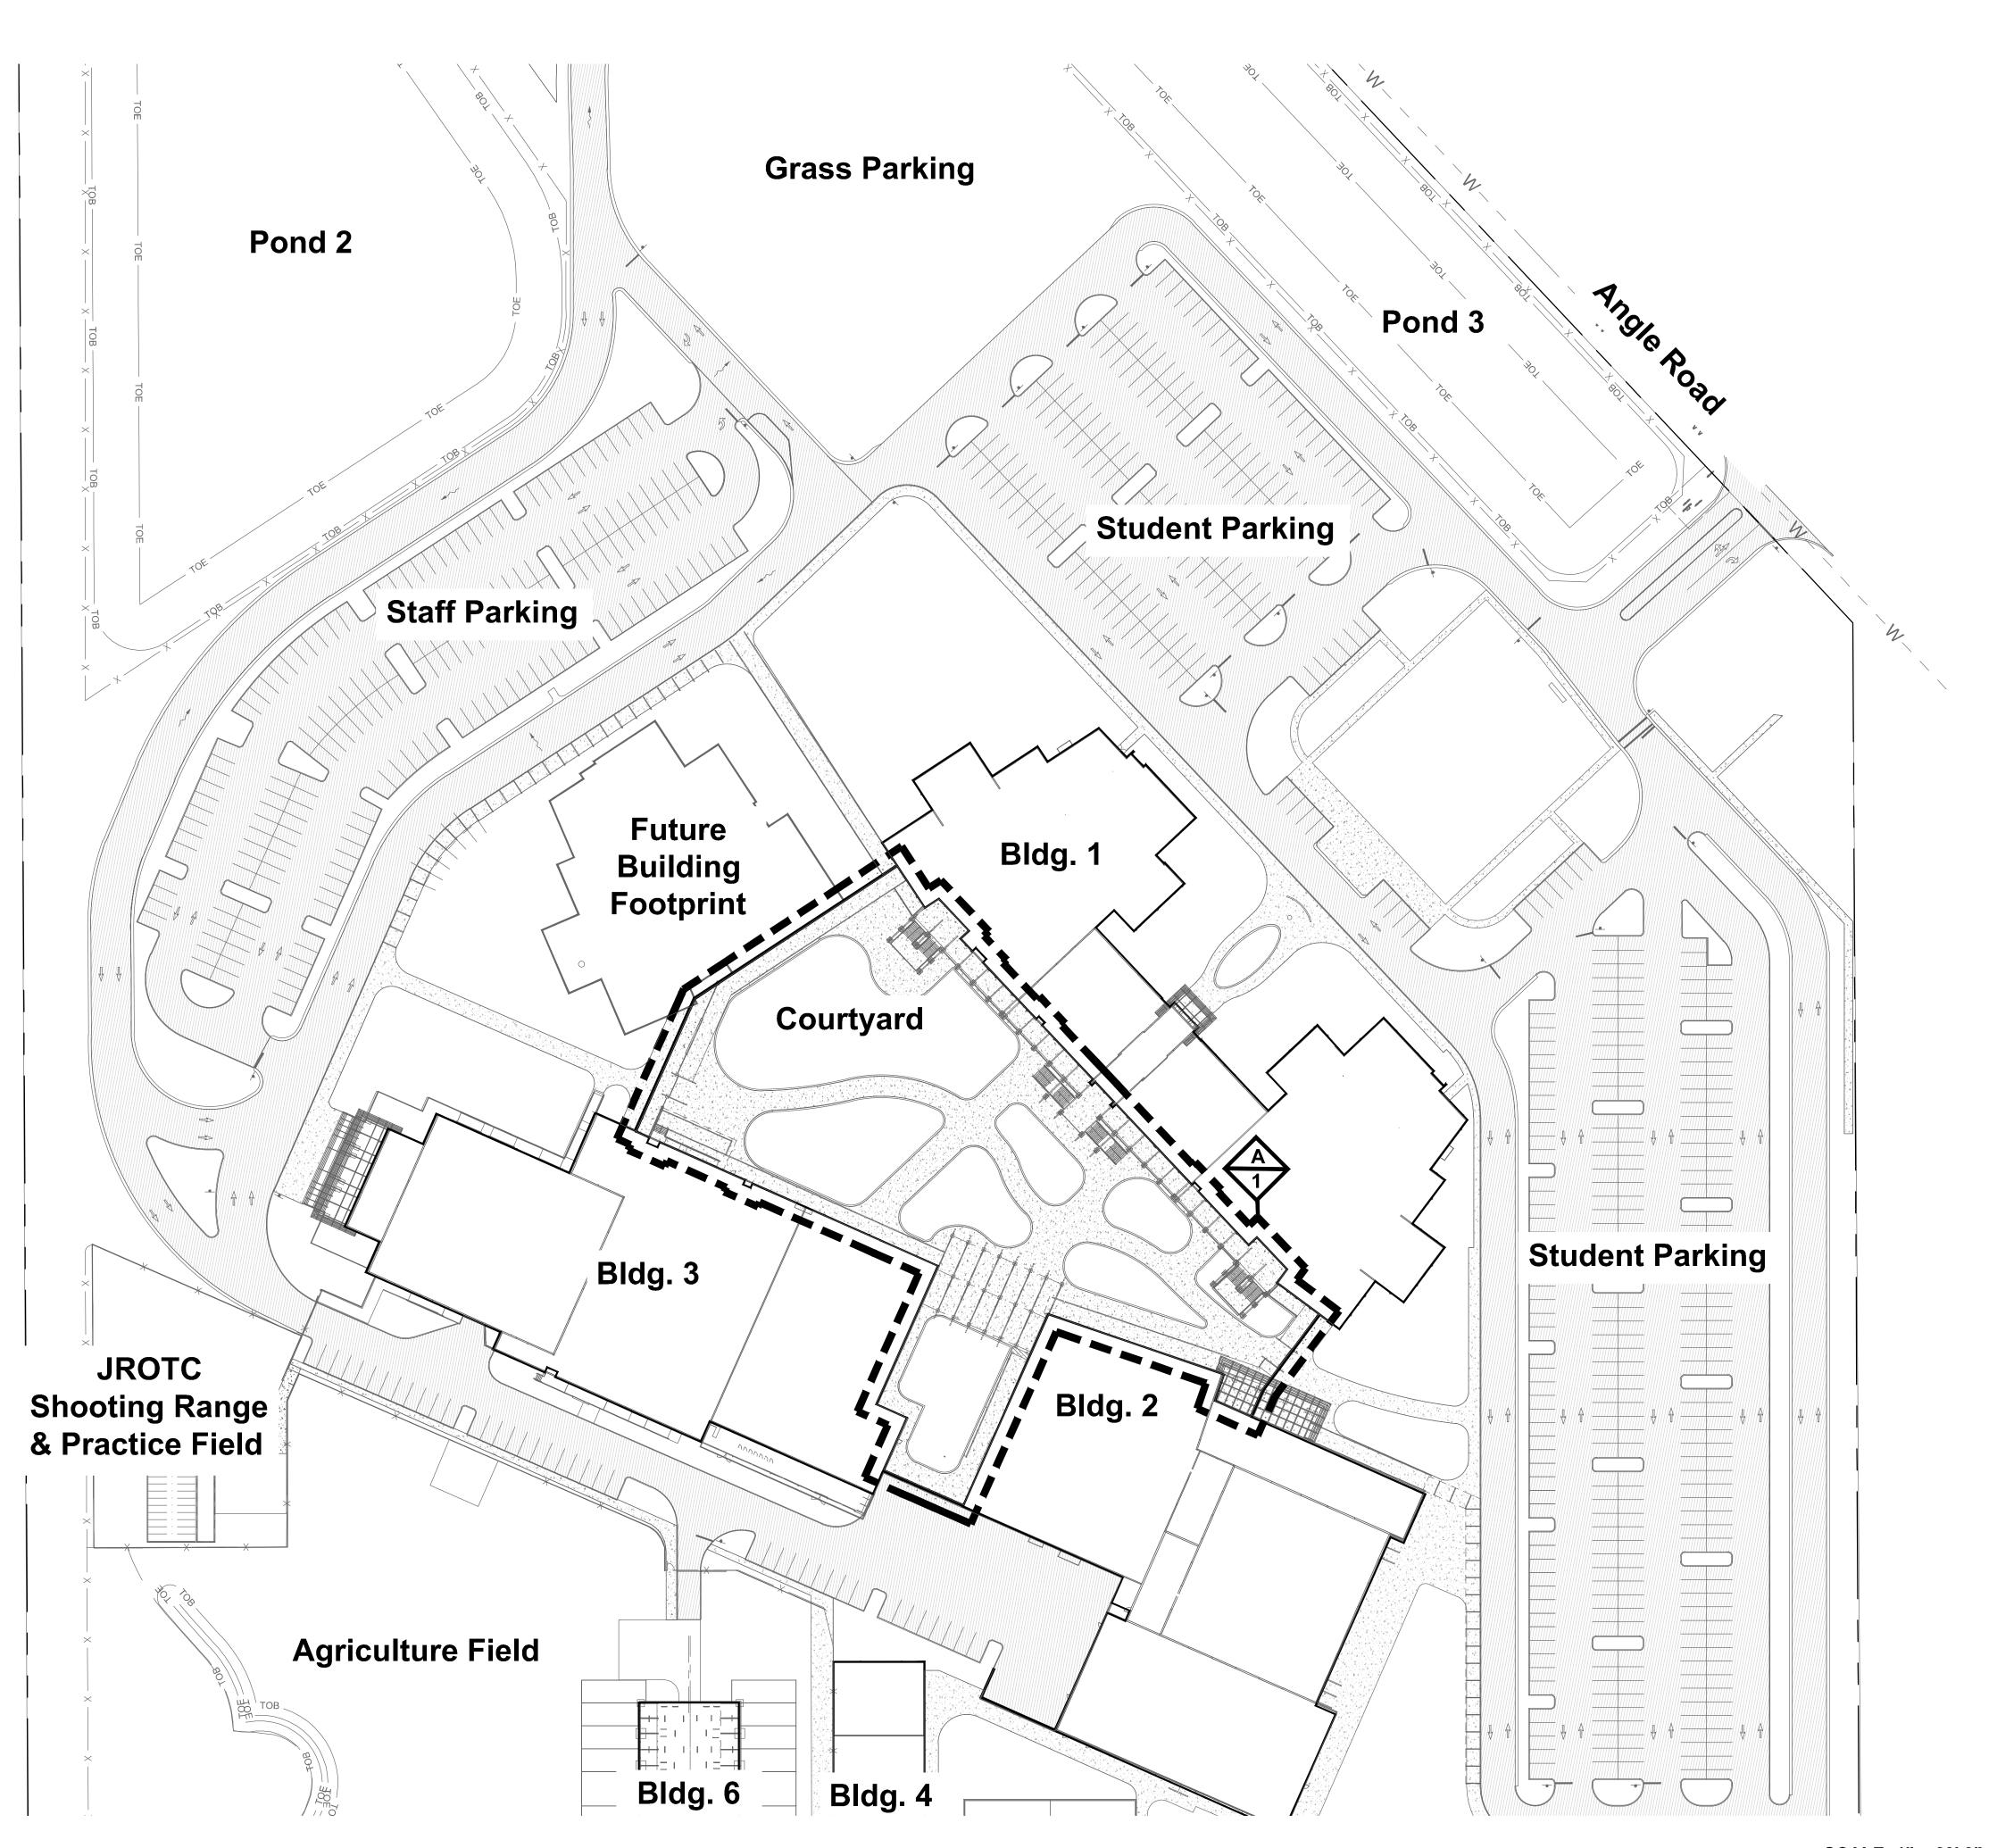



 1
 2
 3
 4
 5
 6
 7
 8
 9
 10
 11
 12
 13
 14
 15
 18

Impervious Area Legend Pavement Sidewalk

SCALE: 1" = 60' 0"

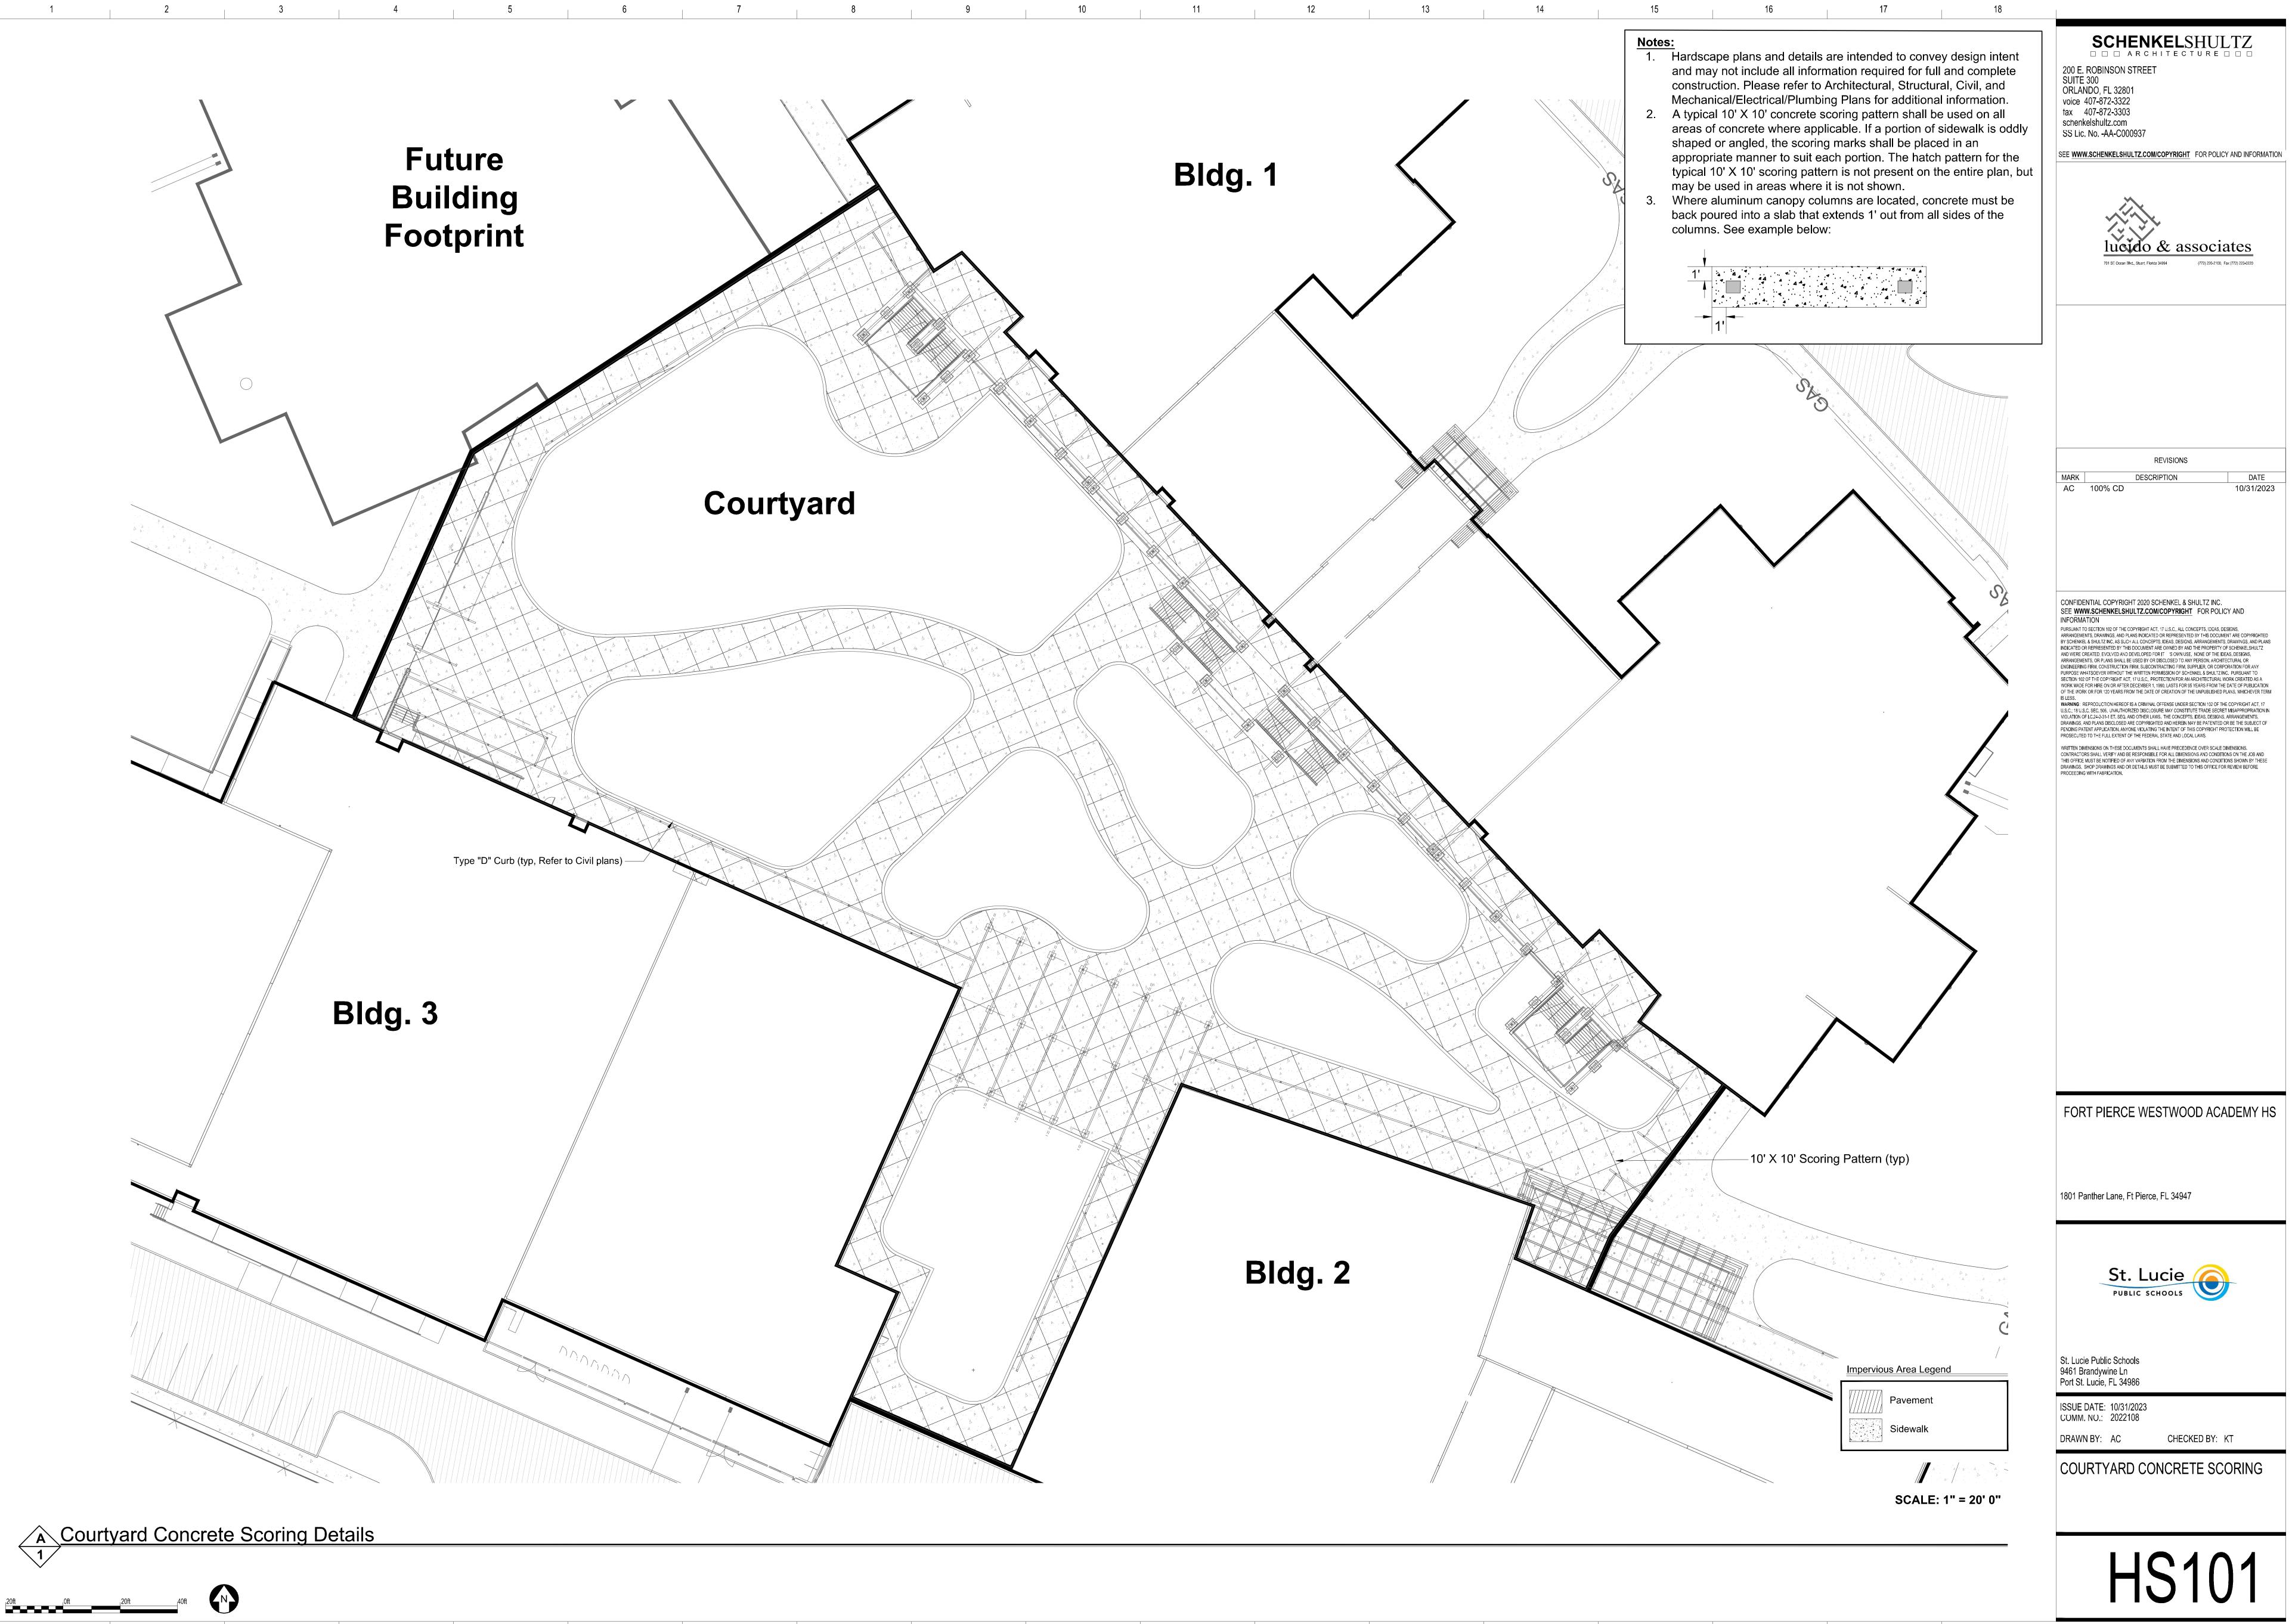

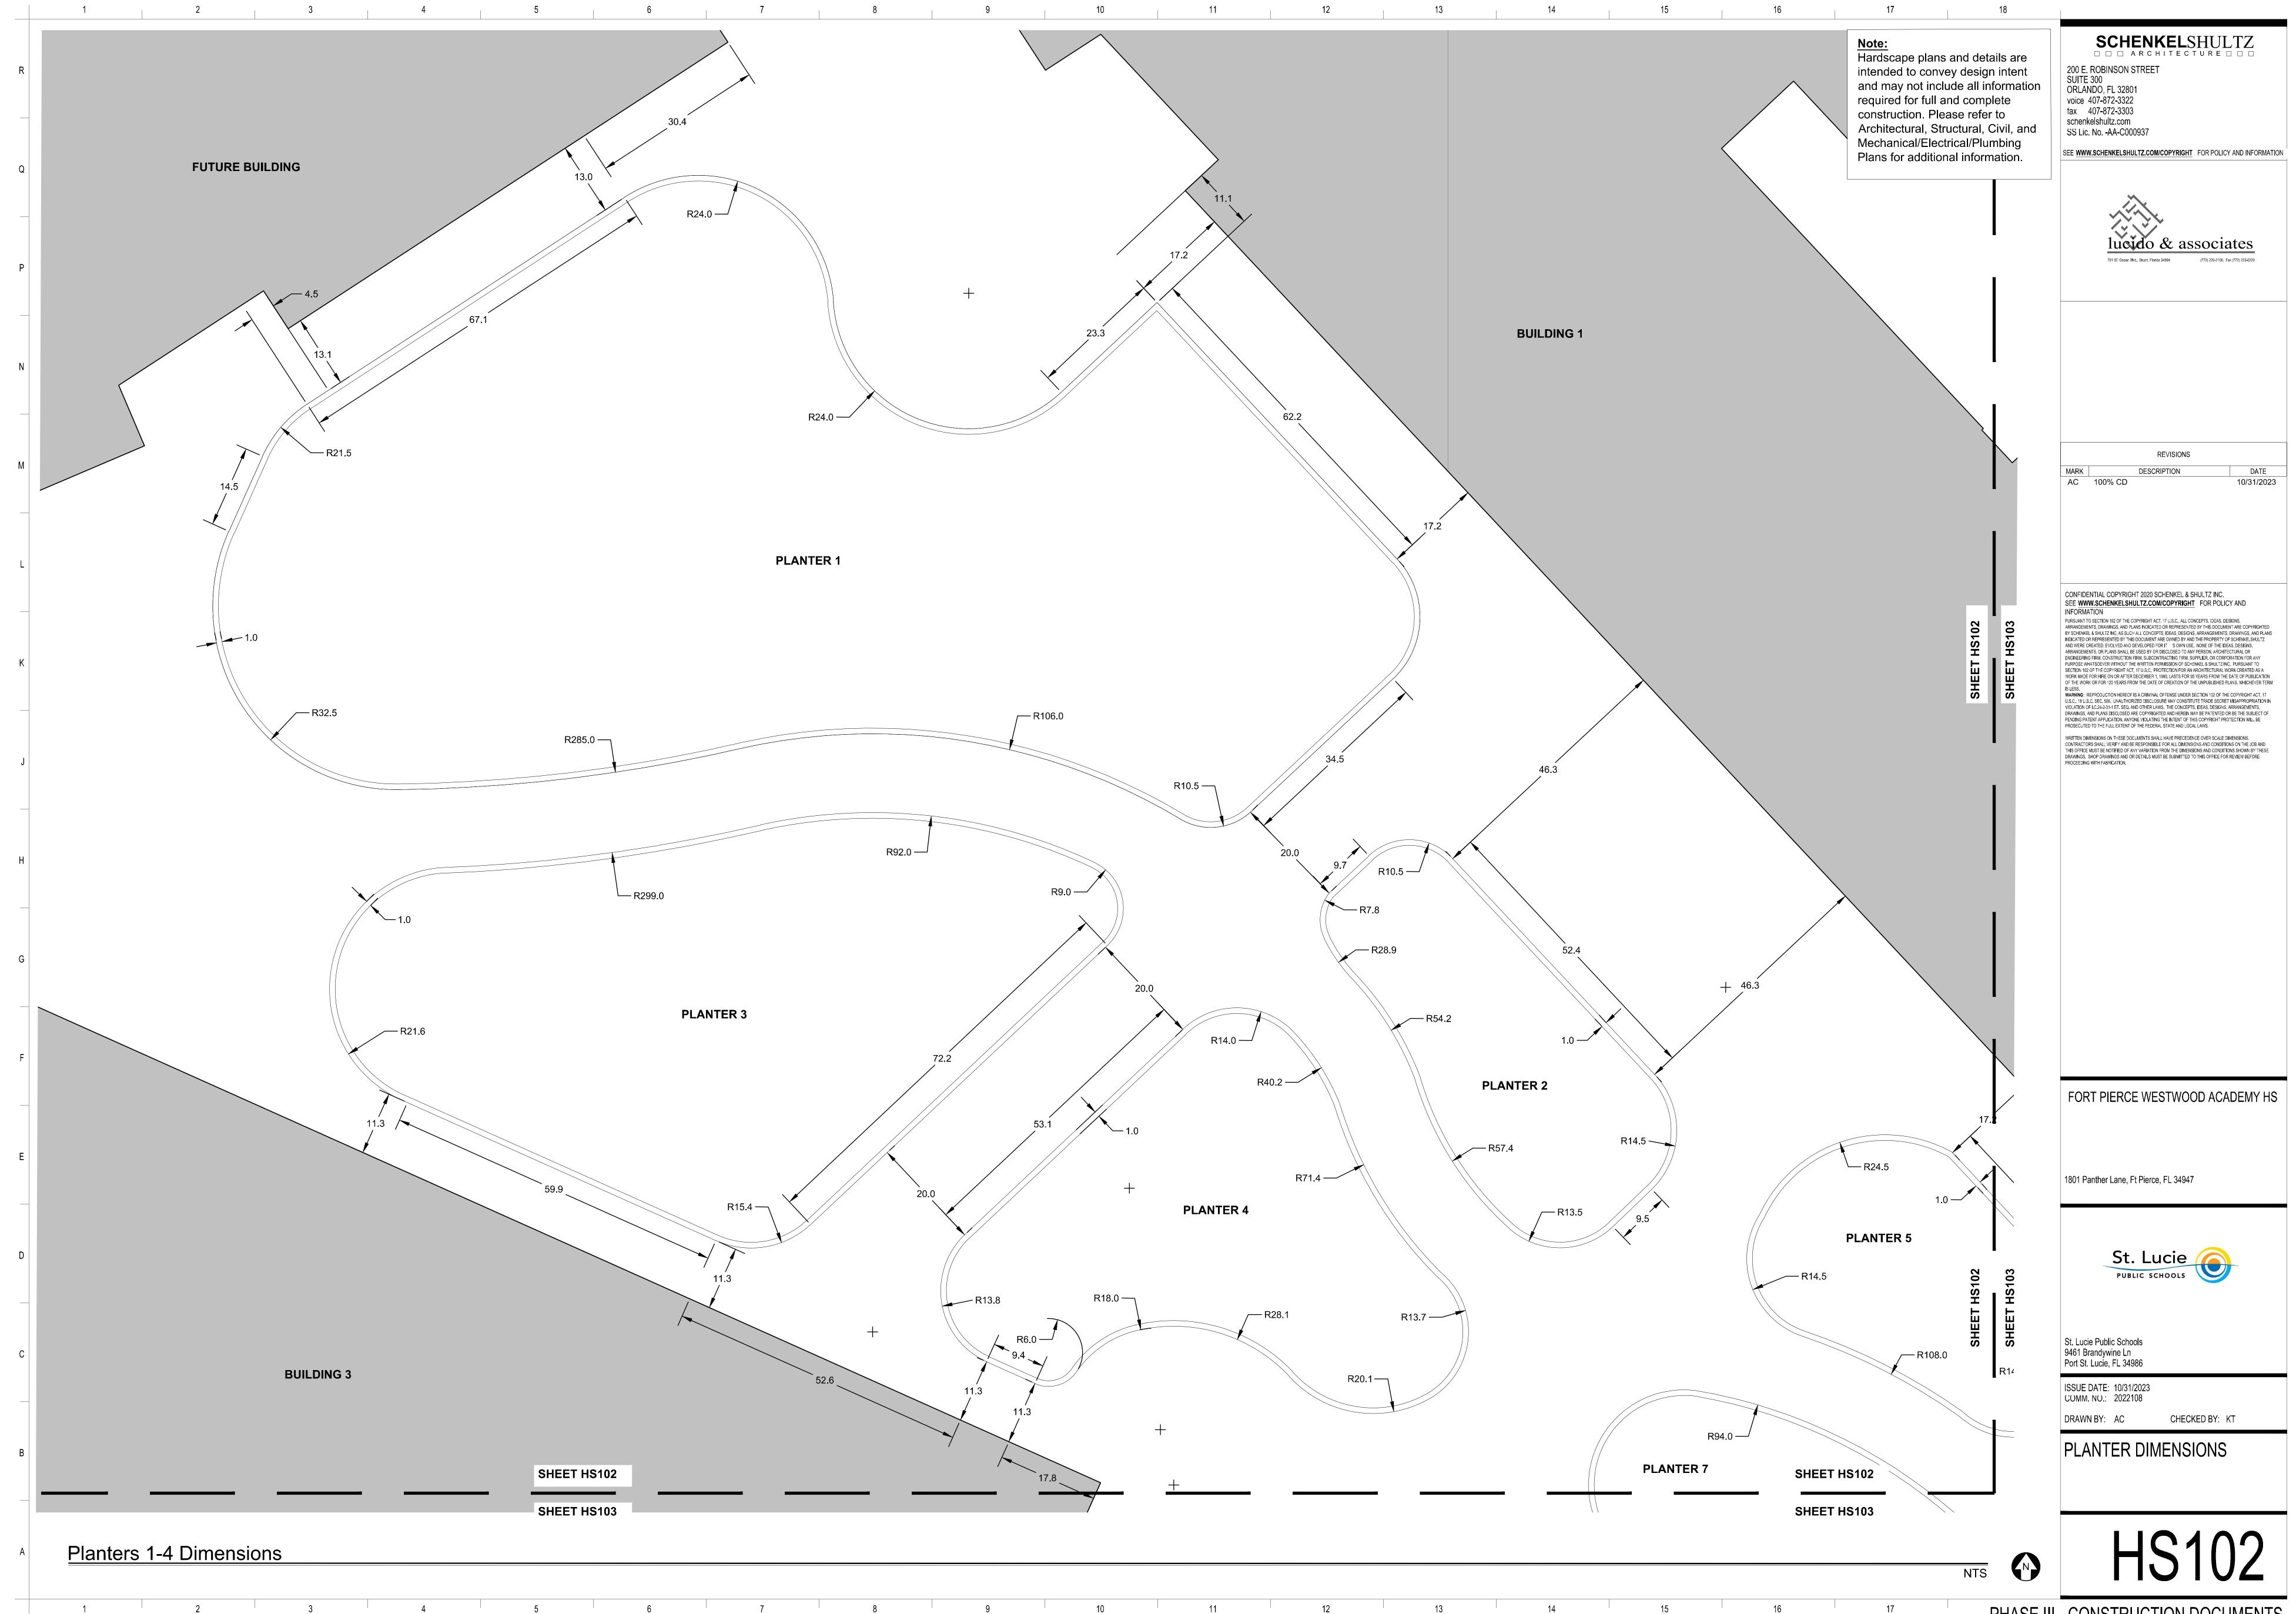

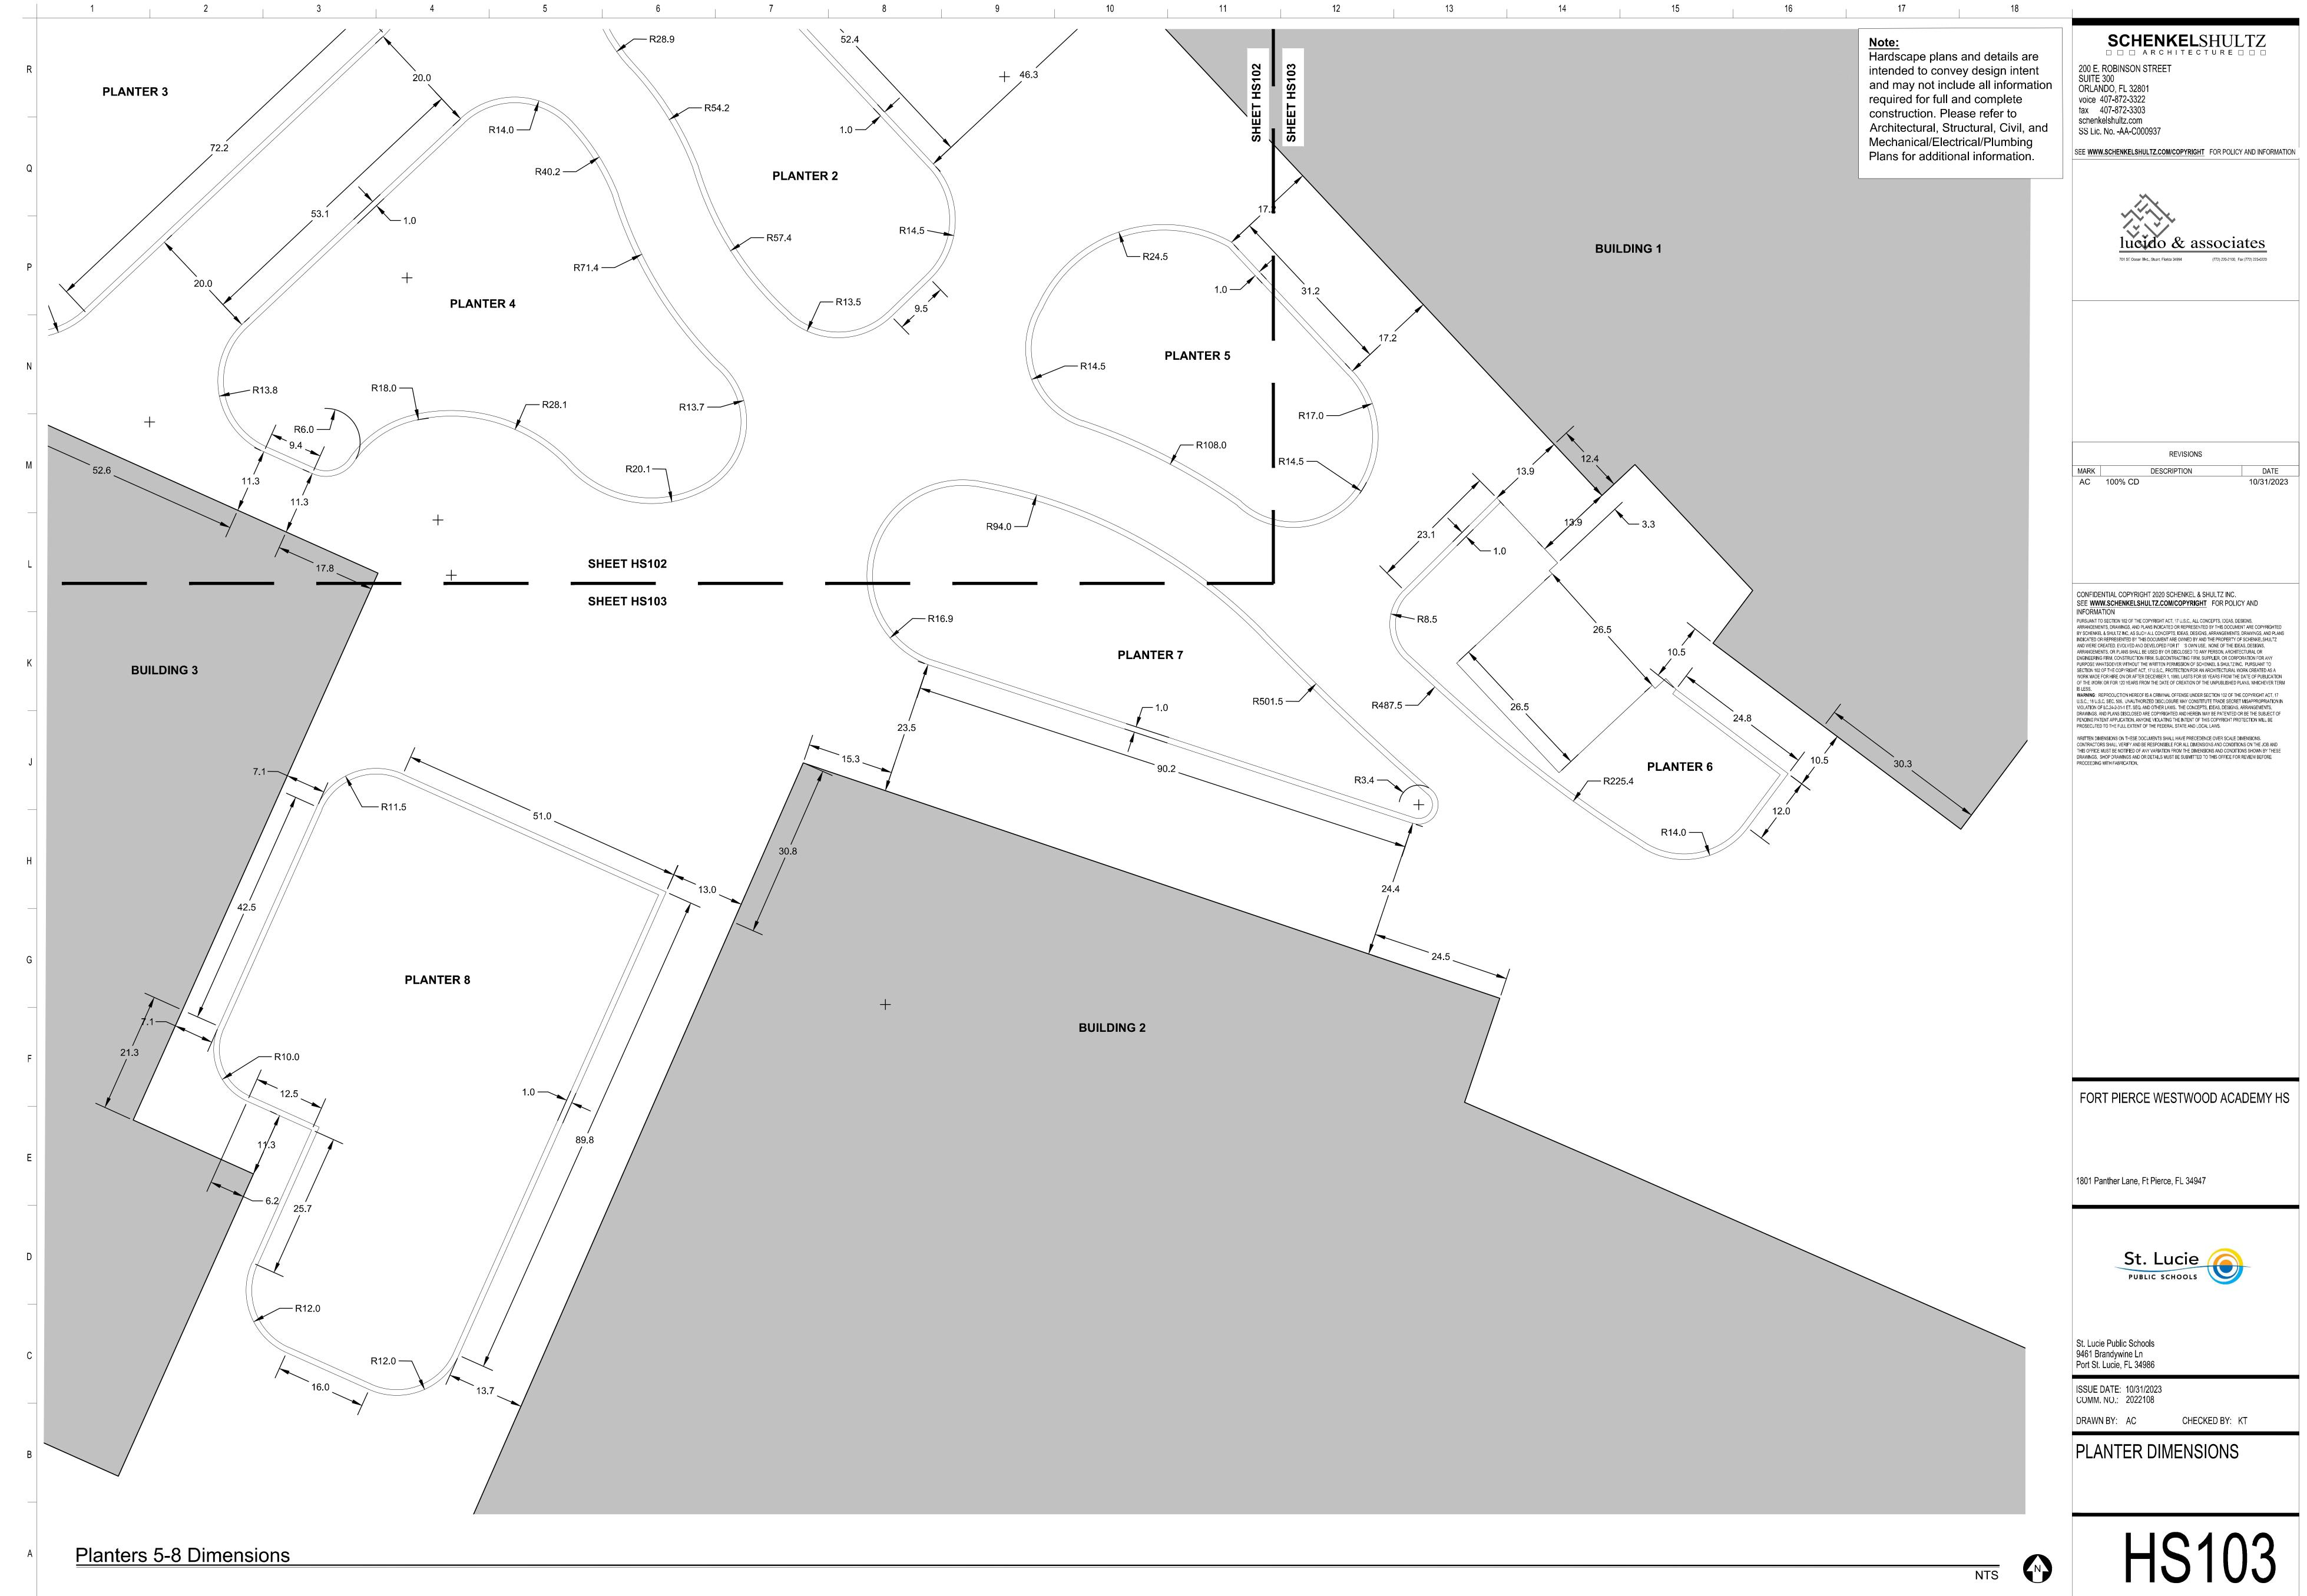

PHASE III - CONSTRUCTION DOCUMENTS